



2- CONTRACTOR TO CO-ORDINATE ALL BUILDING SERVICES. 3- CONTRACTOR TO MAKE SHOP DRAWINGS AS PER CONTRACT DOCUMENTS AND ACCORDING TO STIPULATED REQUIREMENTS. PLUMBING GENERAL NOTES & CONDITIONS OF OPERATIONS THE FOLLOWING NOTES SHALL BE APPLICABLE FOR ALL PLUMBING DRAWINGS ALL WORK SHALL CONFORM TO THE LATEST INTERNATIONAL BUILDING CODE, AND THE REQUIREMENTS OF LOCAL AUTHORITIES SANITARY LINE SHALL BE OF PVC (SCHEDULE 50) AS APPROVED BY BUILDING OFFICE. WATER LINE SHOULD BE OF PVC 02 03 SANITARY FIXTURES AND ALL OTHER EQUIPMENT AND MATERIALS SHALL BE INSTALLED IN STRIC ACCORDANCE WITH MANUFACTURERS INSTRUCTIONS 04 CONDENSATE LINE SHOULD BE OF $\frac{3}{4}$ " DIA (SCHEDULE 40) INCLUDED WITH $\frac{1}{2}$ " AMAFLEX (HOT WATER LINE) AND SLEAVED 12" ABOVE AND 12" BELOW THE SLAB ENGINEER SIGN: ALL OPEN ENDS OF PIPES SHALL BE PROPERLY PLUGGED OFF TO PREVENT AND FOREIGN MATERIAL FROM ENTERING THE PIPE DURING INSTALATION 05 ALL PIPES UNDER TRAFFIC WILL HAVE MINIMUM 1000 🗆 COVER OR WALL BE ENCASED IN CONCRETE. SHOWER HEAD TO HAVE THE FLOW CONTROL DEVICE TO GIVE MAX FLOW OF THREE GALLONS PER MINUTE EACH 07 ELECTRICAL WATER HEATER SHALL HAVE A STANDBY LOESS NOT THE SUCCEED 4 WATTS PER SQUARE FOOT OF TANK SURFACE AREA 08 STRUCTURAL BOLTS AND NUTS FOR WALL HANGING FIXTURES SHALL BE OF HEAVY CONSTRUCTION SUITABLE TO CARRY THE WEIGHT THAT WILL BE PLACED ON THE CARRIER ATE OF CALIFOR 09 BY THE FIXTURE AND USER Expiration Date: 06/30/2025 PLUMBING FIXTURE SHALL BE SELECTED BY THE OWNED OF BUILDING CONSULTANT: ALL WATER ROUGHING TO BE TERMINATED WITH SHUT OFF VALVES BEFORE CONNECTION TO EQUIPMENT AND FIXTURES. 11 12 ISOLATING VALVES SHALL BE PROVIDED TO SEPARATE THE INDIVIDUAL TOILETS, GATE VALVES SHALL BE PROVIDED TO/FROM WATER 13 PURGE ALL WATERS LINES BEFORE CONNECTION. REFER PLUMBING RISER DIAGRAM FOR PIPE SIZES, IF THERE IS A DIFFERENCE IN SIZES BETWEEN PLAN & RISER DIAGRAM REPORT CONSULTANTS BEFORE PROCEEDING ARCHITECT: 15 JOINTS TO W.C. PANS SHALL BE WITH UPVC CONNECTORS RUBBER GASKETS. PROVIDE ISOLATING VALVE ON ALL MAIN AND BRANCH LINES FOR MAINTENANCE. ALL ELECTRICAL POWER AND CONTROL WIRING/CONDUITING FROM M.C.C. TO PLUMBING E□UIPMENTS SHALL BE CARRIED OUT BY ALL DRAINGE PIPING SHALL BE SLOPED @ MINIMUM 1% TYPICAL STARTING INVERT LEVELS AS INDICATED ELSEWHERE.CONTRACTOR SHALL ESTABLISH INTERMEDIATE/FINAL INVERT LEVELS BASED ON SITE CONOITIONS & THE SAME SHALL BE SHOWN ON SHOP DRAWINGS. FOR COLD AND HOT WATER SUPPLY PPR PN-20 PIPES SHALL BE USED. ALL EXPOSED COLD AND HOT WATER PIPING SHALL BE GI (IIL) MEDIUM CLASS. PROJECT TITLE : ANY VARIATION ON SITE AND / OR DUE TO SIDE CONDITION MUST BE BROUGHT TO THE NOTICE OF CONSULTANTS BEFORE PROCEEDING WITH WORK. 19 PROPOSED SB9 FOR THE CONTRACTOR SHALL RESPONSIBLE FOR COORDINATING WITH GENERAL CIVIL CONTRACTOR, MECHANICAL CONTRACTOR AND ELECTRICAL CONTRACTOR TO ENSURE 20 1329W 125TH LOS THAT ADEQUATE NUMBERS & SIZES OF COORDINATED SLEEVES ARE LEFT IN SLAB. ANGELES, CA90044 21 NO WORK SHOULD BE DONE AT SITE WITHOUT APPROVED SHOP DRAWING. ANY SUCH WORK IS AT THE CONTRACTOR RISK & COST. DESIGN STAGE: SHOP DRAWINGS TO INCLUDE AT LEAST PIPE INVERTS, DOUBLE LINE PIPING, TIE UP DIMENSIONS, VALVES / FITTINGS TO SCALE ETC. 22 ISSUED FOR CONSTRUCTION DRAWING NO: PLUMBING DRAWING TITLE **GRNERAL NOTES & LEGENDS** DRAWN BY: P.S DESIGNED BY: P.S M.N CHECKED BY: SCALE: NORTH: DATE: 13-08-2023


NOTES:


OTHERS WISE NOTED.


1- ALL DIMENSIONS ARE INCH UNLESS

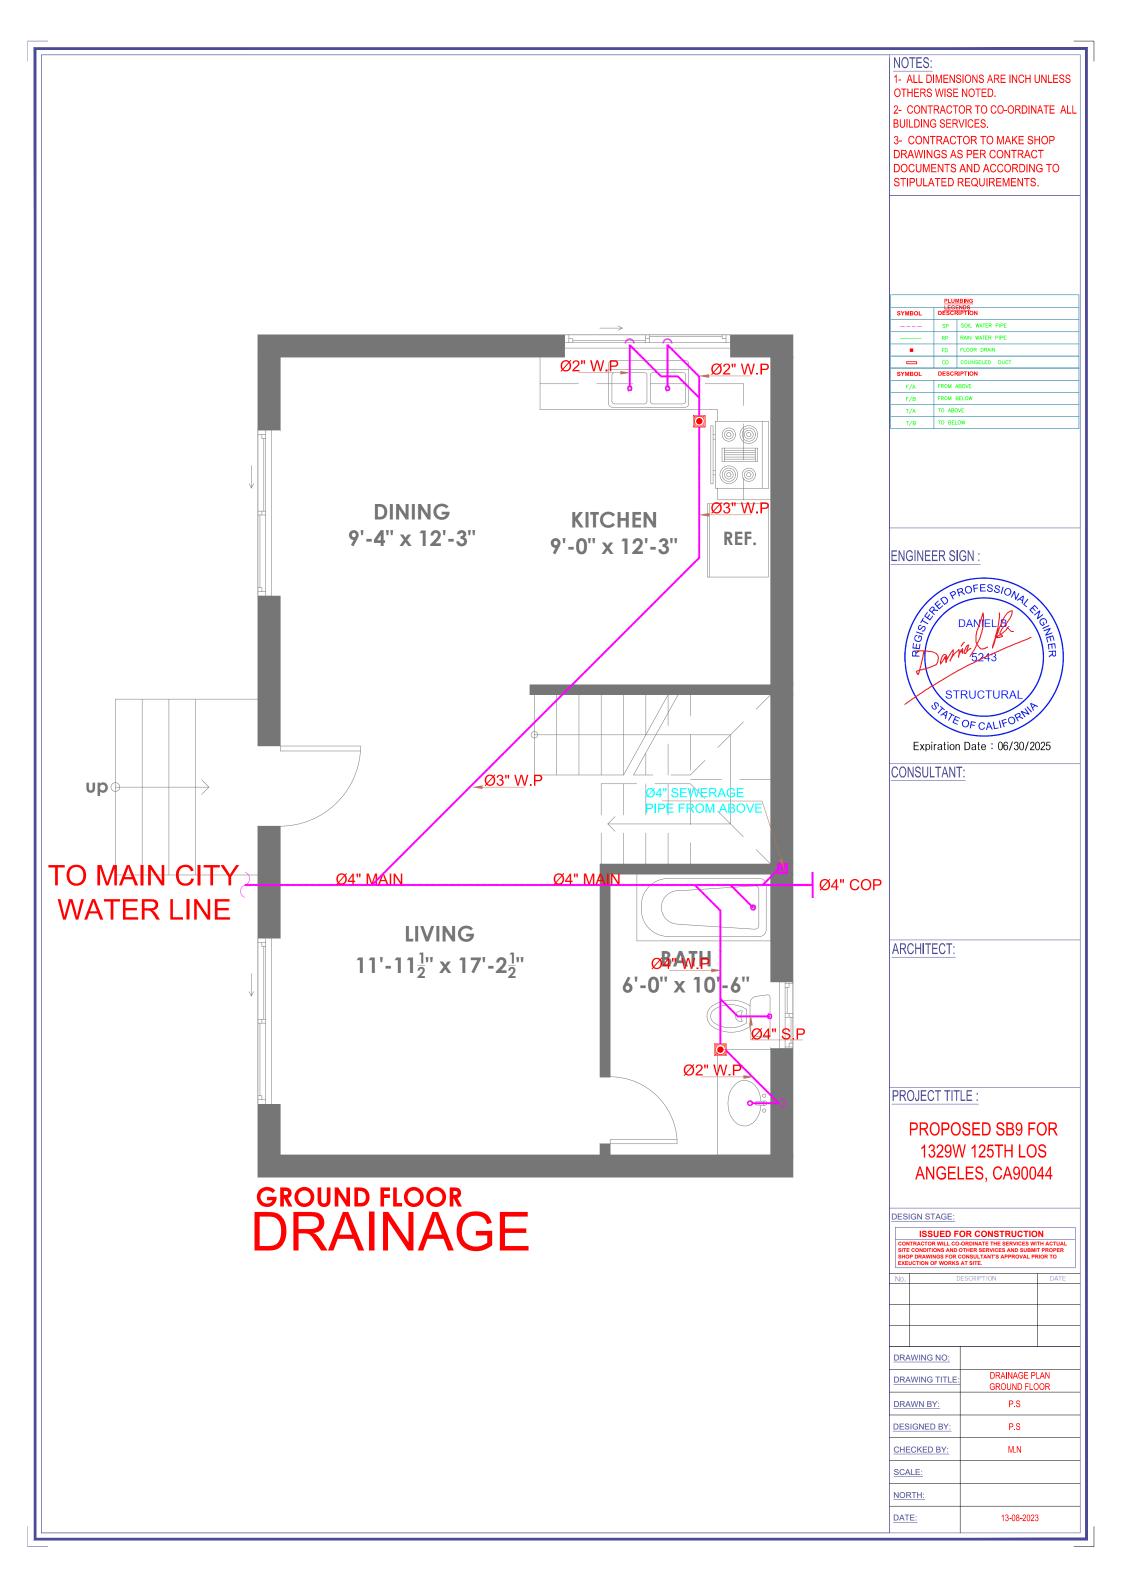

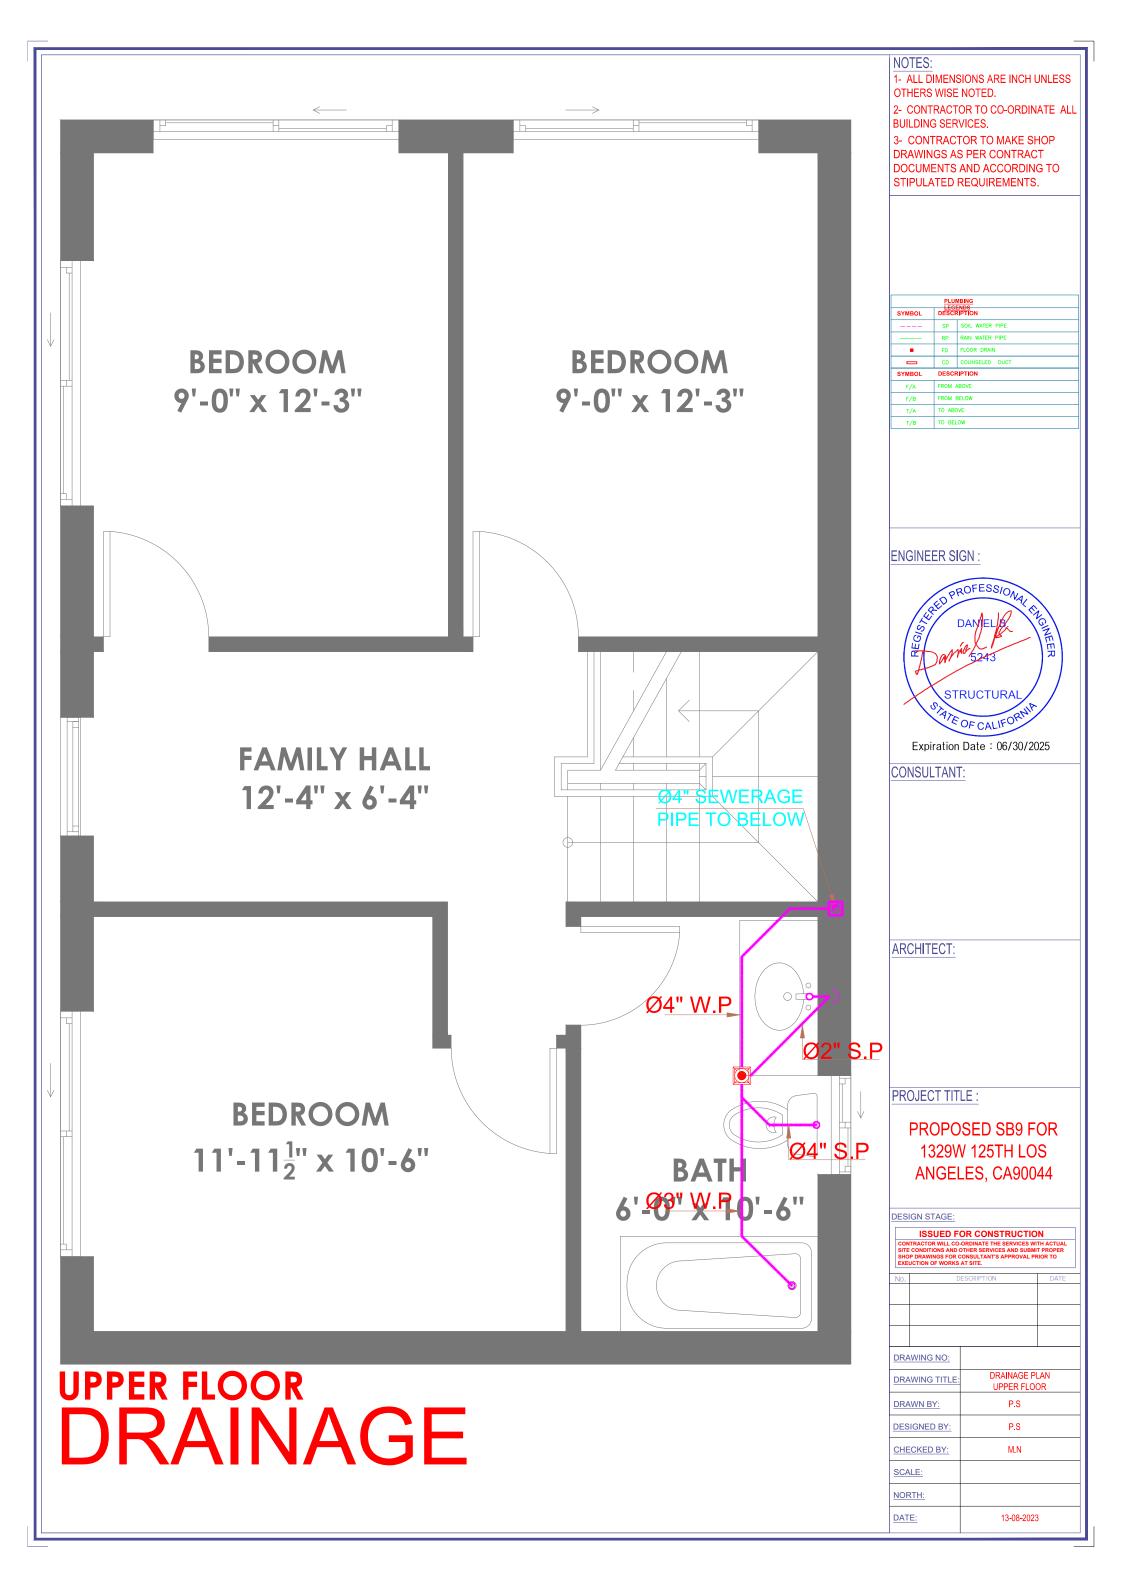

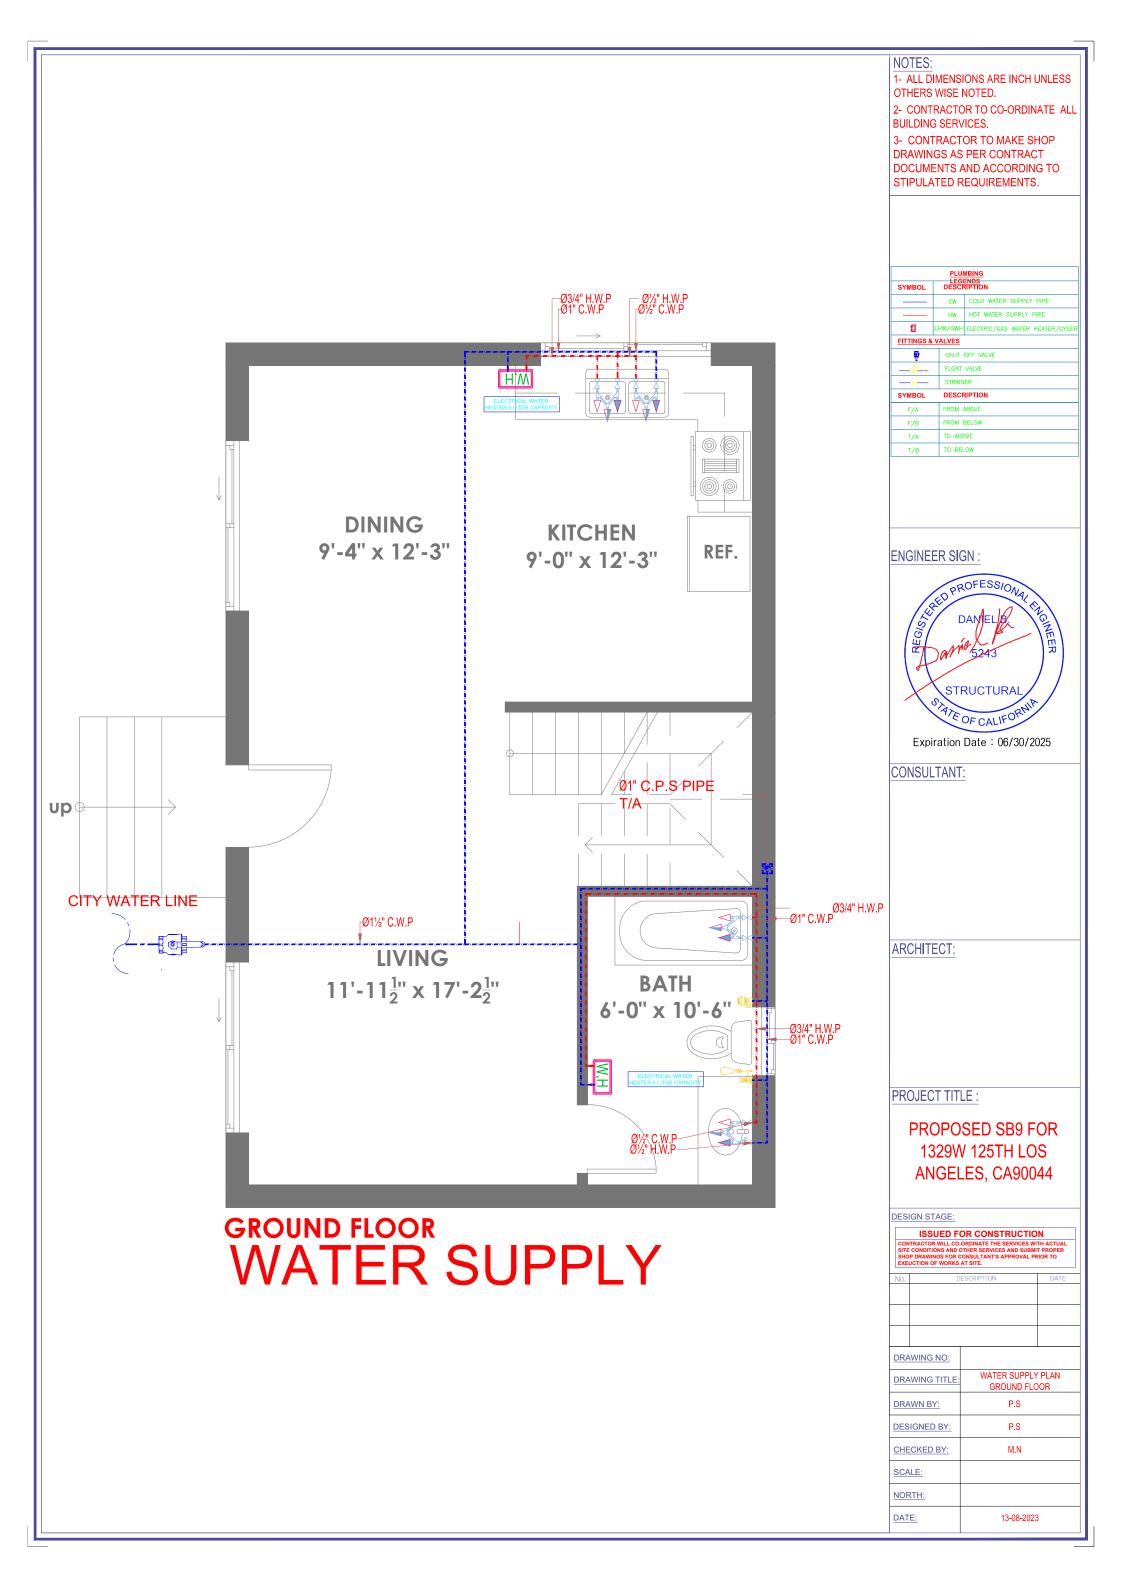

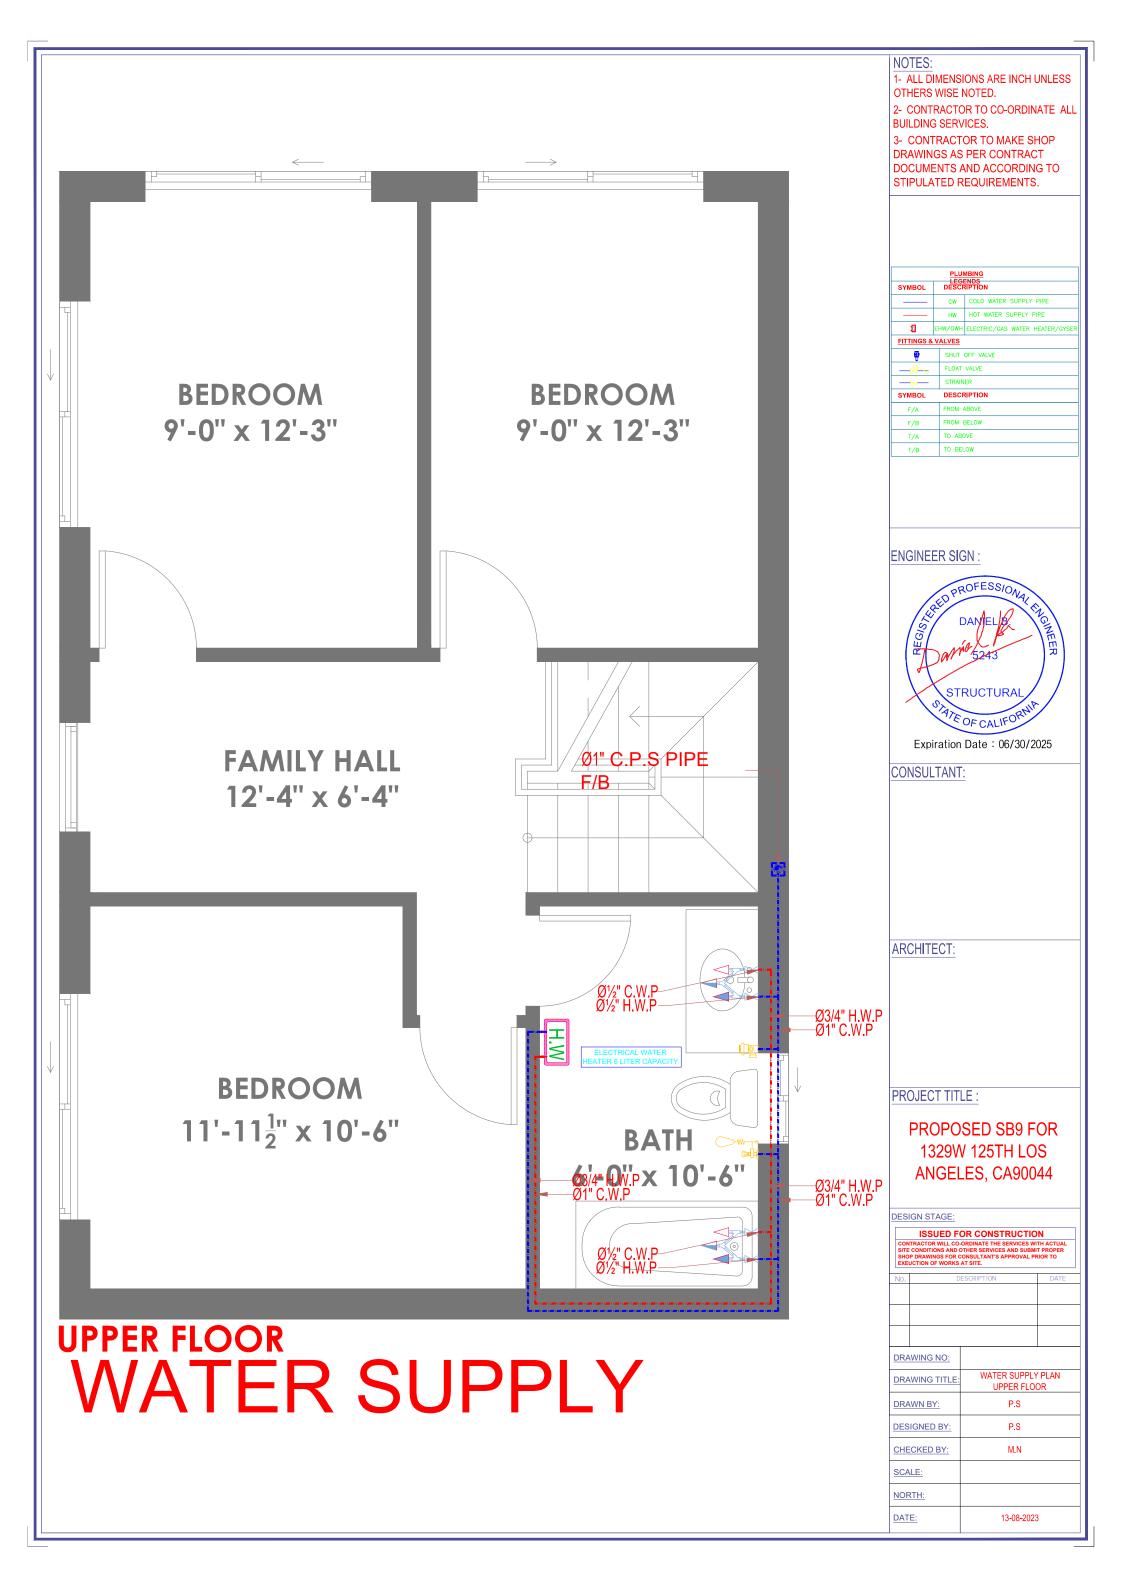

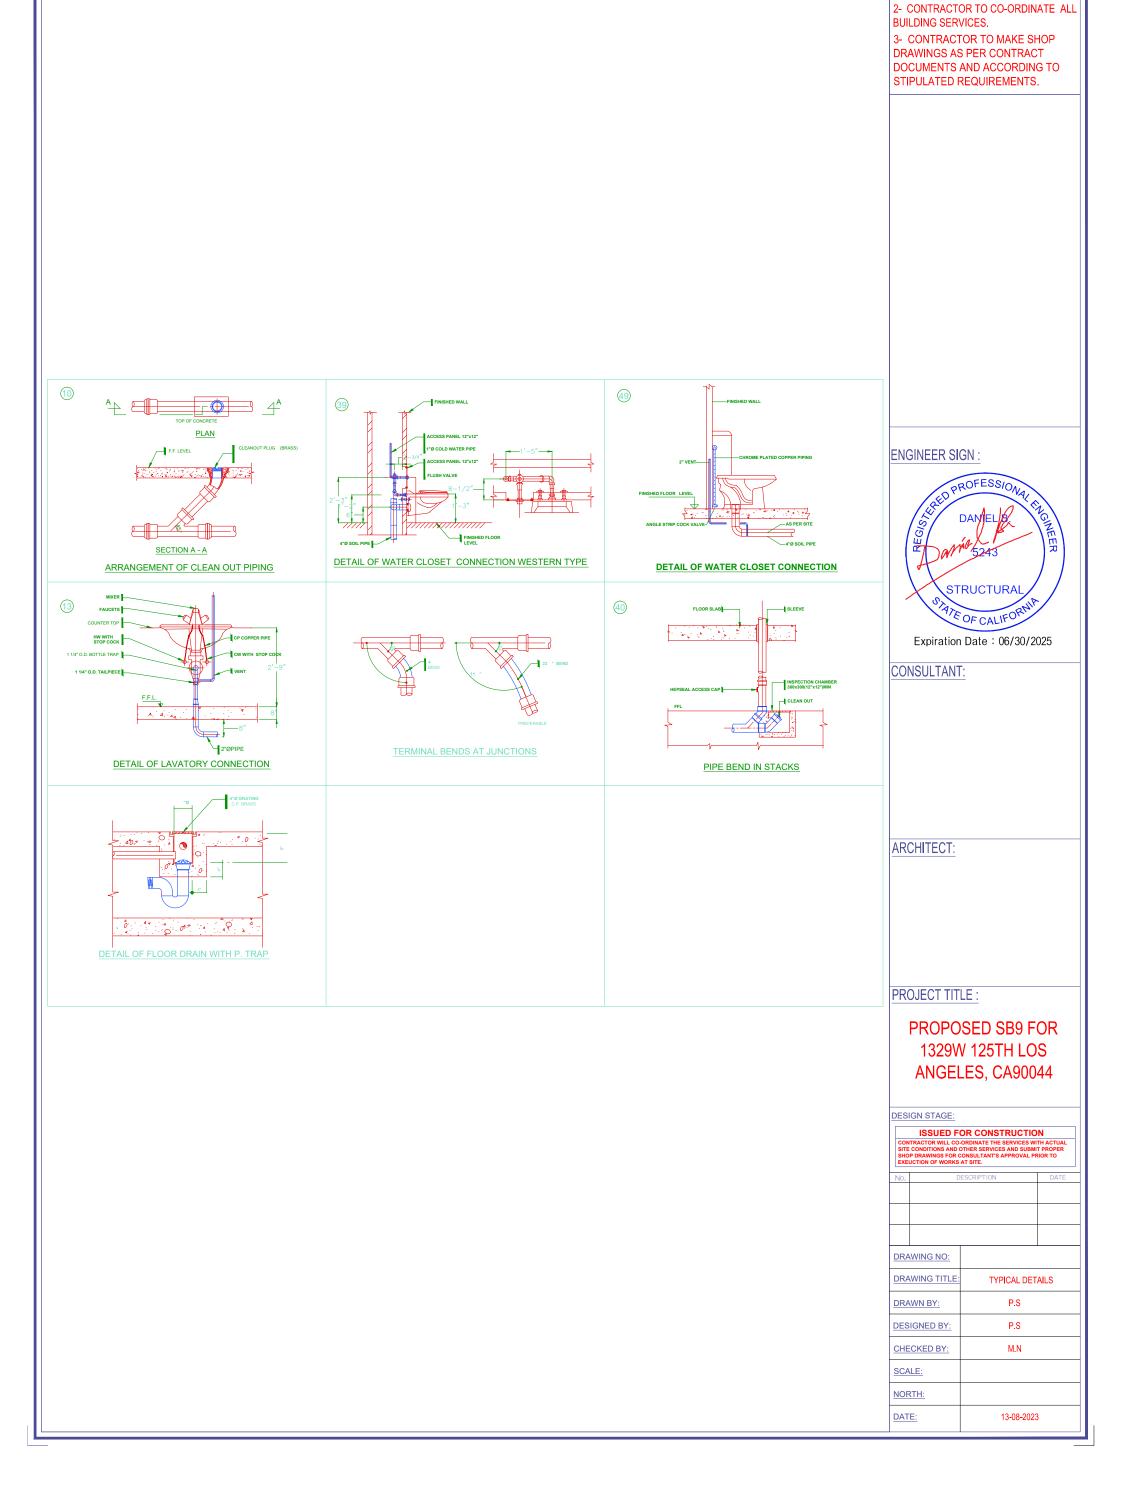

NOTES:

OTHERS WISE NOTED.

1- ALL DIMENSIONS ARE INCH UNLESS