



ENGINEER'S TEAM LTD

Web site: www.engrteam.com
Email: support@engrteam.com

CLIENT: MR AND MRS ANDERTON

ADDRESS: 25 WILBURY AVENUE,
HOVE, BN3 6HS

CONFIDENTIALITY STATEMENT:
ALL DRAWINGS AND WRITTEN MATERIALS
APPEARING HEREIN CONSTITUTE THE
ORIGINAL AND UNPUBLISHED WORK OF THE
DESIGNER AND THE SAME MAY NOT BE
DUPLICATED, USED OR DISCLOSED WITHOUT
CONSENT OF THE DESIGNER.

NOTES:
1. ALL DIMENSIONS HEREIN ARE IN IMPERIAL
UNITS UNLESS STATED OTHERWISE.
2. THESE DRAWINGS ARE TO BE READ IN
CONJUNCTION WITH ALL RELEVANT DESIGNER,
ENGINEER OR SPECIALIST DRAWINGS AND
SPECIFICATIONS.
3. THE CONTRACTOR MUST CHECK ALL
DIMENSION AT SITE BEFORE COMMENCING
WORK.
4. THE CONTRACTOR IS RESPONSIBLE FOR
PROVIDING ALL NECESSARY TEMPORARY
SUPPORT TO THE BUILDING AND ANY ADJACENT
STRUCTURES.

REFERENCE:
0146-ETE-110CS-GF-R-MEP-001,
0146-ETE-110CS-GF-DR-E-40802 (Rev00)

REV. NO.	DESCRIPTION	DATE	BY
01	Add Grease Trap & update the plumbing plans	03/02/26	AA
02	Create leak detection, Gas & Fire protection etc plans	06/27/26	AA
03	Fix HVAC system and add new system	07/21/26	AA
04	Change VRF system & Fix Ventilation	07/27/26	AA
05	Provide more information about the HVAC system	08/04/26	AA
05	HVAC Elevation Plan & Filtrations Specification.	08/16/26	AA

PROJECT: 25 WILBURY AVENUE		
TITLE: PROPOSED ELECTRICAL LAYOUT PLAN		
PROJ. NO.	PROJ. ENGR.	SCALE @ 24X36: 1:100
DATE : September 14, 2026		
DRAWING NO. E - 1	REV. 6	

Electrical Layout Plan

Scope & Compliance

This Electrical Layout Plan has been prepared for 110 Cannon Street, London, EC4N 6EU, United Kingdom. The design and documentation of all electrical distribution systems, circuits, protective devices, earthing and bonding arrangements, panelboards, cabling, lighting, power outlets, and associated components are provided in accordance with all applicable updated codes, statutory rules, guidelines, and product approval requirements enforced by the relevant UK regulatory authorities and the Authority Having Jurisdiction (AHJ) in London.

Governing Codes & Standards

All electrical design, installation, verification, and safety requirements referenced in this plan are based on the following current UK standards and regulatory frameworks:

- British Standard BS 7671:2018 + Amendment 3 (18th Edition) — "Requirements for Electrical Installations (IET Wiring Regulations)" — the national standard governing the design, installation, inspection, testing and maintenance of electrical installations in the UK, covering circuits up to and including 1000 V AC and 1500 V DC across domestic, commercial, and industrial premises. The current consolidated edition and its latest amendments form the basis of design criteria, protective measures, and safety compliance.
- Electricity at Work Regulations 1989 — requiring that all electrical systems are designed and maintained to prevent danger and risk of injury or fire. Compliance with BS 7671 is recognised as demonstrating adherence to these statutory safety obligations.
- UK Building Regulations (including Part P where applicable) — binding requirements that electrical installations in buildings must meet minimum safety standards, and for certain work may require notification or approval from Building Control or a Competent Person Scheme.
- Statutory and Local Authority Requirements — including any London-specific electrical safety ordinances, inspection and certification regimes, and coordination with utility supply standards for connection and metering interfaces.

Product & Equipment Approval — "110 Cannon Street, London, EC4N 6EU, United Kingdom" Product Approval Codes:

- All electrical materials, devices, components, and equipment indicated on this plan—including cables, conduits, consumer units, switchgear, protective devices (MCBs, RCDs, AFDDs), socket outlets, lighting fixtures, earthing systems, and control devices—shall be third-party listed, certified, or approved for UK use with appropriate marking (e.g., UKCA or CE where accepted under transitional arrangements).
- Products shall comply with relevant British Standards, harmonised European standards, or recognised international standards applicable for the intended application, environment and voltage rating.
- Manufacturer technical data sheets, certification, performance ratings and installation instructions for major electrical components shall be submitted for review and approval prior to procurement and installation.
- Any proposed substitution of materials or equipment not explicitly specified on this plan shall be submitted in writing for review and written approval by the design professional and the AHJ prior to implementation.
- Products not meeting the mandated approval criteria shall not be installed; the AHJ reserves the right to reject any equipment or assembly that does not conform to the applicable regulatory framework.

Permitting, Inspection & Certification

- All electrical works shall be carried out under a valid electrical installation notification or permit, as required by the relevant Building Regulations, Competent Persons Scheme, or local authority inspection regime.
- Staged inspections (e.g., initial, intermediate/rough-in, and final testing) shall be arranged with the AHJ or approved scheme body. Certification documents, including Electrical Installation Certificates and schedules of test results, shall be completed in accordance with BS 7671 model forms or equivalent approved formats.
- Only qualified and competent persons (registered electricians and installers recognised under the applicable UK schemes) shall perform electrical installation, testing and certification tasks.

Design & Installation Criteria / Field Coordination

- The electrical system has been designed with correct conductor sizing, breaker coordination, earth fault loop impedance values, voltage drop limits, segregation of circuits, protective device selection, and compliance with BS 7671's requirements for safety, performance and durability.
- Earthing and bonding arrangements, protective conductor sizes and installation practices are designed to mitigate shock and fire hazards, in accordance with BS 7671 protective provisions and relevant statutory requirements.
- Special locations (e.g., wet areas, external circuits, EV charging points) are provided with additional protection measures as required by BS 7671 and recognised best practice guidance.
- Product placement, access for maintenance, clearances around switchgear, and coordination with other building services (mechanical, plumbing, fire protection, telecommunications) shall be verified on site by the installing contractor.

Testing, Commissioning & Documentation

- Prior to energisation, all circuits shall be tested (continuity, insulation resistance, polarity, loop impedance, RCD operation, functional checks) in accordance with BS 7671 requirements and recorded on appropriate test schedules.
- Any deviations discovered during testing shall be rectified and re-tested before final certification.
- Final documentation—including as-built drawings, test results, installation certificates, and product submittals—shall be compiled and provided to the owner and AHJ as part of the project completion package.

Deviations, Clarifications & Field Changes

- Any proposed deviation from this approved layout plan or from the referenced codes and standards shall be documented and submitted in writing for review and written approval from both the design professional and the AHJ before any modification is carried out in the field.

Contractor Responsibility & Limitation of Design Liability


- This Electrical Layout Plan and accompanying notes constitute design and permit documentation only; the contractor is responsible for ensuring that all electrical installations, field conditions, means and methods, safety practices, and coordination with other trades meet the requirements of applicable codes, regulations and manufacturer instructions. The design professional's liability is limited to the design scope; final compliance is subject to inspection, certification and acceptance by the AHJ.


RCP's Legend

WALL LIGHT 10W	3-GANG ROCKERY SWITCH
ADJUSTABLE FRAME RECESSED DOWNLIGHT 10W	2-GANG ROCKERY SWITCH
30W CEILING MOUNT SANDAL LIGHT	SINGLE GANG ROCKERY SWITCH
10W CEILING MOUNT SANDAL LIGHT	SMOKE DETECTOR
40W CEILING MOUNT FLOWER SANDAL LIGHT	EXTRACT FAN 40W
IP RATED RECESSED DOWNLIGHT 20W	LINEAR LED STRIP
CCTV CONTROL PANEL	AV BOX
FIRE PROTECTION CONTROL PANEL	ELECTRICAL WIRE
MAIN PANEL	10W SPOT LIGHT
IA PCD SUPERVISOR	PCD1 PLANT CONTROLLER
SBC CONTROLLER	MODBUS

Important Note:

- The consumer unit is currently located where there used to be a leak. It is now being proposed to move to another wall on the side.

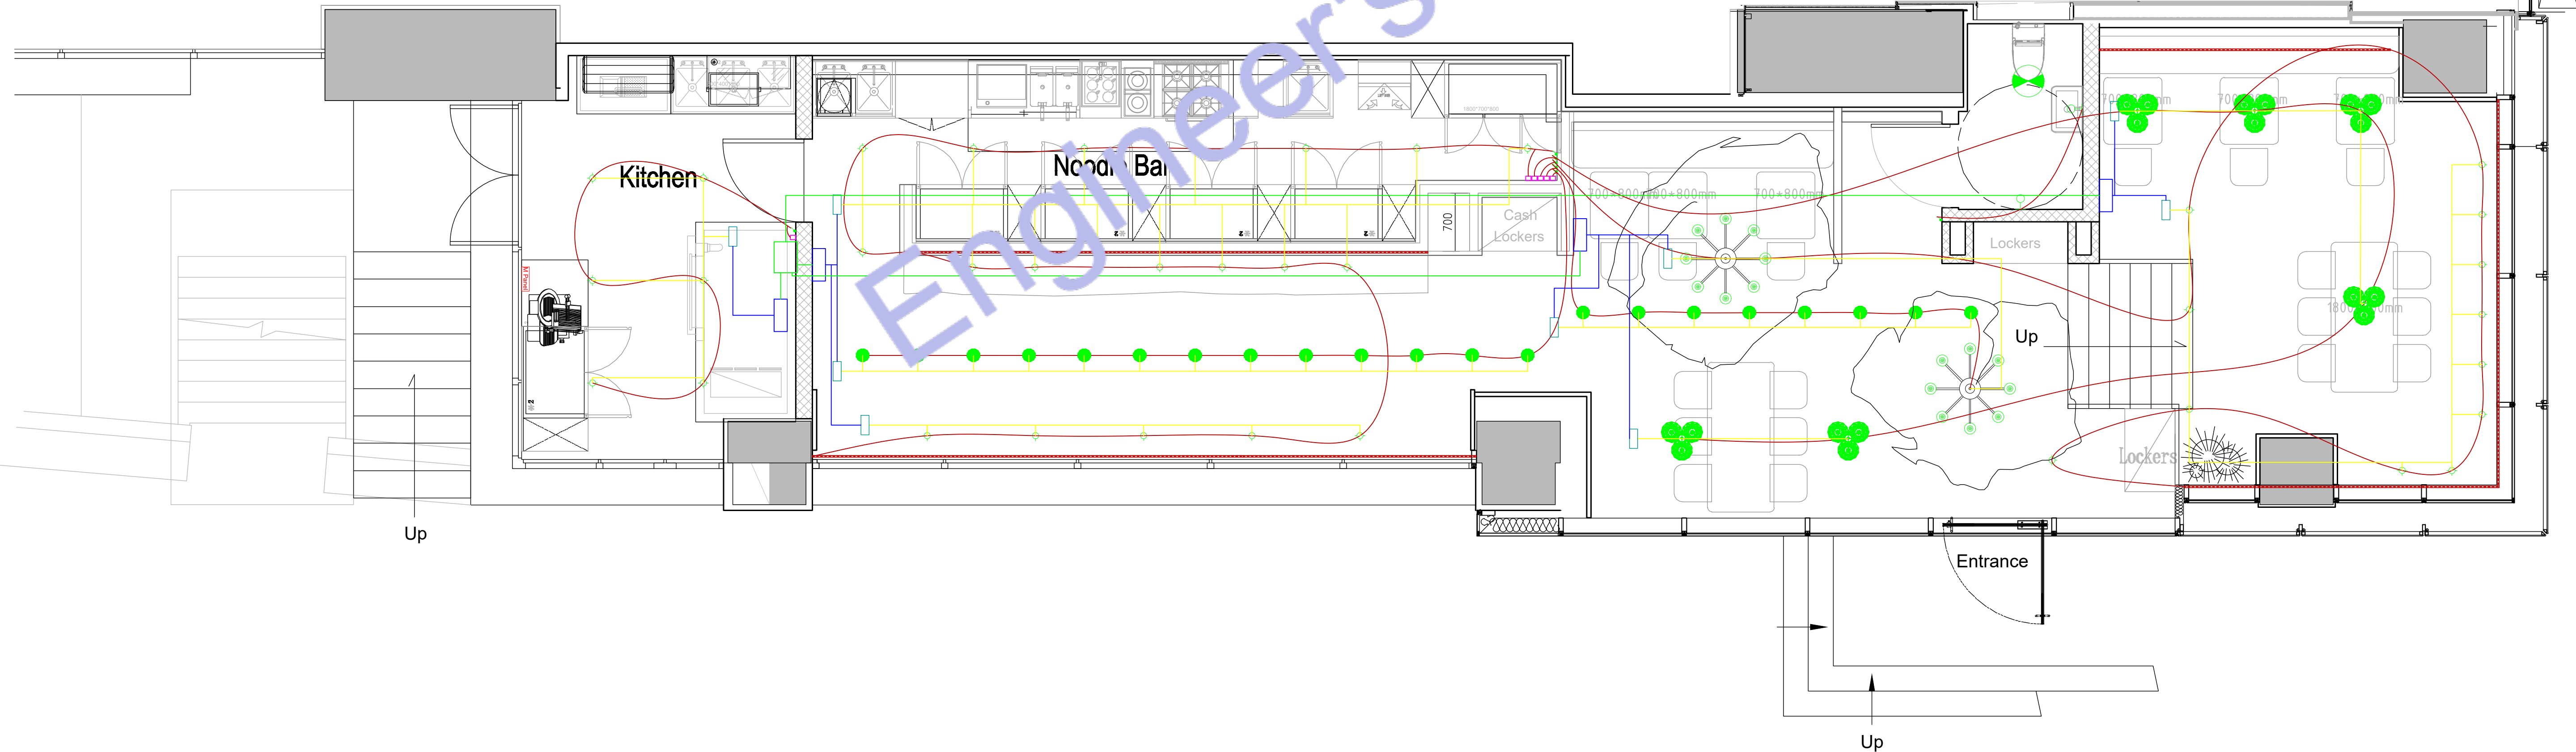

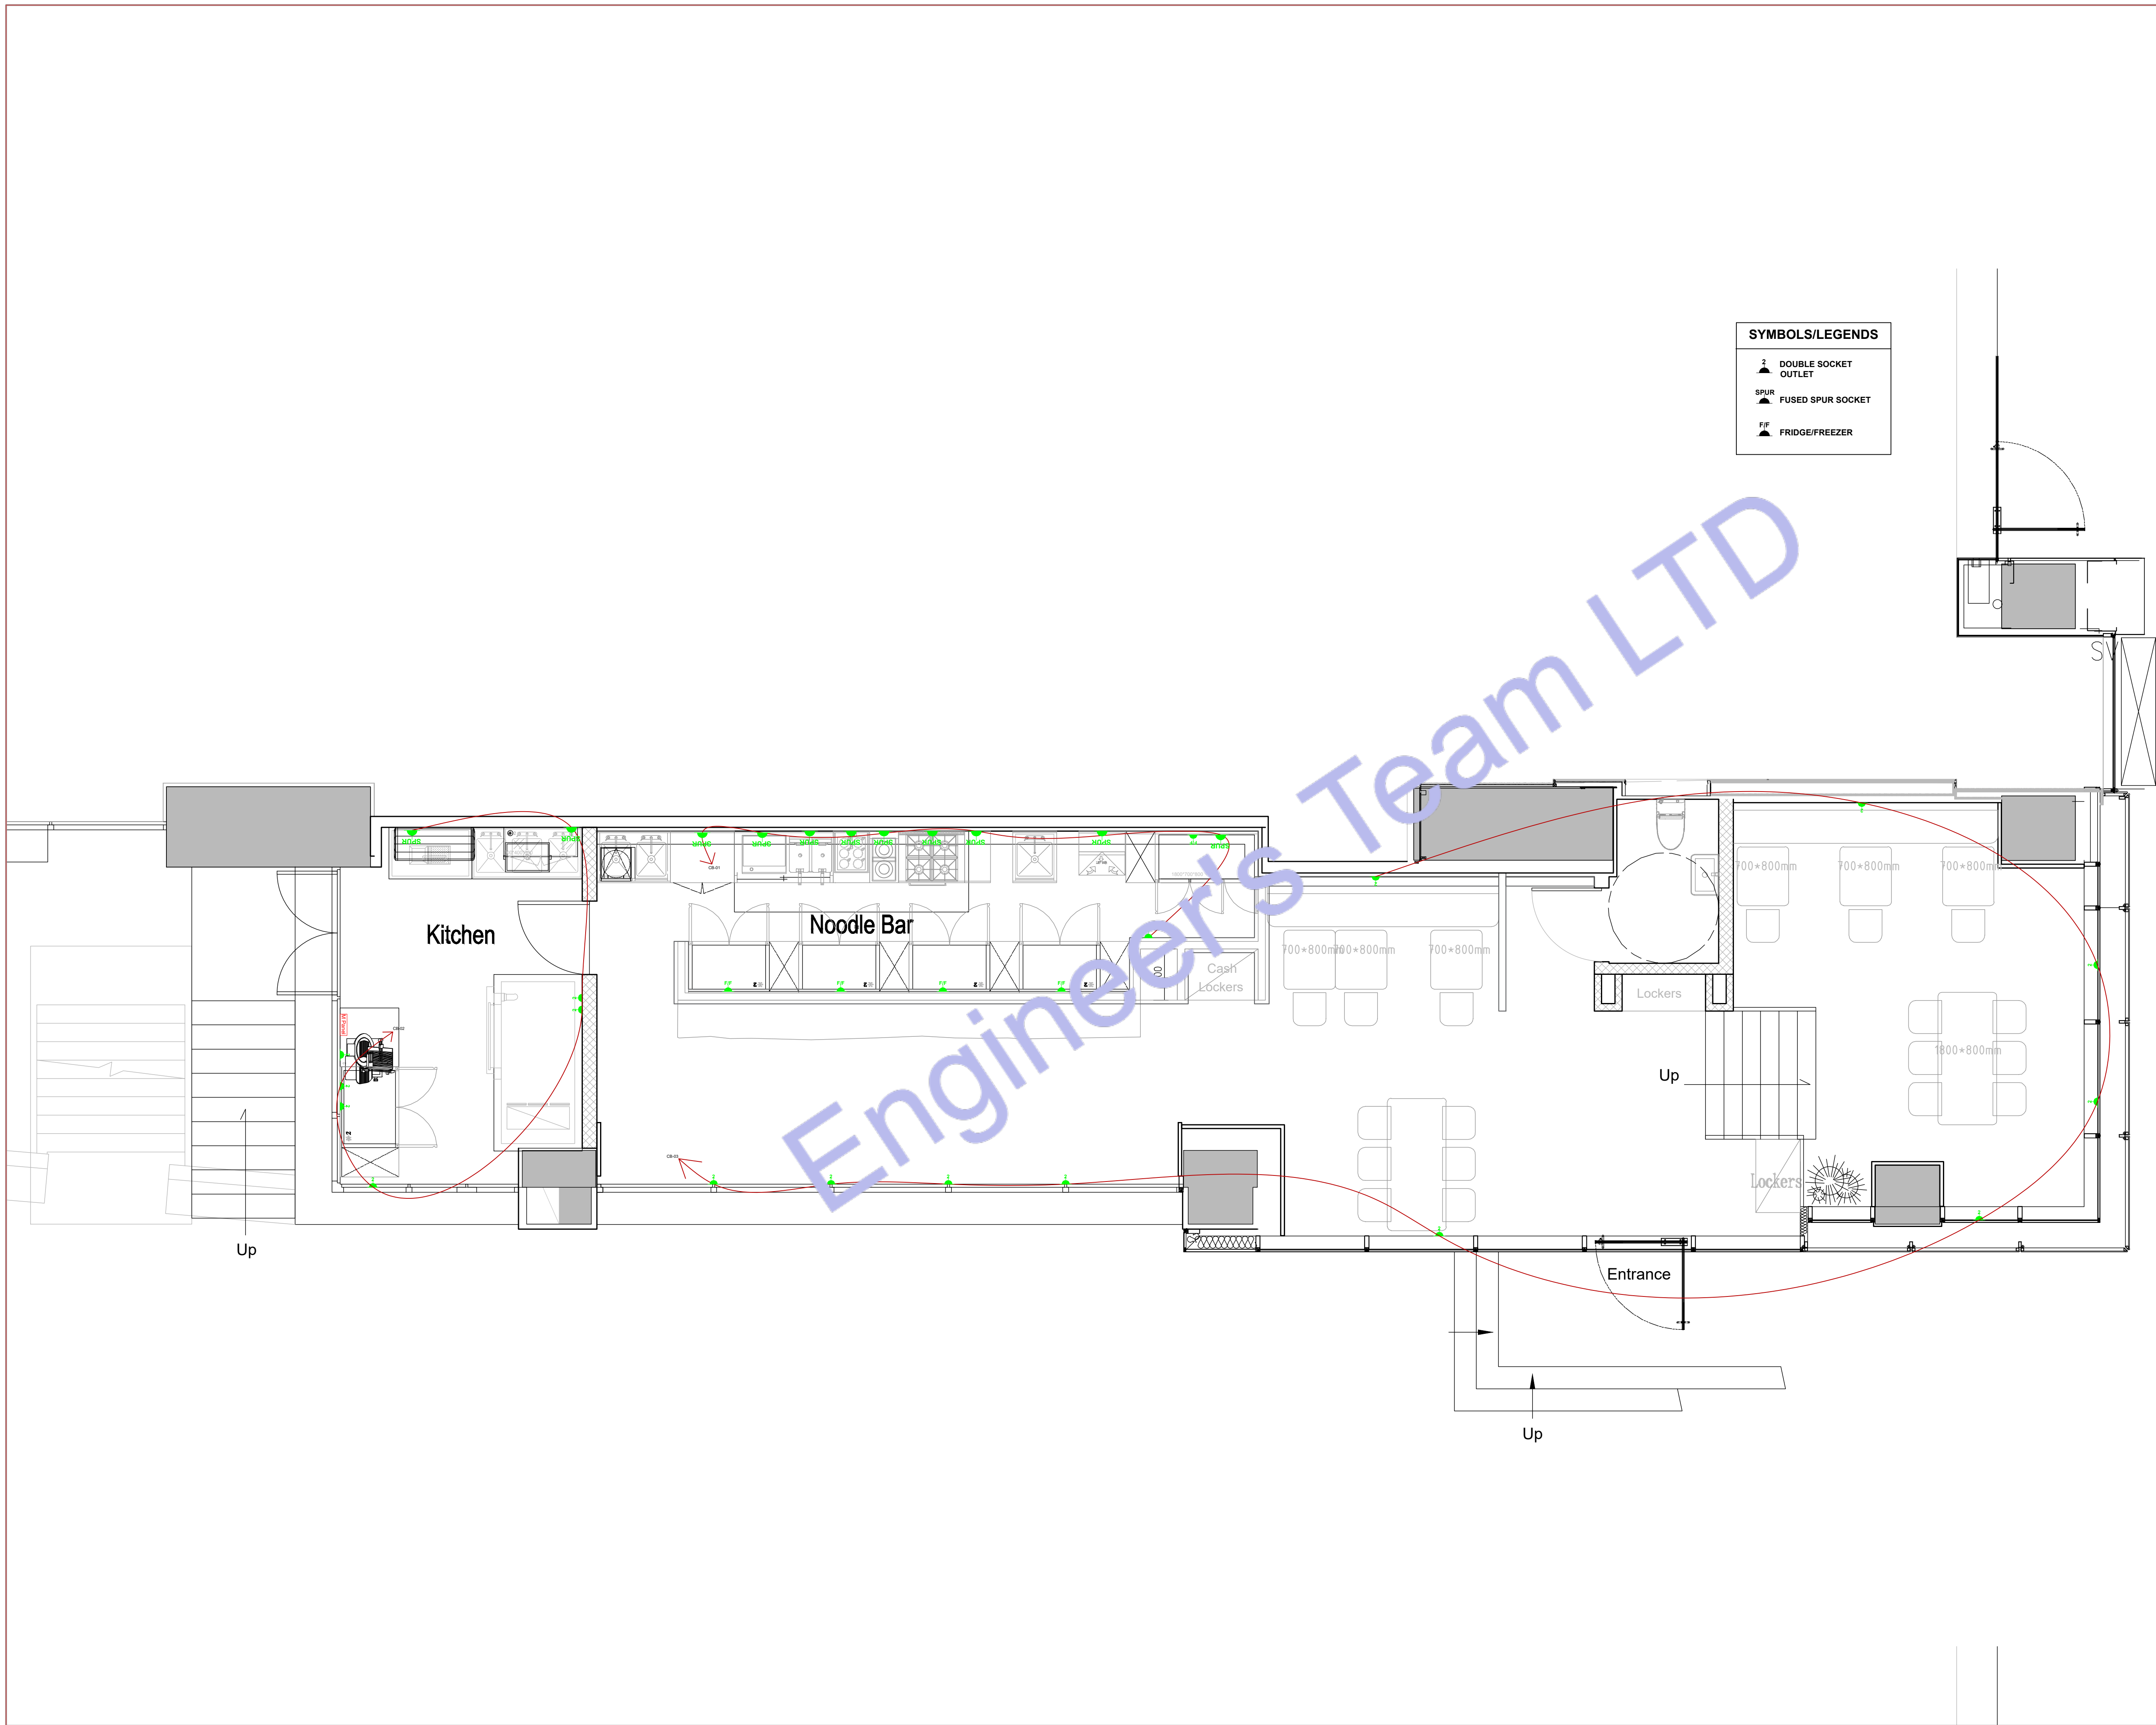

SYMBOLS/LEGENDS	
	DOUBLE SOCKET OUTLET
	FUSED SPUR SOCKET
	FRIDGE/FREEZER



ENGINEER'S TEAM LTD
Web site: www.engrteam.com
Email: support@engrteam.com

CLIENT: MR AND MRS ANDERTON

ADDRESS:
25 WILBURY AVENUE,
HOVE, BN3 6HS

CONFIDENTIALITY STATEMENT:
ALL DRAWINGS AND WRITTEN MATERIALS
APPEARING HEREIN CONSTITUTE THE
ORIGINAL AND UNPUBLISHED WORK OF THE
DESIGNER AND THE SAME MAY NOT BE
DUPLICATED, USED OR DISCLOSED WITHOUT
CONSENT OF THE DESIGNER.

NOTES:
1. ALL DIMENSIONS HEREIN ARE IN IMPERIAL
UNITS UNLESS STATED OTHERWISE.
2. THESE DRAWINGS ARE TO BE READ IN
CONJUNCTION WITH ALL RELEVANT DESIGNER,
ENGINEER OR SPECIALIST DRAWINGS AND
SPECIFICATIONS.
3. THE CONTRACTOR MUST CHECK ALL
DIMENSION AT SITE BEFORE COMMENCING
WORK.
4. THE CONTRACTOR IS RESPONSIBLE FOR
PROVIDING ALL NECESSARY TEMPORARY
SUPPORT TO THE BUILDING AND ANY ADJACENT
STRUCTURES.

REFERENCE:
0146-ETE-110CS-GF-R-MEP-002,
0146-ETE-110CS-GF-DR-E-40802 (Rev00)

REV. NO.	DESCRIPTION	DATE	BY
01	Add Grease Trap & update the plumbing plans	03/02/26	AA
02	Create leak detection, Gas & Fire protection etc plans	06/27/26	AA
03	Fix HVAC system and add new system	07/21/26	AA
04	Change VRF system & Fix Ventilation	07/27/26	AA
05	Provide more information about the HVAC system	08/04/26	AA
05	HVAC Elevation Plan & Filtrations Specification.	08/16/26	AA

PROJECT: 25 WILBURY AVENUE

TITLE: PROPOSED POWER LAYOUT PLAN


PROJ. NO.	PROJ. ENGR.	SCALE @ 24X36: 1:100
-----------	-------------	-------------------------

DATE : September 14, 2026

DRAWING NO. E - 2	REV. 6
----------------------	-----------

MAIN PANEL																			
Panel Location-																			
Voltage (Phase-Ground/Phase-Phase)		230	400	Source of Supply-From Service Disconnect/Meter															
Phase-		1		Wire-			3												
Rated Amps-		125		AIC-			10k												
MCCB		125 Amps MCCB		Mounting-			Wall Surface												
Circuit	Description	New/ Existing	Load Type	Breaker Size	Poles	Wire Size	A	B	C	Wire Size	Poles	Breaker Size	Load Type	New/ Existing	Description	Circuit			
1	All Loads	N	SPD	125	3	50	20945	20945					50	3	125	RCD	N	All Loads	2
3						50			36181	36181			50						4
5						50					25855	25855	50						6
7	LIGHTNING LOADS	N	MCB, Type-B	10	1	1.5	830	5167					6	3	25	MCB, Type-B	N	HVAC VRF	8
9	GLASS WASHER	N	MCB, Type-B	20	1	2.5			2500	5167			6						10
11	STABLETOP DOUBLE TANK FRYER	N	MCB, Type-B	25	1	2.5					5000	5167	6						12
13	DOUBLE HEAD INDUCTION CLAYPOT STOVE	N	MCB, Type-B	20	3	2.5	2335	3335					2.5	3	20	MCB, Type-B	N	FOUR BURNER COOKING RANGE WITH OVEN	14
15						2.5			2335	3335			2.5						16
17						2.5					2335	3335	2.5						18
19	TABLE TOP ELECTRIC GRIDDLE	N	MCB, Type-B	20	3	2.5	2000	2000					2.5	3	20	MCB, Type-B	N	SIX-BASKET FL FCTRIC NOODEF COOKER	20
21						2.5			2000	2000			2.5						22
23						2.5					2000	2000	2.5						24
25	WATER HEATER	N	MCB, Type-B	20	3	2.5	2000	300					2.5	1	20	MCB, Type-B	N	SUCER	26
27						2.5			2000	1000			2.5	1	20	MCB, Type-B	N	REFRIGERATOR 2	28
29						2.5					2000	1000	2.5	1	20	MCB, Type-B	N	REFRIGERATOR 4	30
31	REFRIGERATOR 1	N	MCB, Type-B	20	1	2.5	1000	1000					2.5	1	20	MCB, Type-B	N	REFRIGERATOR 6	32
33	REFRIGERATOR 3	N	MCB, Type-B	20	1	2.5			1000	750			2.5	1	20	MCB, Type-B	N	CB-01	34
35	REFRIGERATOR 5	N	MCB, Type-B	20	1	2.5					1000	750	2.5	1	20	MCB, Type-B	N	CB-02	36
37	HOOD EXHAUST	N	MCB, Type-B	20	4	2.5	68	442					2.5	1	20	MCB, Type-B	N	HVAC MVHR	38
39						2.5			68	26			2.5	1	20	MCB, Type-B	N	FRONT DINING AREA EXTRACTOR FAN	40
41						2.5					68	1200	2.5	1	20	MCB, Type-B	N	CB-03	42
43						2.5	68	400					2.5	1	20	MCB, Type-B	N	EXTRACT FANS, ALL LV SYSTEMS	44
45	CASSETTE INDOOR UNIT-1	N	MCB, Type-B	35	1	6			7000	7000			6	1	35	MCB, Type-B	N	CASSETTE INDOOR UNIT-2	46
							B		C		Total								
Connected Load (W)							20945		36181		25855		82981						
Connected Amps							119.78												
Main Type and Amps Rating							125 Amps MCCB												

Demand Load Calculation			
Load Classification	Connected Load	Demand Factor	Estimated Demand
Lighting - Commercial Unit	830	125%	1037.5
Water Heater - Commercial Unit	6000	100%	6000
Receptacle	46250	65%	30062.5
Cooling	15501	100%	15501
Pump	0	125%	0
Other	0	100%	0
Demand Load	68581		52601
Demand Amps			76.23333333

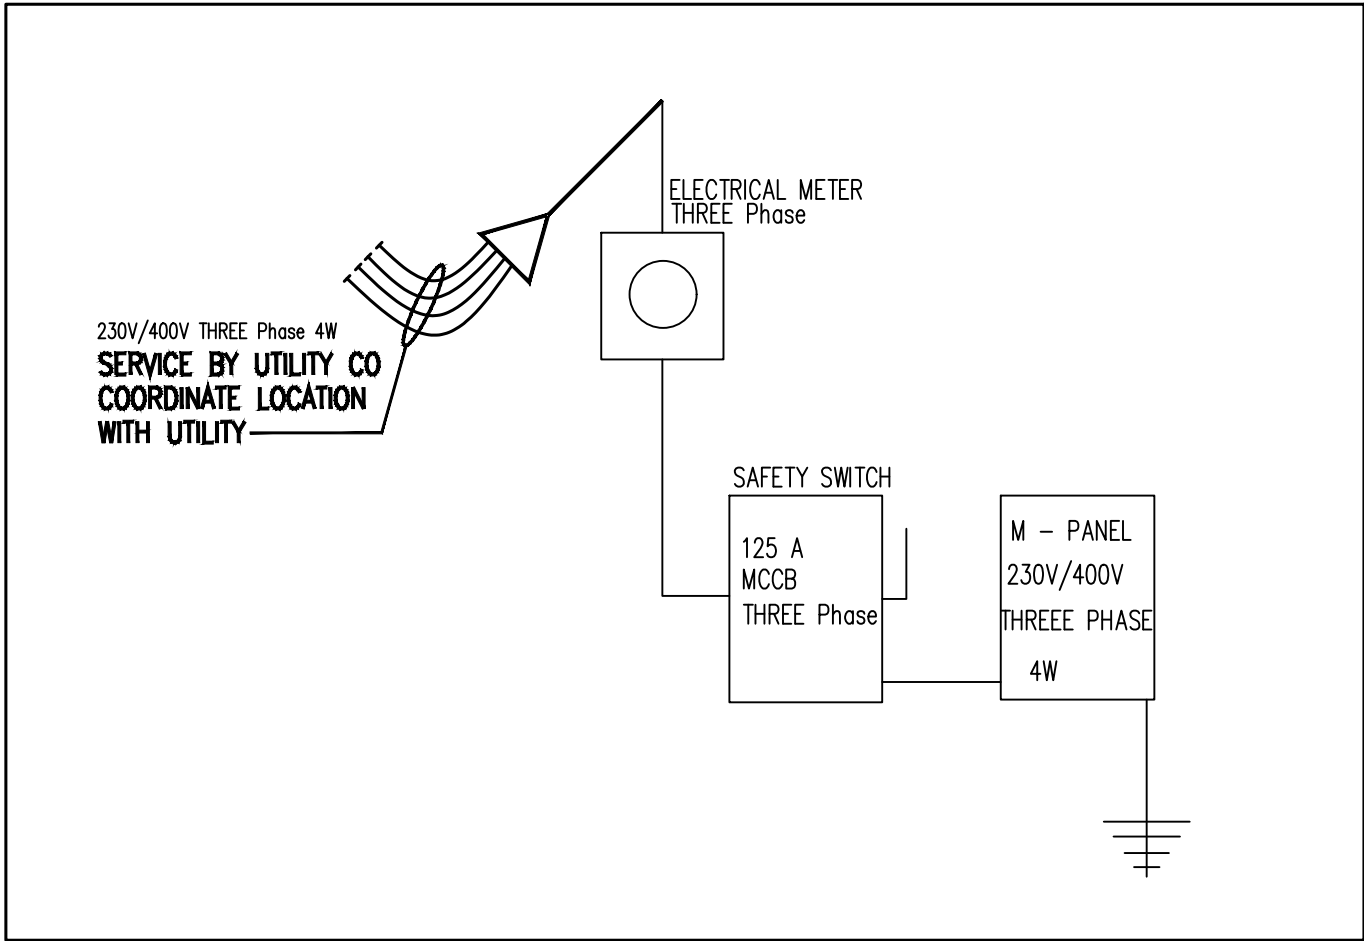



ENGINEER'S TEAM LTD
Web site: www.engrteam.com
Email: support@engrteam.com

CLIENT: MR AND MRS ANDERTON

ADDRESS: 25 WILBURY AVENUE, HOVE, BN3 6HS

CONFIDENTIALITY STATEMENT:
ALL DRAWINGS AND WRITTEN MATERIALS APPEARING HEREIN CONSTITUTE THE ORIGINAL AND UNPUBLISHED WORK OF THE DESIGNER AND THE SAME MAY NOT BE DUPLICATED, USED OR DISCLOSED WITHOUT CONSENT OF THE DESIGNER.

NOTES:
1. ALL DIMENSIONS HEREIN ARE IN IMPERIAL UNITS UNLESS STATED OTHERWISE.
2. THESE DRAWINGS ARE TO BE READ IN CONJUNCTION WITH ALL RELEVANT DESIGNER, ENGINEER OR SPECIALIST DRAWINGS AND SPECIFICATIONS.
3. THE CONTRACTOR MUST CHECK ALL DIMENSION AT SITE BEFORE COMMENCING WORK.
4. THE CONTRACTOR IS RESPONSIBLE FOR PROVIDING ALL NECESSARY TEMPORARY SUPPORT TO THE BUILDING AND ANY ADJACENT STRUCTURES.

REFERENCE:
0146-ETE-110CS-GF-R-MEP-003,
0146-ETE-110CS-GF-DR-E-40802 (Rev00)

REV. NO.	DESCRIPTION	DATE	BY
01	Add Grease Trap & update the plumbing plans	03/02/26	AA
02	Create leak detection, Gas & Fire protection etc plans	06/27/26	AA
03	Fix HVAC system and add new system	07/21/26	AA
04	Change VRF system & Fix Ventilation	07/27/26	AA
05	Provide more information about the HVAC system	08/04/26	AA
05	HVAC Elevation Plan & Filtrations Specification.	08/16/26	AA


PROJECT: 25 WILBURY AVENUE

TITLE: **ELECTRICAL SCHEDULE**

PROJ. NO.	PROJ. ENGR.	SCALE @ 24X36: 1:100
-----------	-------------	----------------------

DATE : September 14, 2026

DRAWING NO. E - 3	REV. 6
-------------------	--------

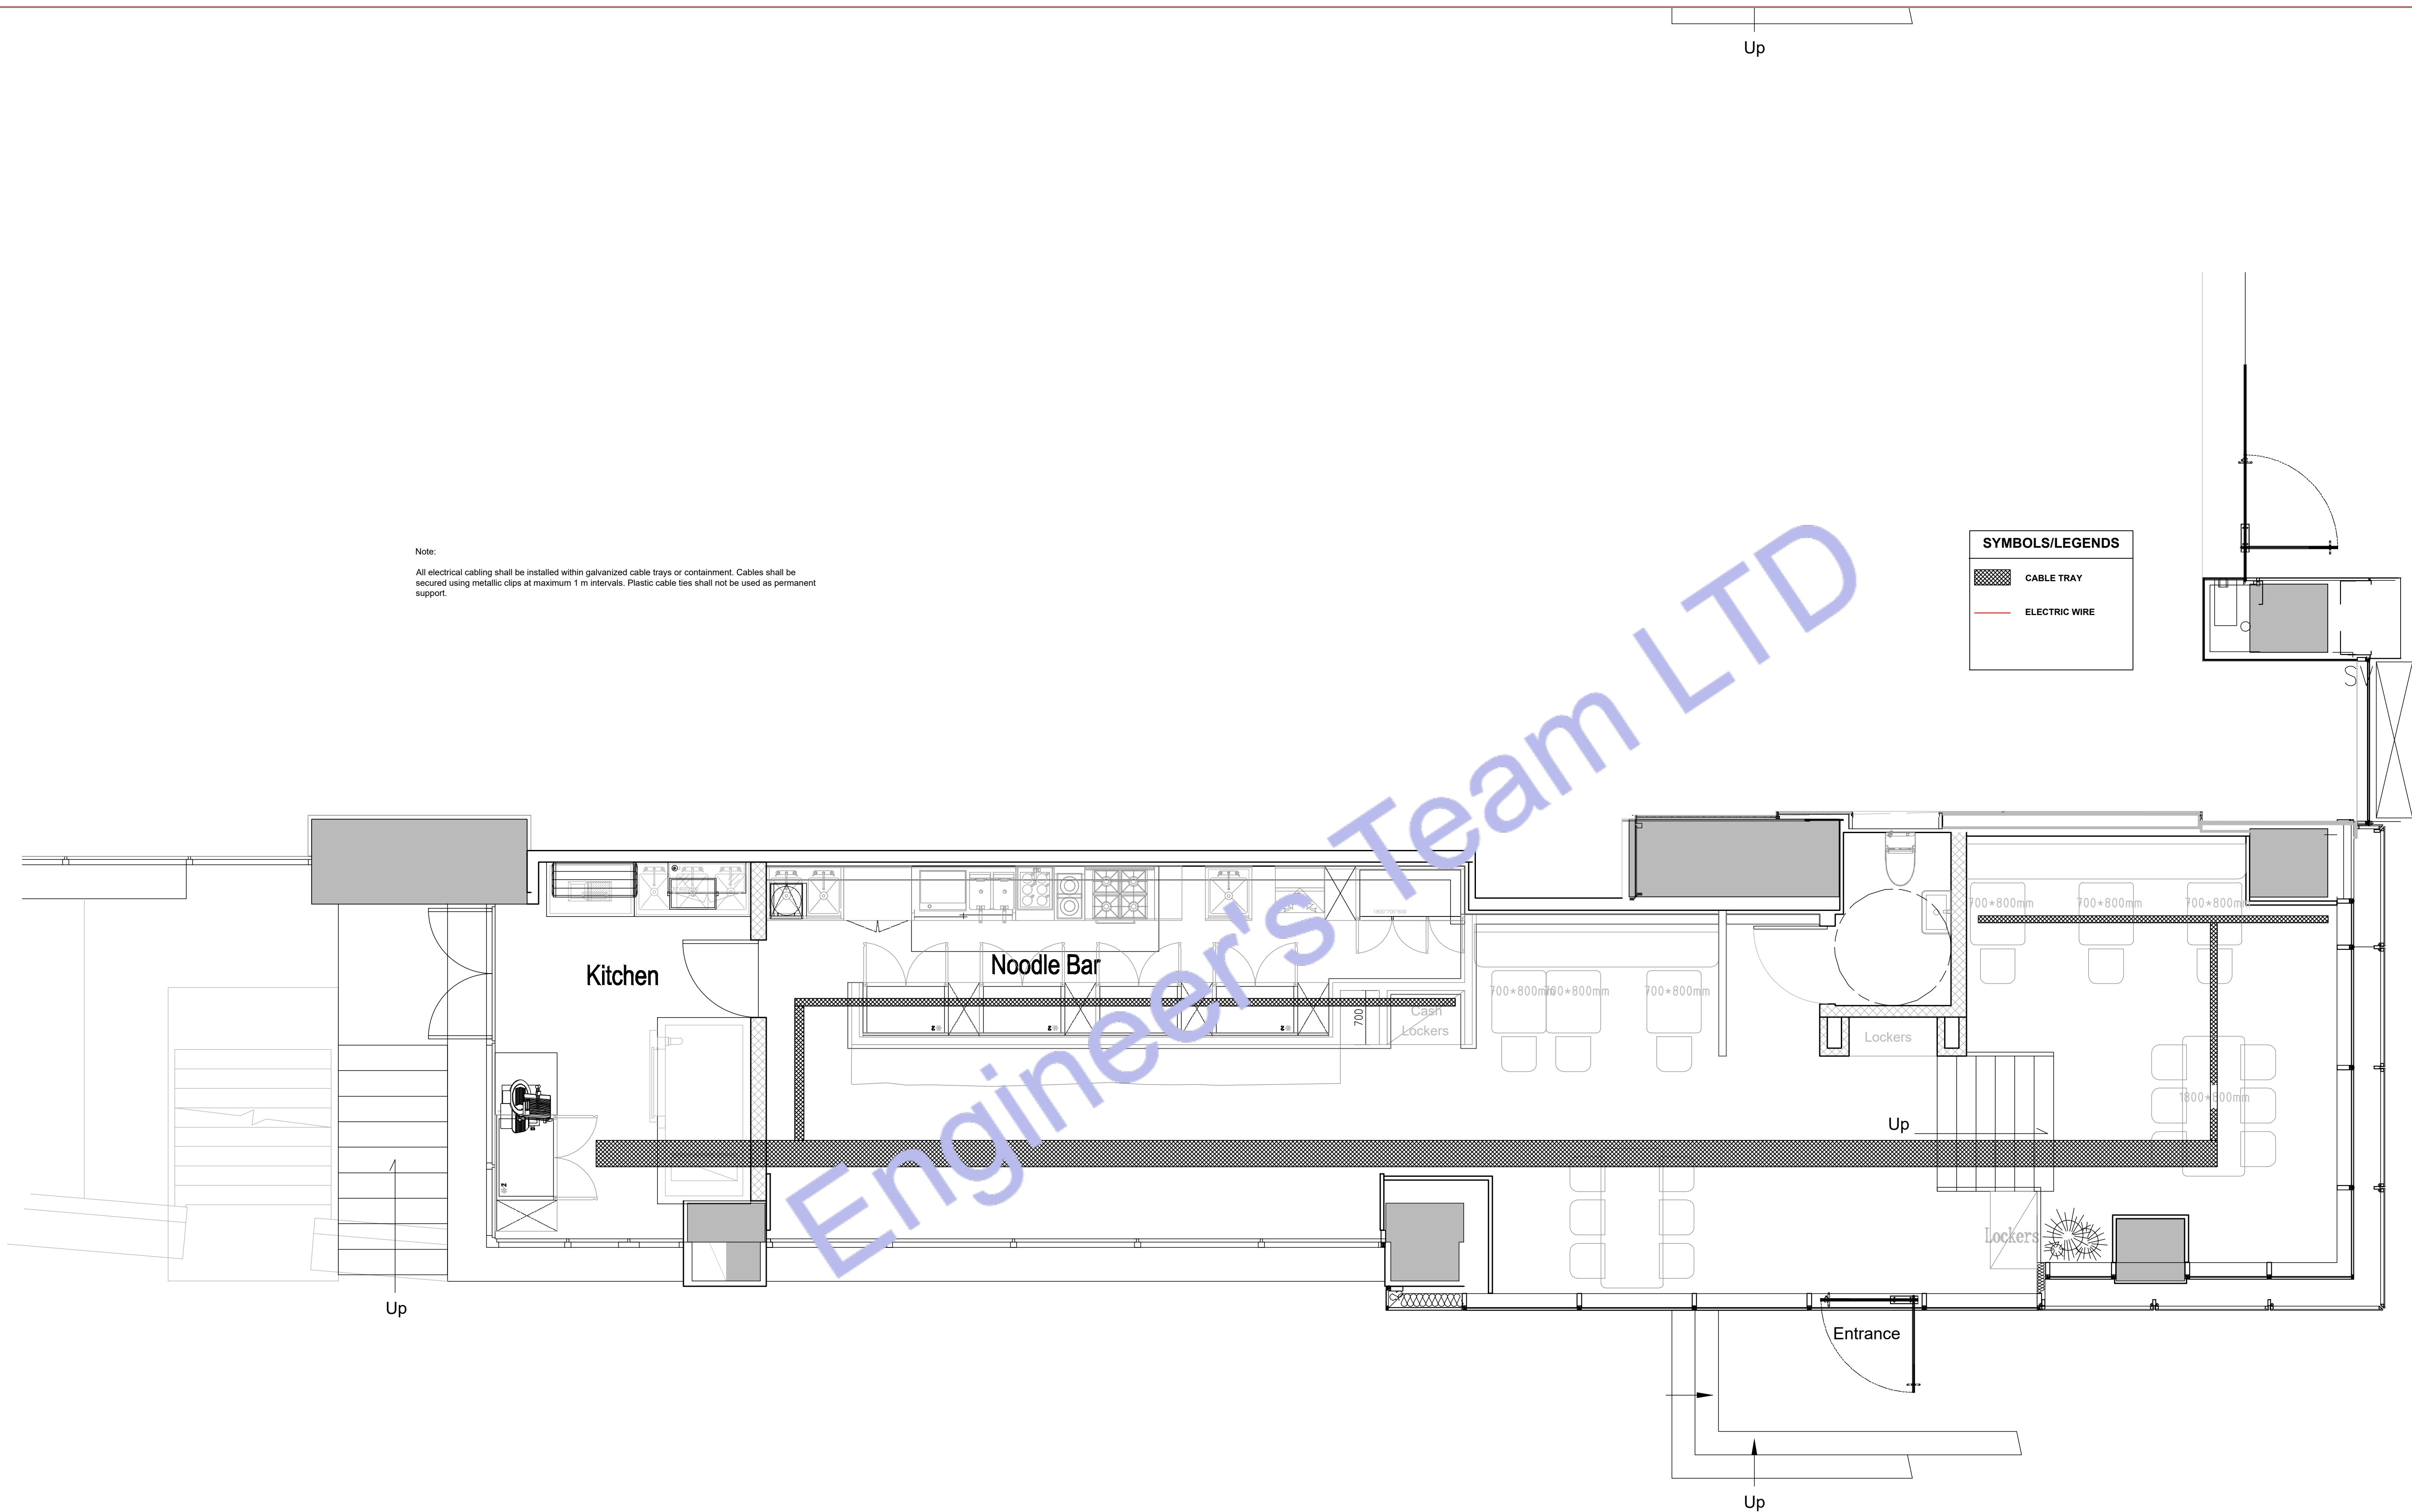

Note:
All electrical cabling shall be installed within galvanized cable trays or containment. Cables shall be secured using metallic clips at maximum 1 m intervals. Plastic cable ties shall not be used as permanent support.

SYMBOLS/LEGENDS

CABLE TRAY

ELECTRIC WIRE



ENGINEER'S TEAM LTD
Web site: www.engrteam.com
Email: support@engrteam.com

CLIENT:

MR AND MRS ANDERTON

ADDRESS:

25 WILBURY AVENUE,
HOVE, BN3 6HS

CONFIDENTIALITY STATEMENT:

ALL DRAWINGS AND WRITTEN MATERIALS
APPEARING HEREIN CONSTITUTE THE
ORIGINAL AND UNPUBLISHED WORK OF THE
DESIGNER AND THE SAME MAY NOT BE
DUPLICATED, USED OR DISCLOSED WITHOUT
CONSENT OF THE DESIGNER.

NOTES:

1. ALL DIMENSIONS HEREIN ARE IN IMPERIAL
UNITS UNLESS STATED OTHERWISE.
2. THESE DRAWINGS ARE TO BE READ IN
CONJUNCTION WITH ALL RELEVANT DESIGNER,
ENGINEER OR SPECIALIST DRAWINGS AND
SPECIFICATIONS.
3. THE CONTRACTOR MUST CHECK ALL
DIMENSION AT SITE BEFORE COMMENCING
WORK.
4. THE CONTRACTOR IS RESPONSIBLE FOR
PROVIDING ALL NECESSARY TEMPORARY
SUPPORT TO THE BUILDING AND ANY ADJACENT
STRUCTURES.

REFERENCE:

0146-ETE-110CS-GF-R-MEP-003,
0146-ETE-110CS-GF-DR-E-40802 (Rev00)

REV. NO.	DESCRIPTION	DATE	BY
01	Add Grease Trap & update the plumbing plans	03/02/26	AA
02	Create leak detection, Gas & Fire protection etc plans	06/27/26	AA
03	Fix HVAC system and add new system	07/21/26	AA
04	Change VRF system & Fix Ventilation	07/27/26	AA
05	Provide more information about the HVAC system	08/04/26	AA
05	HVAC Elevation Plan & Filtrations Specification.	08/16/26	AA

PROJECT:

25 WILBURY AVENUE

TITLE:

ELECTRICAL CABLE TRAY
PLAN

PROJ. NO.	PROJ. ENGR.	SCALE @ 24X36:
		1:100

DATE :

September 14, 2026

DRAWING NO.	REV.
E - 4	6

GENERAL NOTES:

- I. A LISTED INTERSYSTEM BONDING TERMINATION PROVIDING THE REQUIRED NUMBER OF TERMINALS (MINIMUM OF THREE) FOR CONNECTING OTHER BUILDING SYSTEMS TO THE GROUNDING SYSTEM OF THE ELECTRICAL POWER SUPPLY (NEC250.44).

KEY NOTES: (7)(8)


1. ALL METAL CONDUITS ENCLOSING ANY SERVICE SHALL BE FITTED WITH A "BONDING BUSHING".
2. ALL METAL CONDUITS ENCLOSING ANY GROUNDING ELECTRODE CONDUCTOR SHALL BE FITTED WITH A "BONDING BUSHING" AT EACH END.
3. PROVIDE GROUNDING ELECTRODE PER NEC. ELECTRODE SHALL BE IN THE FORM OF A 20'-0" x 1/2" COPPER CLAD GROUND ROD LAID AT LEAST 2" OFF THE BOTTOM OF A CONCRETE FOOTING. SECURE THE GROUND ROD TO THE REBAR WITH STEEL TIE WRAPS. IF THE REBAR BEING USED IN THE FOOTING IS SMALLER THAN 1/2" (#4), THEN USE 20' OF BARE

- SOLID #4 COPPER WIRE IN PLACE OF THE GROUND ROD. IN REMODEL PROJECTS THAT WILL NOT HAVE NEW FOOTINGS INSTALLED, THIS SUPPLEMENTAL ELECTRODE SHALL BE PER NOTE #4 BELOW OR OTHER ELECTRODE PER NEC 250.52.
4. FOR CONNECTION TO COLD WATER MAIN, CONNECT WITHIN 5 FT. OF CONTACT OF EARTH.
5. IF STRUCTURAL STEEL MEMBER OR REBARS ARE AVAILABLE, BOND IT TO THE SERVICE USING A UL LISTED IRREVERSIBLE CLAMP OR WELDING LUG.
6. PROVIDE A INTERSYSTEM BONDING TERMINATION PER NEC 250.94.


- INTERSYSTEM BONDING TERMINATION SHALL:
- 6.1. BE ACCESSIBLE FOR CONNECTION AND INSPECTION.
- 6.2. CONSIST OF A SET OF TERMINALS (LISTED AS GROUNDING AND BONDING EQUIPMENT) WITH THE CAPACITY OF NOT LESS THAN THREE INTERSYSTEM BONDING CONDUCTORS.
- 6.3. BE SECURELY MOUNTED AND ELECTRICALLY CONNECTED TO SERVICE EQUIPMENT, METER ENCLOSURE, OR EXPOSED NON METALLIC SERVICE RACEWAY, OR BE MOUNTED ON ONE OF THESE ENCLOSURES AND BE CONNECTED TO THE ENCLOSURE OR GROUNDING

- ELECTRODE CONDUCTOR WITH A MINIMUM #6 CU CONDUCTOR.
- 6.4. BE SECURELY MOUNTED TO THE BUILDING'S DISCONNECTING MEANS, OR BE MOUNTED AT THE DISCONNECTING MEANS AND BE CONNECTED TO THE METALLIC ENCLOSURE OR GROUNDING ELECTRODE CONDUCTOR WITH A MINIMUM #6 CU CONDUCTOR.
7. ALL BRANCH CIRCUIT AND FEEDER CONDUITS ARE TO HAVE AN INSULATED EQUIPMENT GROUNDING CONDUCTOR REGARDLESS OF THE CONDUIT MATERIAL.
8. WHEN THE SERVICE CONSISTS OF MULTIPLE DISCONNECTING MEANS IN SEPARATE ENCLOSURES, CONNECT A TAP

- CONDUCTOR FROM THE MAIN GROUNDING ELECTRODE CONDUCTOR TO EACH DISCONNECTING MEANS. SIZE THIS TAP BASED ON THE LARGEST SERVICE CONDUCTOR IN THAT SERVICE DISCONNECT ENCLOSURE.
9. #6 COPPER GROUNDING ELECTRODE CONDUCTOR.
10. INSTALL #6 CU TO TWO 5/8"x 8' MIN. GROUND RODS AS SHOWN.
11. #4 COPPER GROUNDING ELECTRODE CONDUCTOR.
12. COPPER GROUNDING ELECTRODE CONDUCTOR. PROVIDE #6 COPPER.

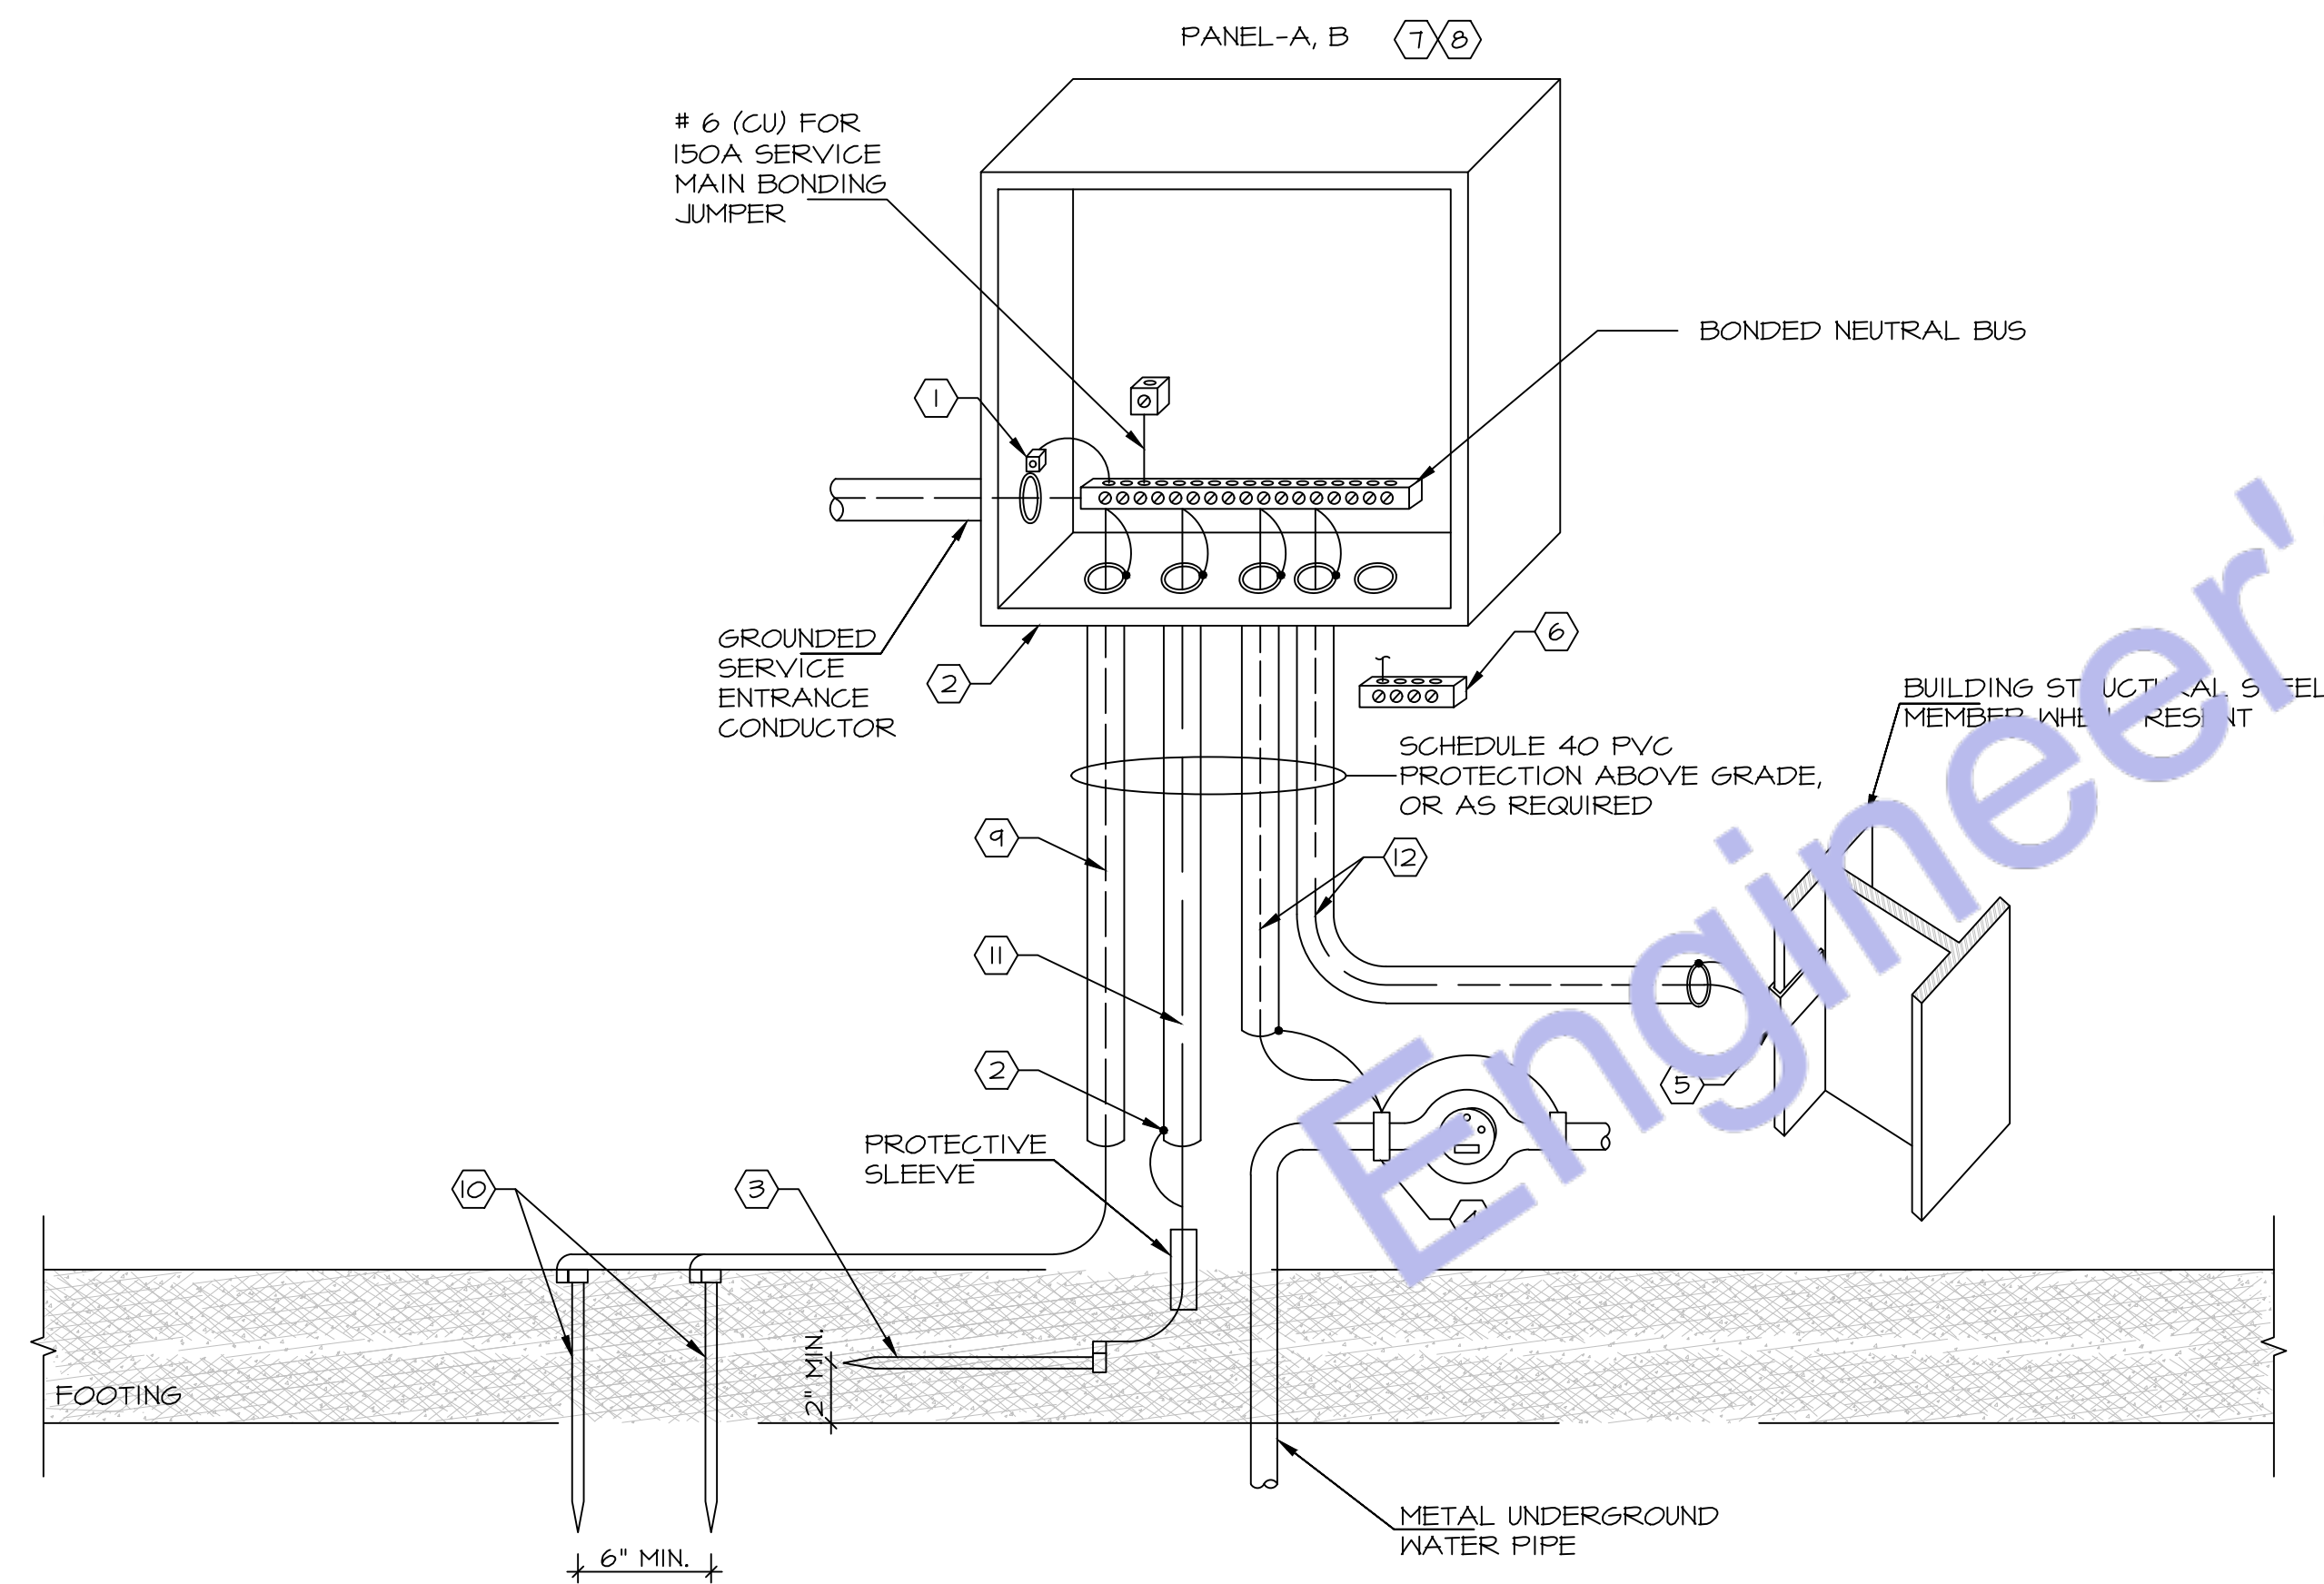

1 GROUNDING ELECTRODE SYSTEM DIAGRAM
SCALE: NOT TO SCALE

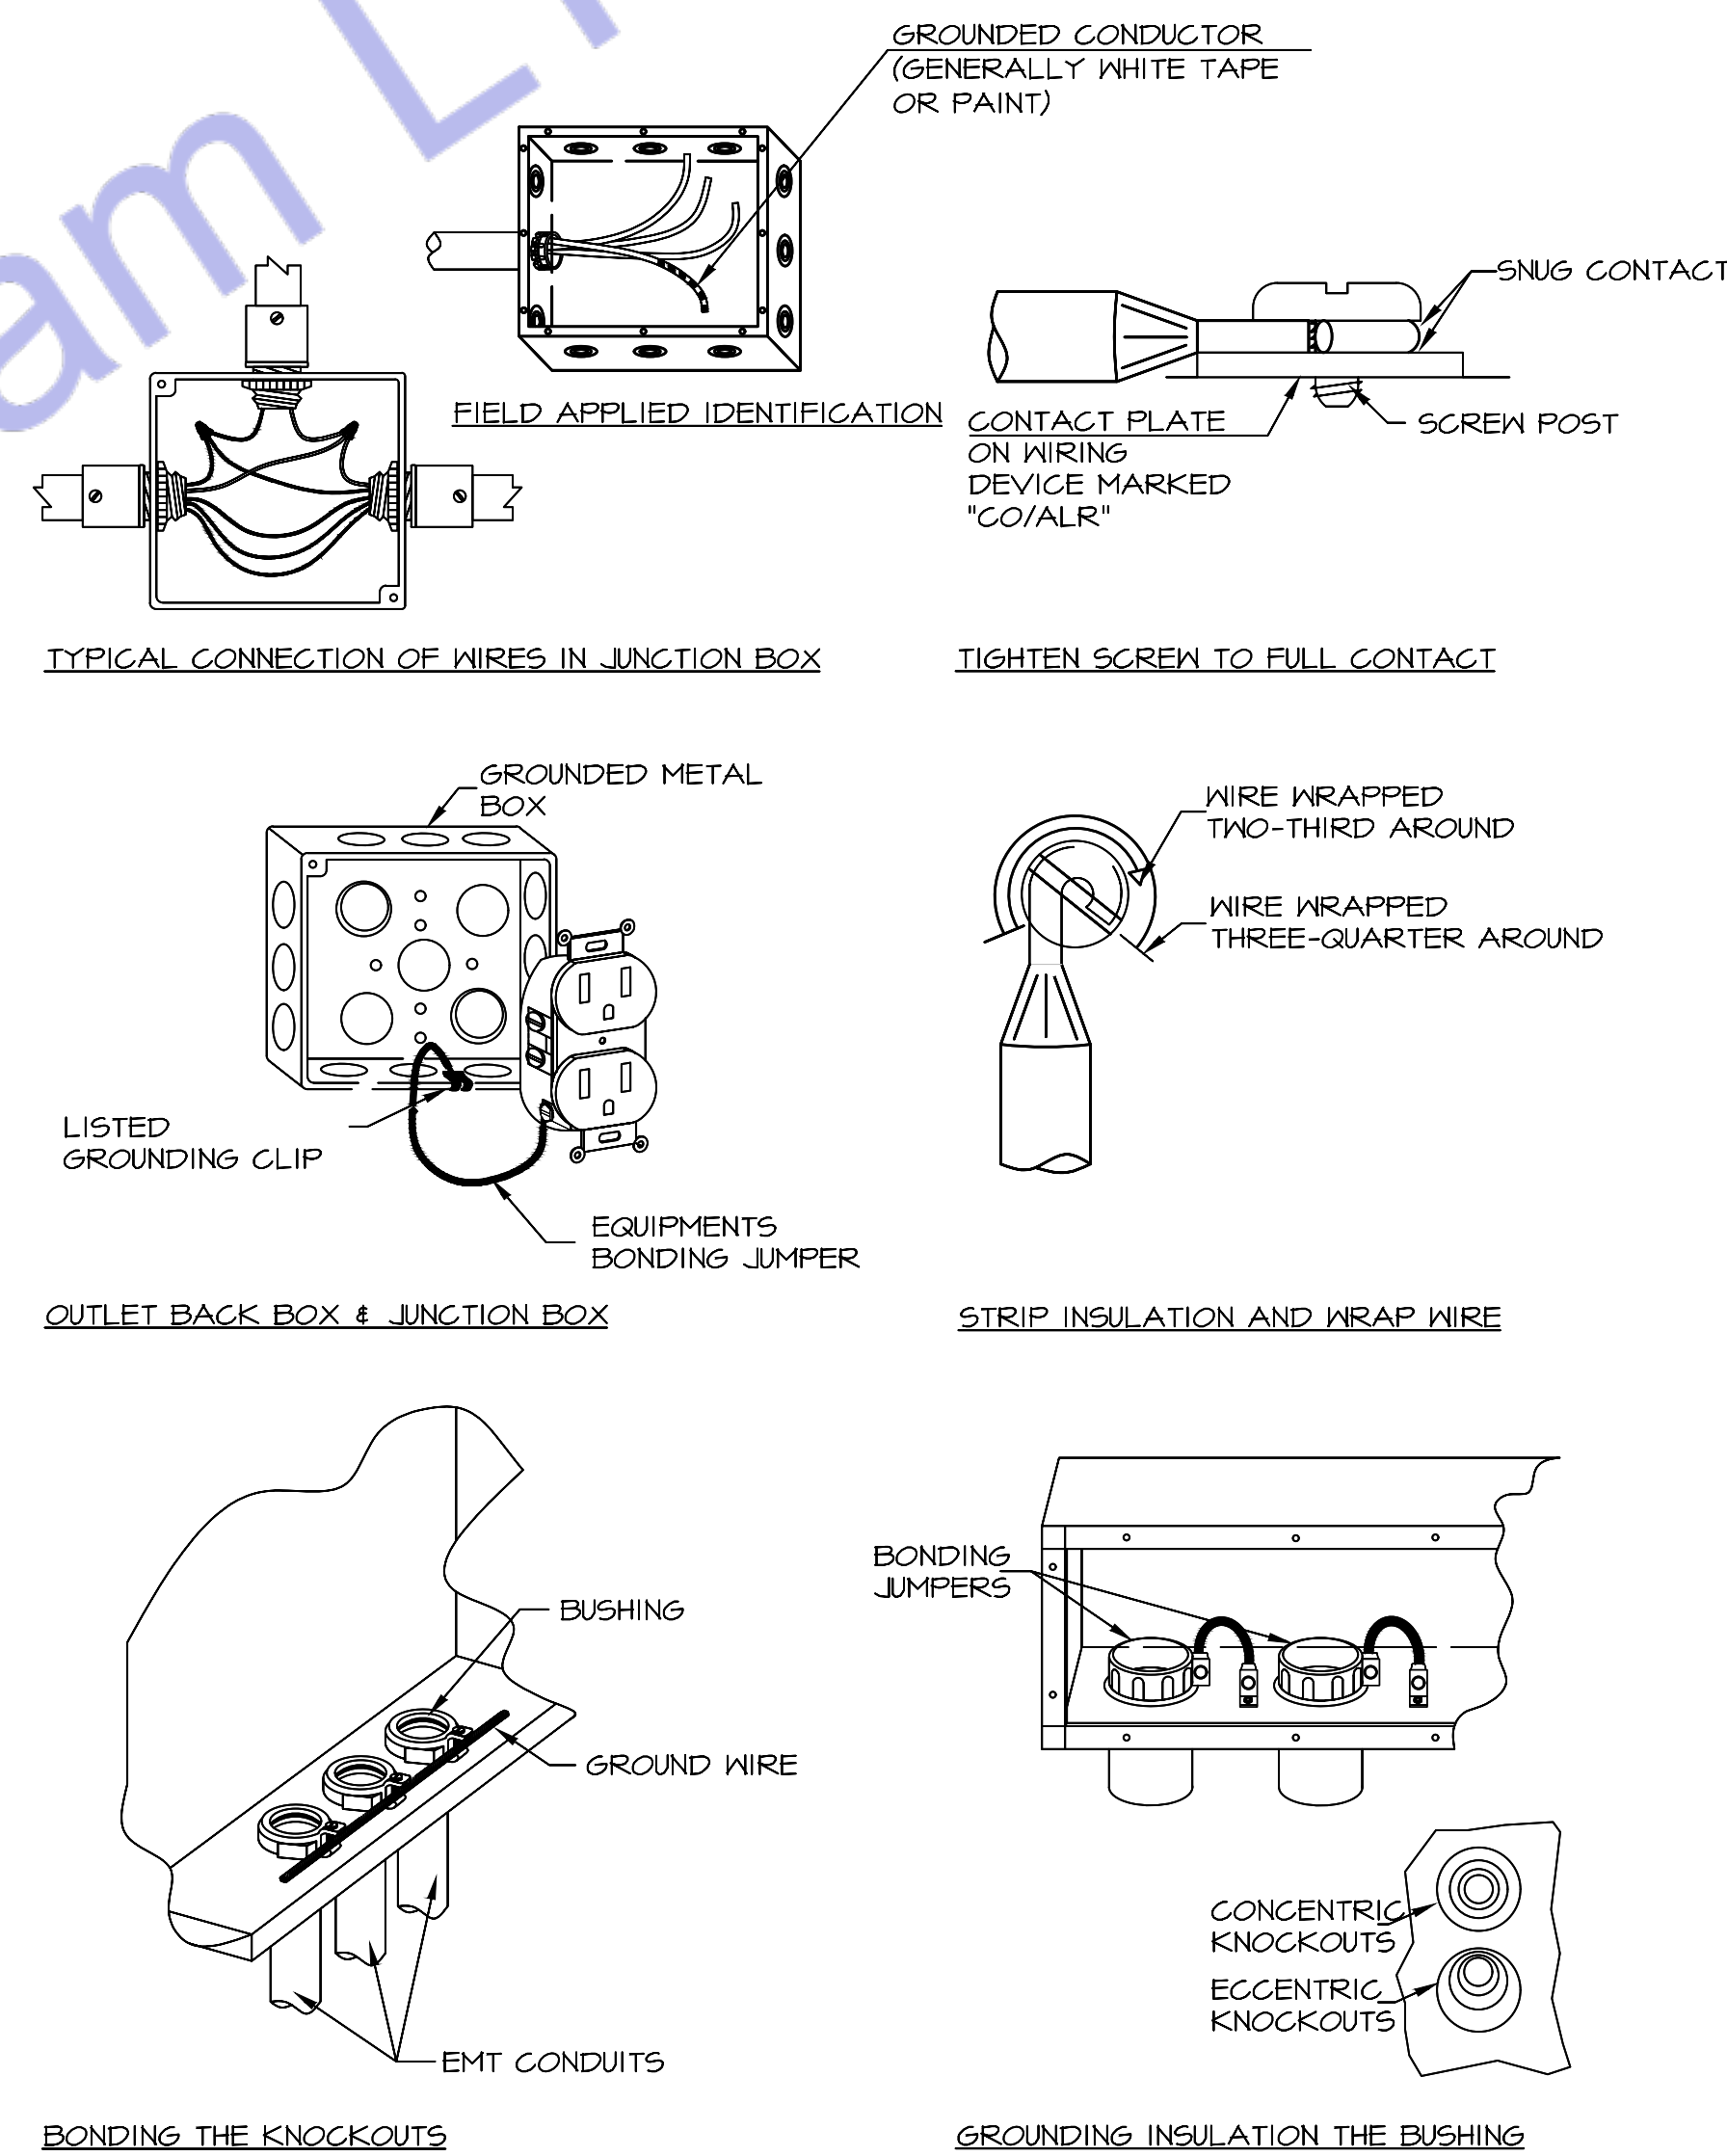

2 BONDING DETAILS
SCALE: NOT TO SCALE



ENGINEER'S TEAM LTD
Web site: www.engrteam.com
Email: support@engrteam.com

CLIENT: MR AND MRS ANDERTON

ADDRESS: 25 WILBURY AVENUE,
HOVE, BN3 6HS

CONFIDENTIALITY STATEMENT:
ALL DRAWINGS AND WRITTEN MATERIALS APPEARING HEREIN CONSTITUTE THE ORIGINAL AND UNPUBLISHED WORK OF THE DESIGNER AND THE SAME MAY NOT BE DUPLICATED, USED OR DISCLOSED WITHOUT CONSENT OF THE DESIGNER.

NOTES:
1. ALL DIMENSIONS HEREIN ARE IN IMPERIAL UNITS UNLESS STATED OTHERWISE.
2. THESE DRAWINGS ARE TO BE READ IN CONJUNCTION WITH ALL RELEVANT DESIGNER, ENGINEER OR SPECIALIST DRAWINGS AND SPECIFICATIONS.
3. THE CONTRACTOR MUST CHECK ALL DIMENSION AT SITE BEFORE COMMENCING WORK.
4. THE CONTRACTOR IS RESPONSIBLE FOR PROVIDING ALL NECESSARY TEMPORARY SUPPORT TO THE BUILDING AND ANY ADJACENT STRUCTURES.

REV. NO.	DESCRIPTION	DATE	BY
01	Add Grease Trap & update the plumbing plans	03/02/26	AA
02	Create leak detection, Gas & Fire protection etc plans	06/27/26	AA
03	Fix HVAC system and add new system	07/21/26	AA
04	Change VRF system & Fix Ventilation	07/27/26	AA
05	Provide more information about the HVAC system	08/04/26	AA
05	HVAC Elevation Plan & Filtrations Specification.	08/16/26	AA


PROJECT: 25 WILBURY AVENUE

TITLE: ELECTRICAL
INSTALLATION

PROJ. NO. PROJ. ENGR. SCALE @ 24X36:
1:100

DATE : September 14, 2026

DRAWING NO. REV.
E - 5 6

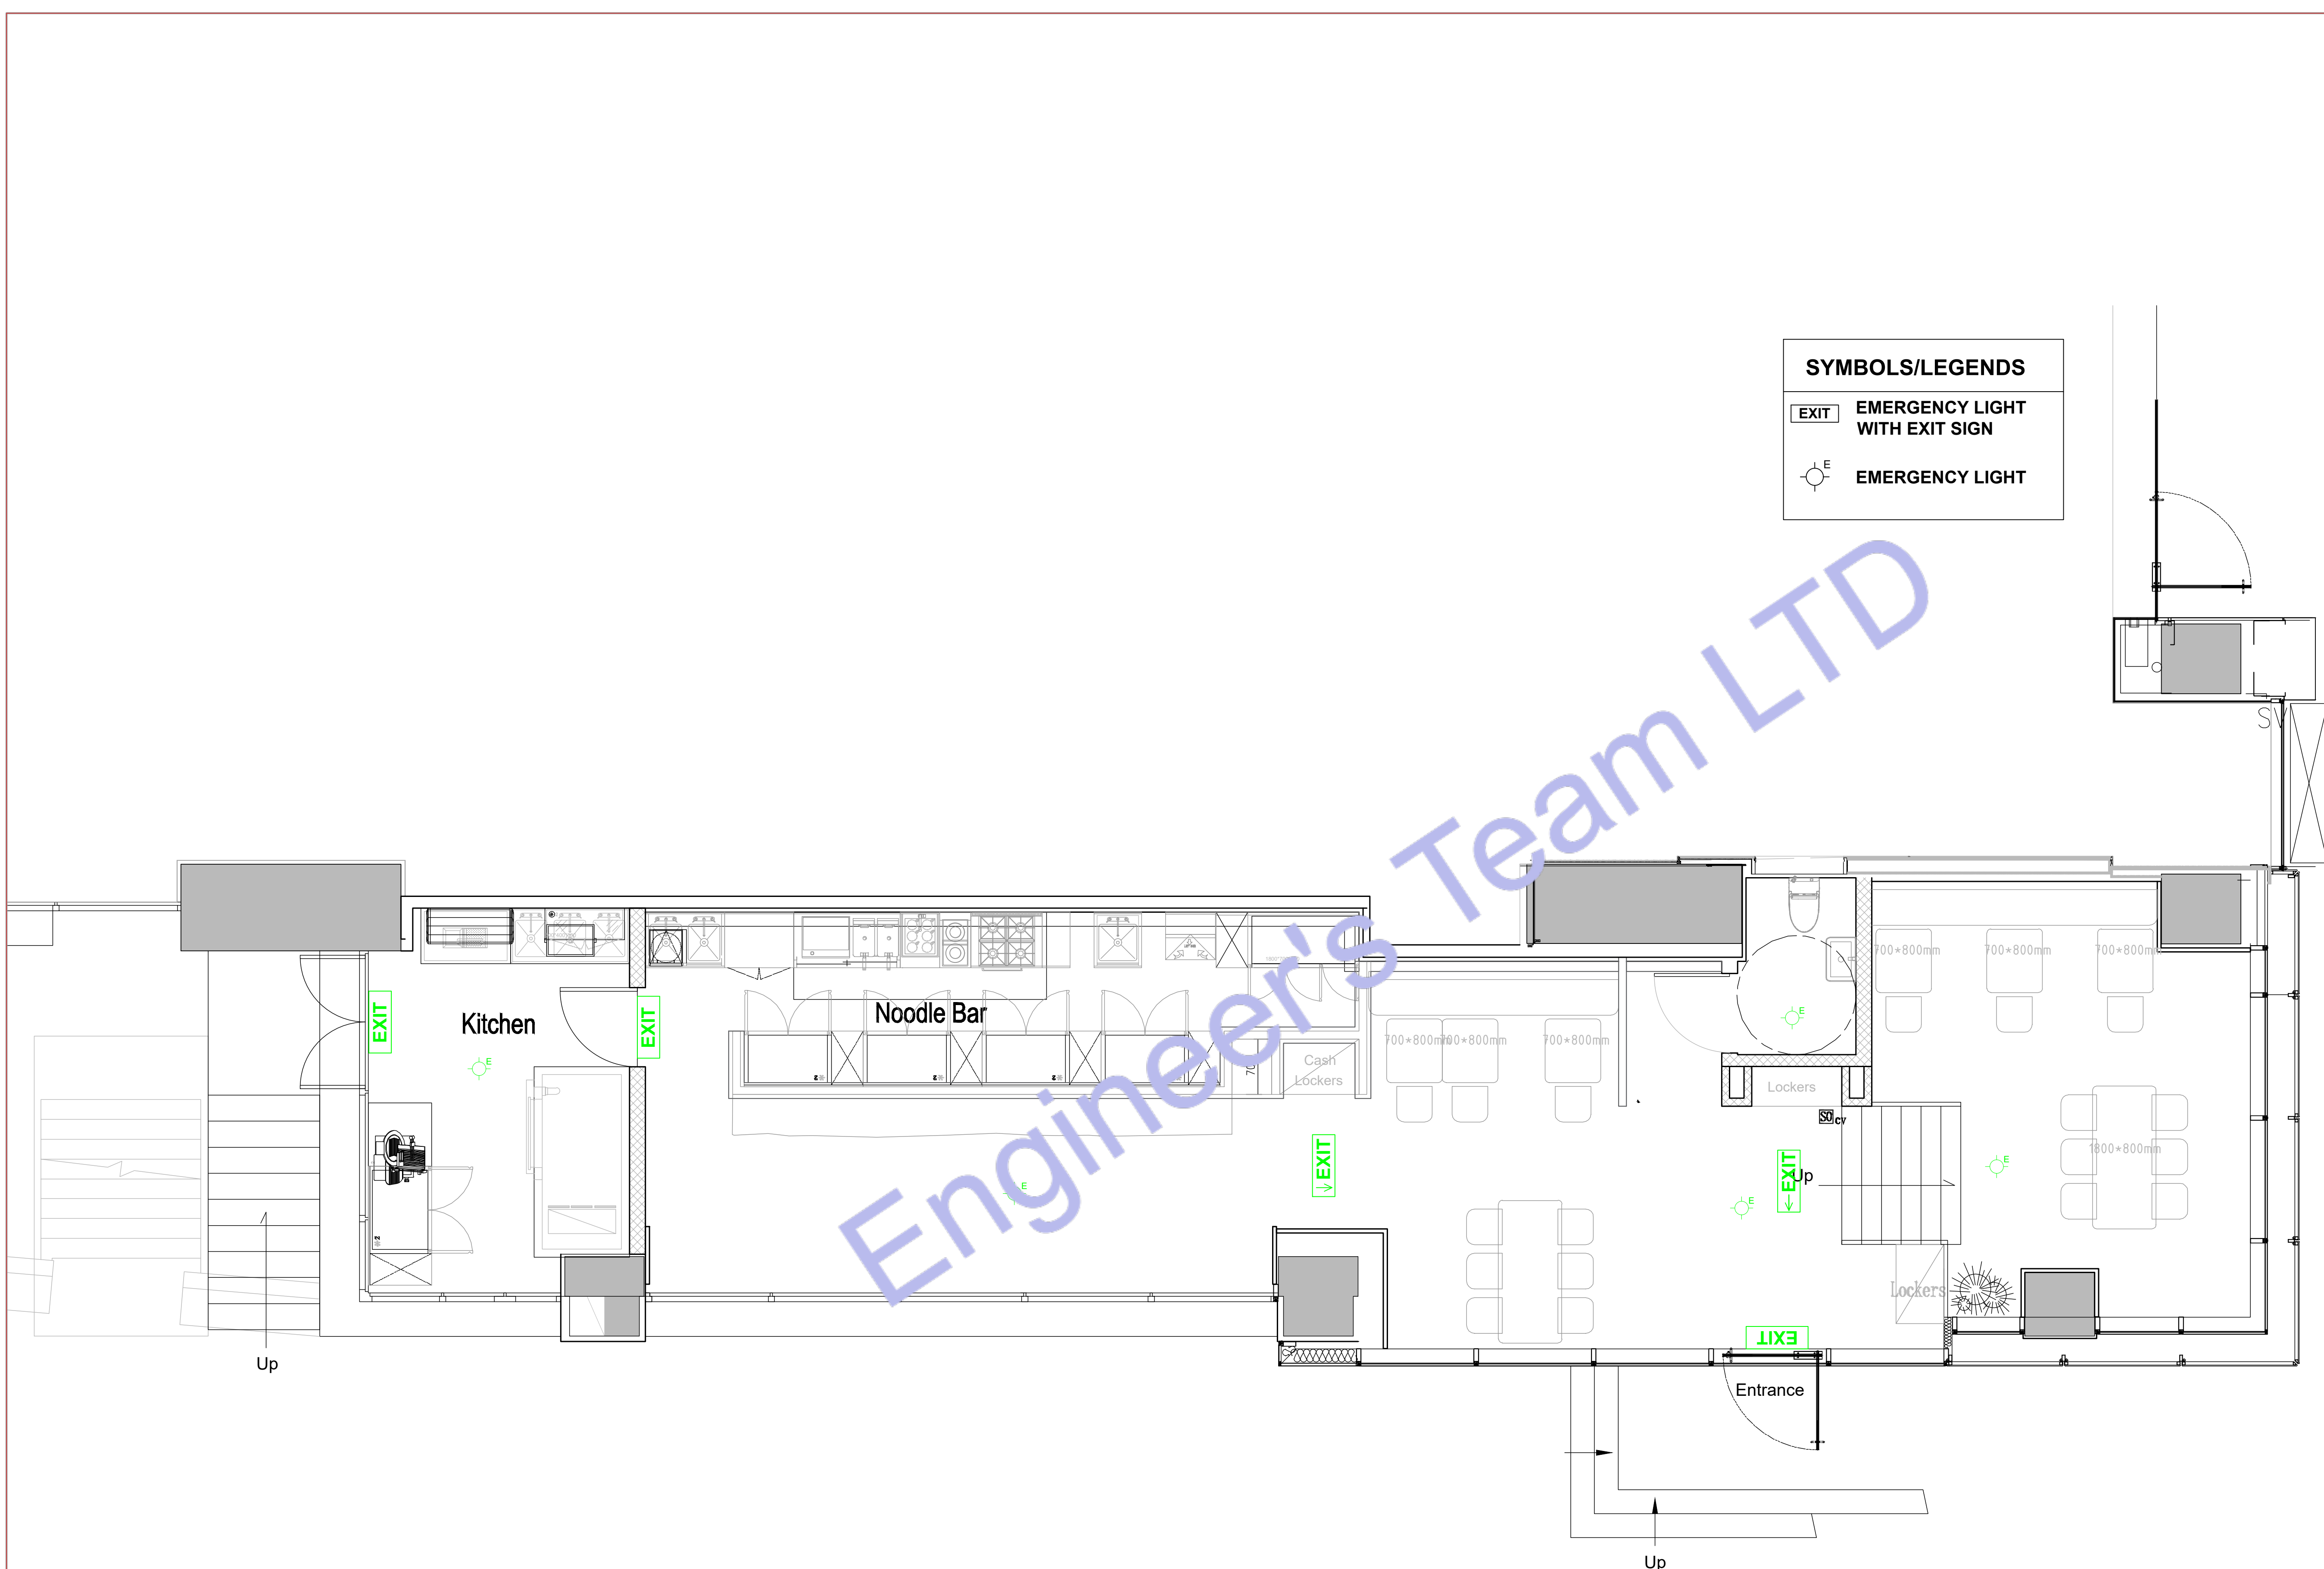

SYMBOLS/LEGENDS

EXIT

EMERGENCY LIGHT WITH EXIT SIGN

E

EMERGENCY LIGHT



ENGINEER'S TEAM LTD
Web site: www.engrteam.com
Email: support@engrteam.com

CLIENT: MR AND MRS ANDERTON

ADDRESS:
25 WILBURY AVENUE,
HOVE, BN3 6HS

CONFIDENTIALITY STATEMENT:
ALL DRAWINGS AND WRITTEN MATERIALS
APPEARING HEREIN CONSTITUTE THE
ORIGINAL AND UNPUBLISHED WORK OF THE
DESIGNER AND THE SAME MAY NOT BE
DUPLICATED, USED OR DISCLOSED WITHOUT
CONSENT OF THE DESIGNER.

NOTES:
1. ALL DIMENSIONS HEREIN ARE IN IMPERIAL
UNITS UNLESS STATED OTHERWISE.
2. THESE DRAWINGS ARE TO BE READ IN
CONJUNCTION WITH ALL RELEVANT DESIGNER,
ENGINEER OR SPECIALIST DRAWINGS AND
SPECIFICATIONS.
3. THE CONTRACTOR MUST CHECK ALL
DIMENSION AT SITE BEFORE COMMENCING
WORK.
4. THE CONTRACTOR IS RESPONSIBLE FOR
PROVIDING ALL NECESSARY TEMPORARY
SUPPORT TO THE BUILDING AND ANY ADJACENT
STRUCTURES.

REFERENCE:
0146-ETE-110CS-GF-R-MEP-001,
0146-ETE-110CS-GF-DR-E-40802 (Rev00)

REV. NO	DESCRIPTION	DATE	BY
01	Add Grease Trap & update the plumbing plans	03/02/26	AA
02	Create leak detection, Gas & Fire protection etc plans	06/27/26	AA
03	Fix HVAC system and add new system	07/21/26	AA
04	Change VRF system & Fix Ventilation	07/27/26	AA
05	Provide more information about the HVAC system	08/04/26	AA
05	HVAC Elevation Plan & Filtrations Specification.	08/16/26	AA


PROJECT: 25 WILBURY AVENUE

TITLE: PROPOSED EMERGENCY LIGHTING LAYOUT PLAN

PROJ. NO.	PROJ. ENGR.	SCALE @ 24X36: 1:100
-----------	-------------	-------------------------

DATE : September 14, 2026

DRAWING NO. L S - 1	REV. 6
------------------------	-----------

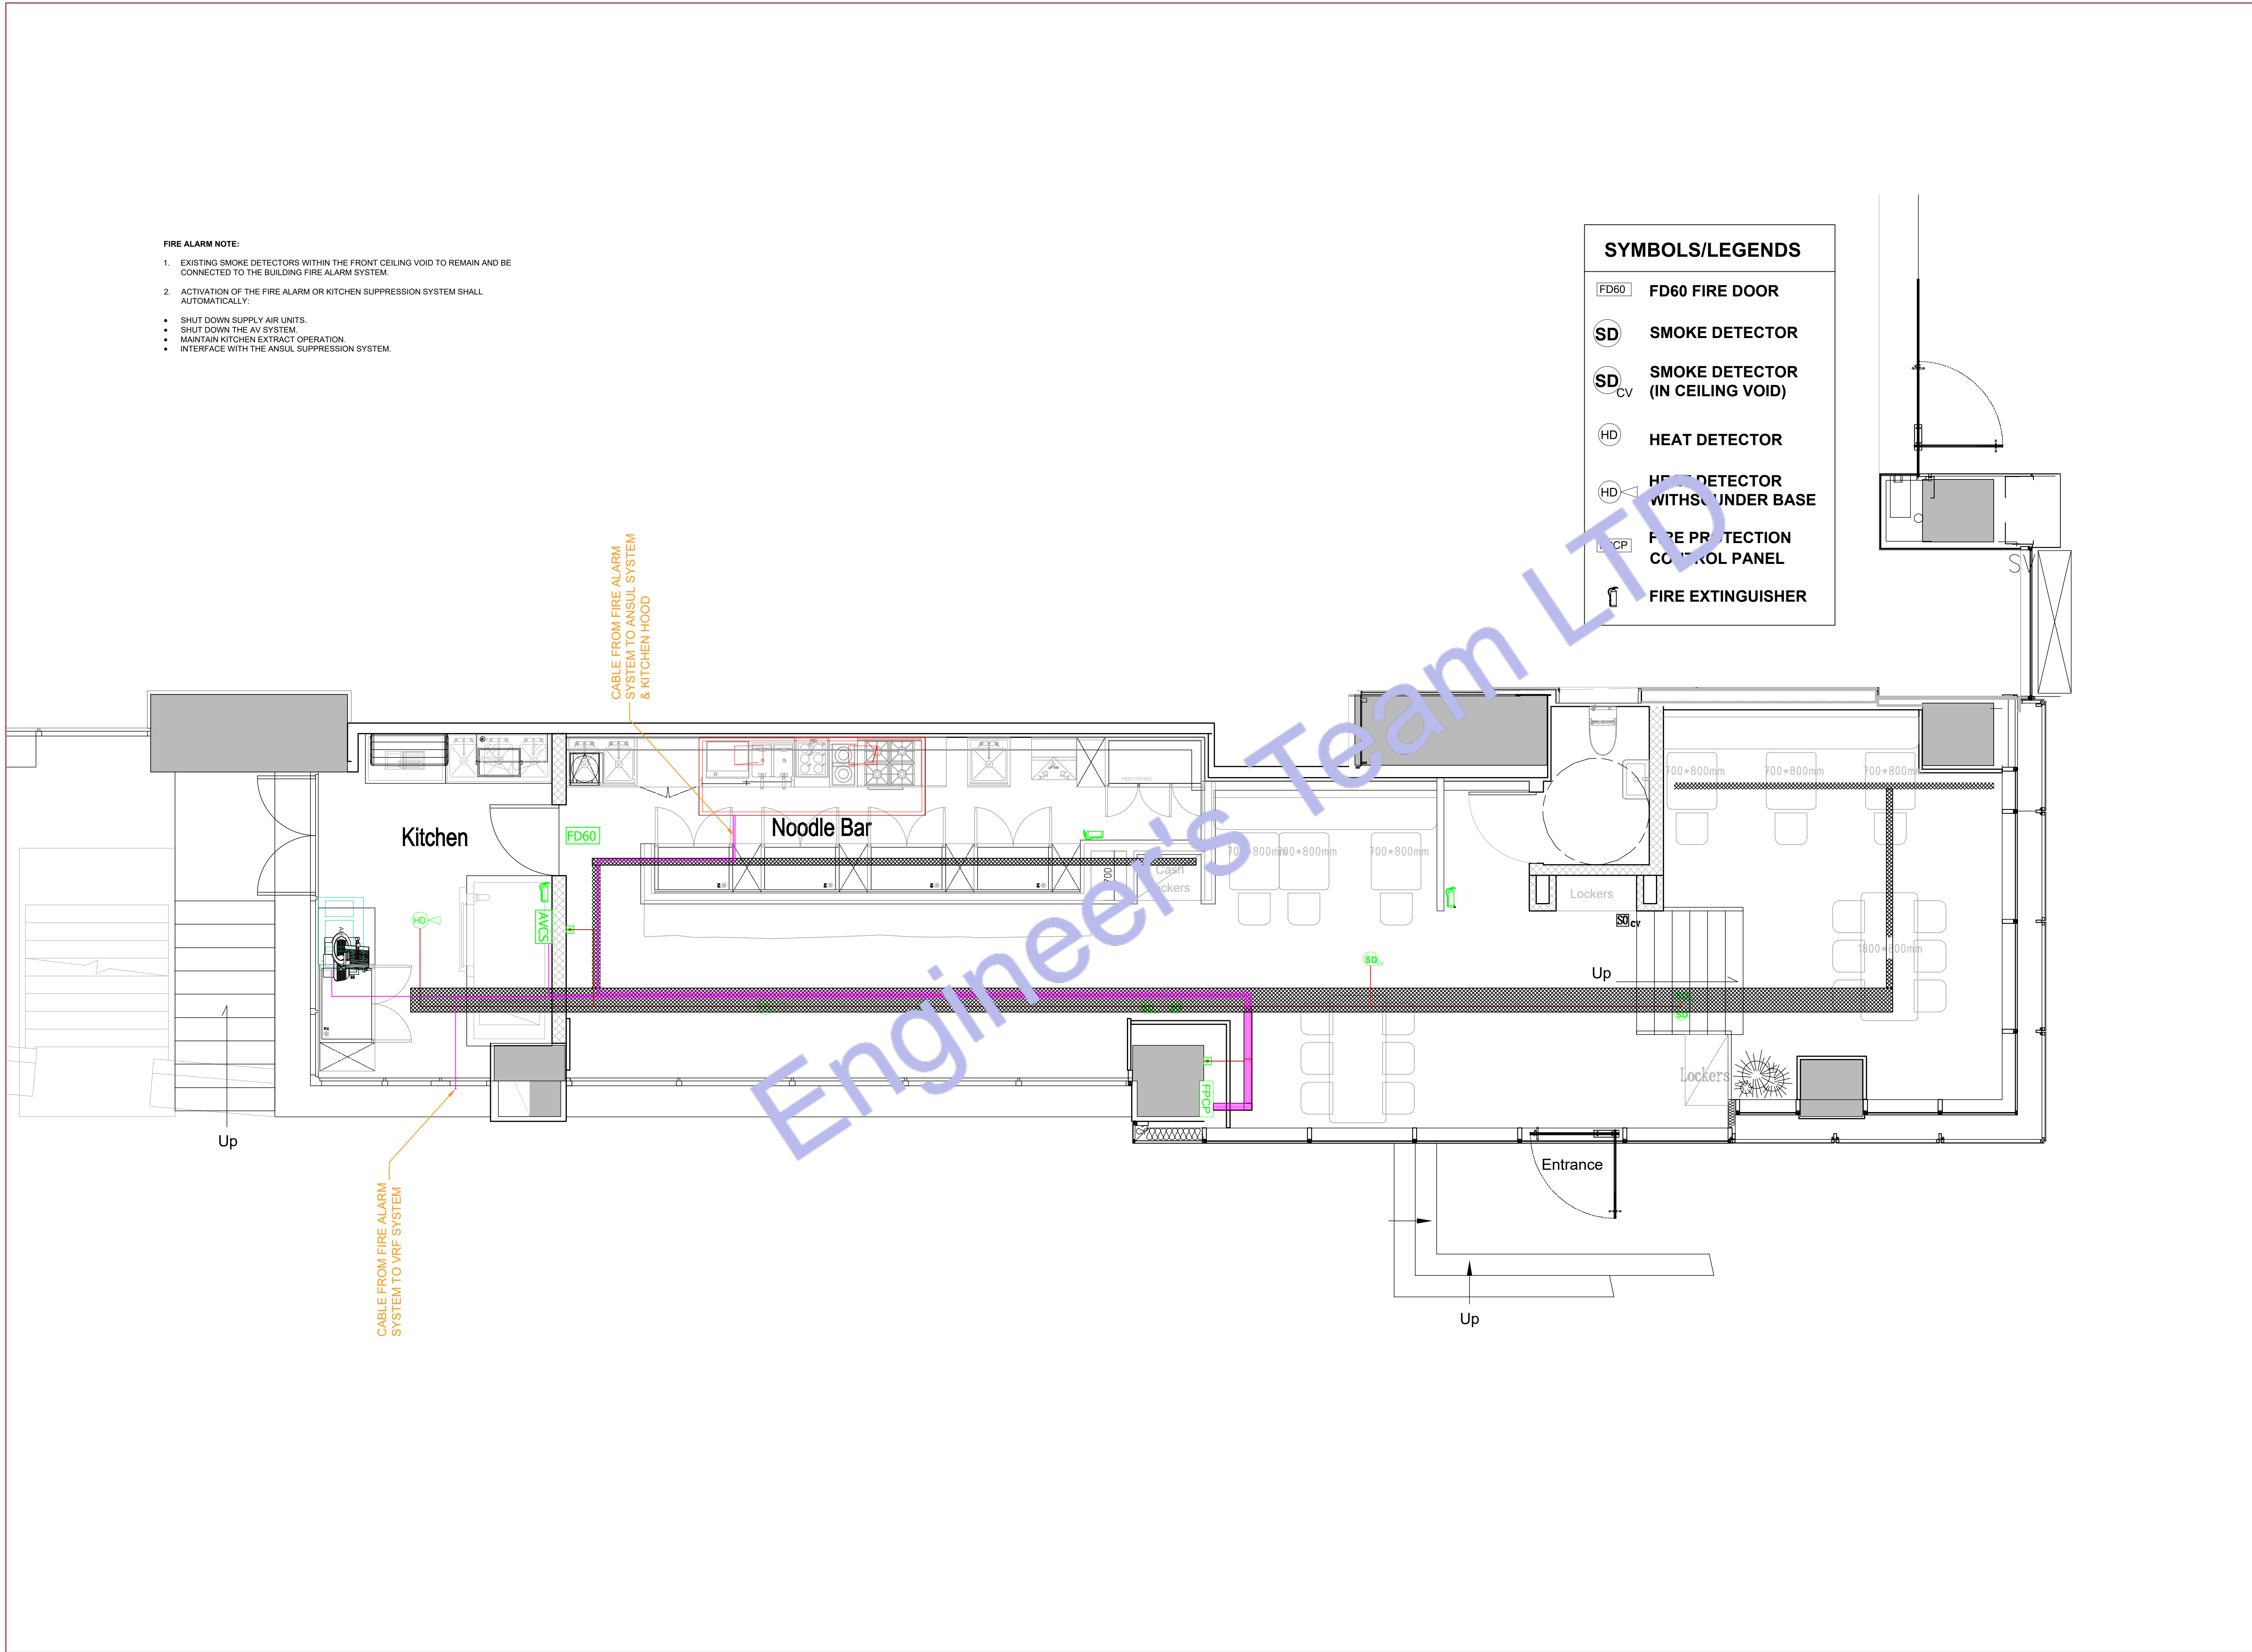

FIRE ALARM NOTE:

- EXISTING SMOKE DETECTORS WITHIN THE FRONT CEILING VOID TO REMAIN AND BE CONNECTED TO THE BUILDING FIRE ALARM SYSTEM.
- ACTIVATION OF THE FIRE ALARM OR KITCHEN SUPPRESSION SYSTEM SHALL AUTOMATICALLY:
 - SHUT DOWN SUPPLY AIR UNITS.
 - SHUT DOWN THE AV SYSTEM.
 - MAINTAIN KITCHEN EXTRACT OPERATION.
 - INTERFACE WITH THE ANSUL SUPPRESSION SYSTEM.

SYMBOLS/LEGENDS

- FD60 FD60 FIRE DOOR
- SD SMOKE DETECTOR
- SD_{CV} SMOKE DETECTOR (IN CEILING VOID)
- HD HEAT DETECTOR
- HD WITH SOUNDER BASE HEAT DETECTOR WITH SOUNDER BASE
- FPCP FIRE PROTECTION CONTROL PANEL
- FIRE EXTINGUISHER



ENGINEER'S TEAM LTD

Web site: www.engrteam.com
Email: support@engrteam.com

CLIENT: MR AND MRS ANDERTON

ADDRESS:
25 WILBURY AVENUE,
HOVE, BN3 6HS

CONFIDENTIALITY STATEMENT:

ALL DRAWINGS AND WRITTEN MATERIALS
APPEARING HEREIN CONSTITUTE THE
ORIGINAL AND UNPUBLISHED WORK OF THE
DESIGNER AND THE SAME MAY NOT BE
DUPLICATED, USED OR DISCLOSED WITHOUT
CONSENT OF THE DESIGNER.

NOTES:

- ALL DIMENSIONS HEREIN ARE IN IMPERIAL UNITS UNLESS STATED OTHERWISE.
- THESE DRAWINGS ARE TO BE READ IN CONJUNCTION WITH ALL RELEVANT DESIGNER, ENGINEER OR SPECIALIST DRAWINGS AND SPECIFICATIONS.
- THE CONTRACTOR MUST CHECK ALL DIMENSION AT SITE BEFORE COMMENCING WORK.
- THE CONTRACTOR IS RESPONSIBLE FOR PROVIDING ALL NECESSARY TEMPORARY SUPPORT TO THE BUILDING AND ANY ADJACENT STRUCTURES.

REFERENCE:
0146-ETE-110CS-GF-DR-E-40801 (Rev00)

REV. NO.	DESCRIPTION	DATE	BY
01	Add Grease Trap & update the plumbing plans	03/02/26	AA
02	Create leak detection, Gas & Fire protection etc plans	06/27/26	AA
03	Fix HVAC system and add new system	07/21/26	AA
04	Change VRF system & Fix Ventilation	07/27/26	AA
05	Provide more information about the HVAC system	08/04/26	AA
05	HVAC Elevation Plan & Filtrations Specification.	08/16/26	AA


PROJECT:
25 WILBURY AVENUE

TITLE:
PROPOSED FIRE ALARM
SYSTEM LAYOUT PLAN

PROJ. NO. PROJ. ENGR. SCALE @ 24X36:
1:100

DATE :
September 14, 2026

DRAWING NO. REV.
L 5 - 2 6

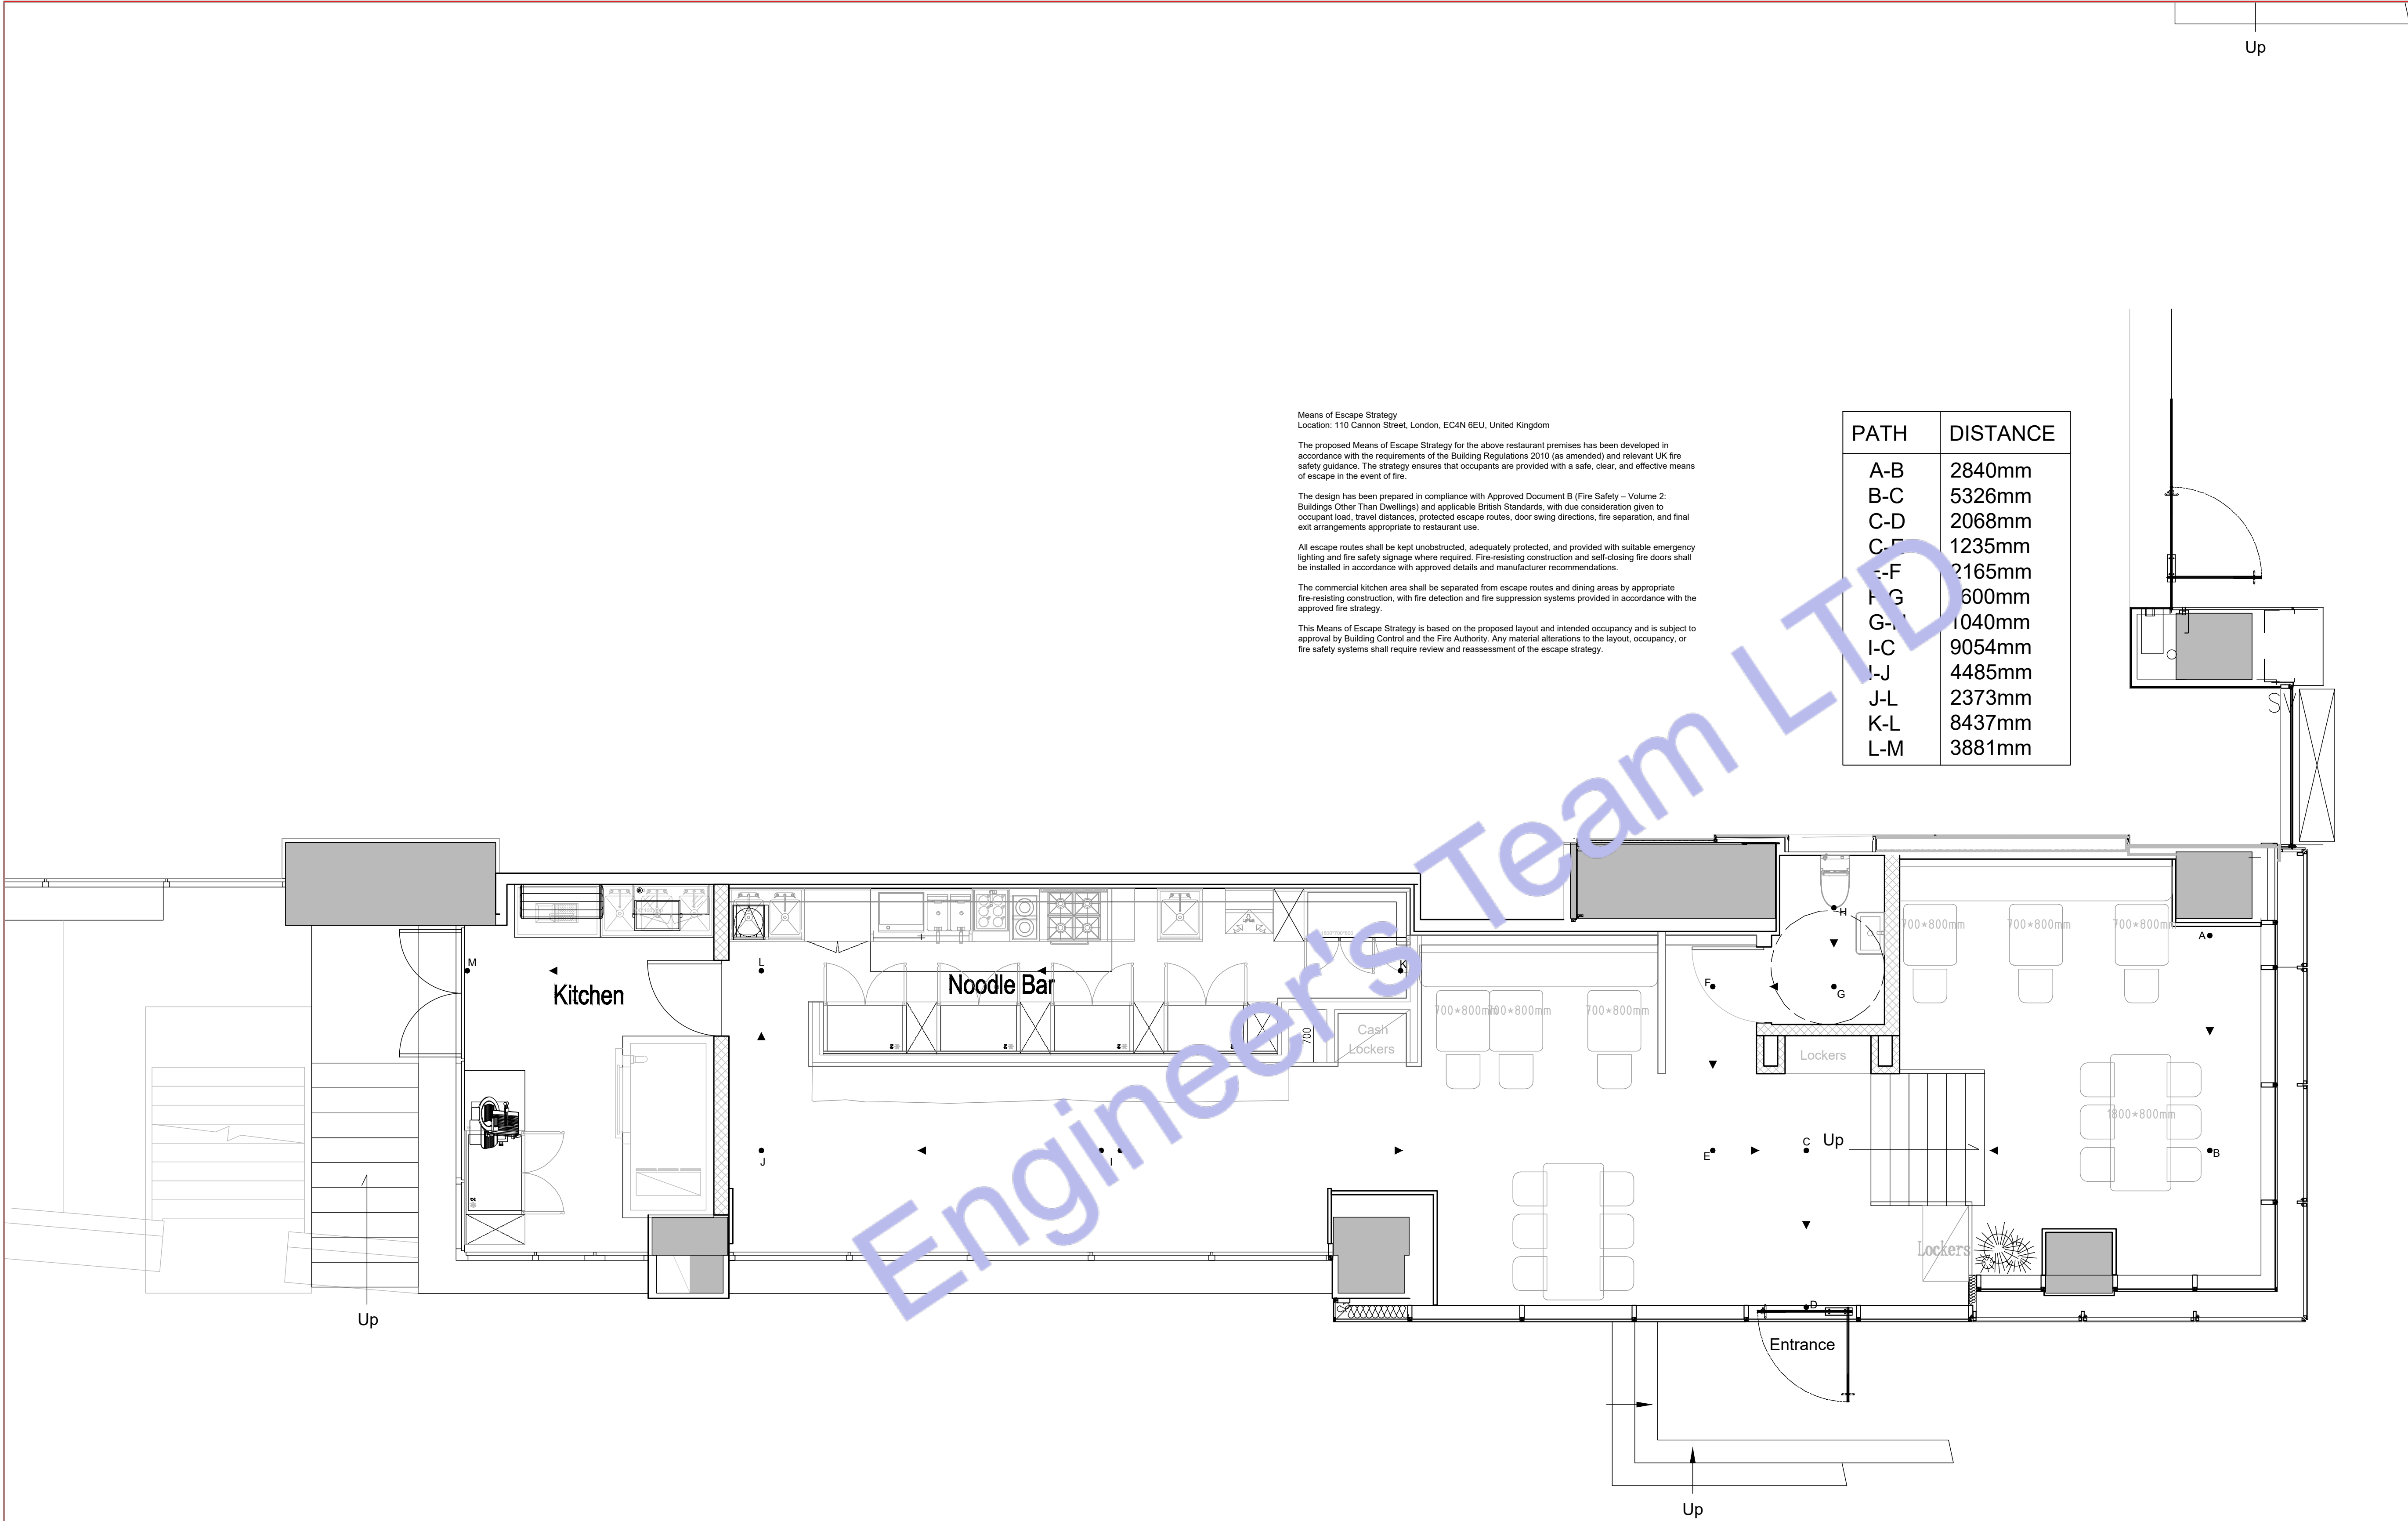

ENGINEER'S TEAM LTD
Web site: www.egrteam.com
Email: support@egrteam.com

CLIENT: MR AND MRS ANDERTON

ADDRESS:
25 WILBURY AVENUE,
HOVE, BN3 6HS

CONFIDENTIALITY STATEMENT:
ALL DRAWINGS AND WRITTEN MATERIALS
APPEARING HEREIN CONSTITUTE THE
ORIGINAL AND UNPUBLISHED WORK OF THE
DESIGNER AND THE SAME MAY NOT BE
DUPLICATED, USED OR DISCLOSED WITHOUT
CONSENT OF THE DESIGNER.

NOTES:
1. ALL DIMENSIONS HEREIN ARE IN IMPERIAL
UNITS UNLESS STATED OTHERWISE.
2. THESE DRAWINGS ARE TO BE READ IN
CONJUNCTION WITH ALL RELEVANT DESIGNER,
ENGINEER OR SPECIALIST DRAWINGS AND
SPECIFICATIONS.
3. THE CONTRACTOR MUST CHECK ALL
DIMENSION AT SITE BEFORE COMMENCING
WORK.
4. THE CONTRACTOR IS RESPONSIBLE FOR
PROVIDING ALL NECESSARY TEMPORARY
SUPPORT TO THE BUILDING AND ANY ADJACENT
STRUCTURES.

REFERENCE:
0146-ETE-110CS-GF-DR-E-40801 (Rev00)

REV. NO.	DESCRIPTION	DATE	BY
01	Add Grease Trap & update the plumbing plans	03/02/26	AA
02	Create leak detection, Gas & Fire protection etc plans	06/27/26	AA
03	Fix HVAC system and add new system	07/21/26	AA
04	Change VRF system & Fix Ventilation	07/27/26	AA
05	Provide more information about the HVAC system	08/04/26	AA
05	HVAC Elevation Plan & Filtrations Specification.	08/16/26	AA

PROJECT:
25 WILBURY AVENUE


TITLE:
PROPOSED MEANS OF
ESCAPE STRATEGY PLAN

PROJ. NO.	PROJ. ENGR.	SCALE @ 24X36:
		1:100


DATE :
September 14, 2026

DRAWING NO. L S - 3	REV. 6
------------------------	-----------


1. ABOUT THE SMART CONNECT FIRE ALARM PANEL

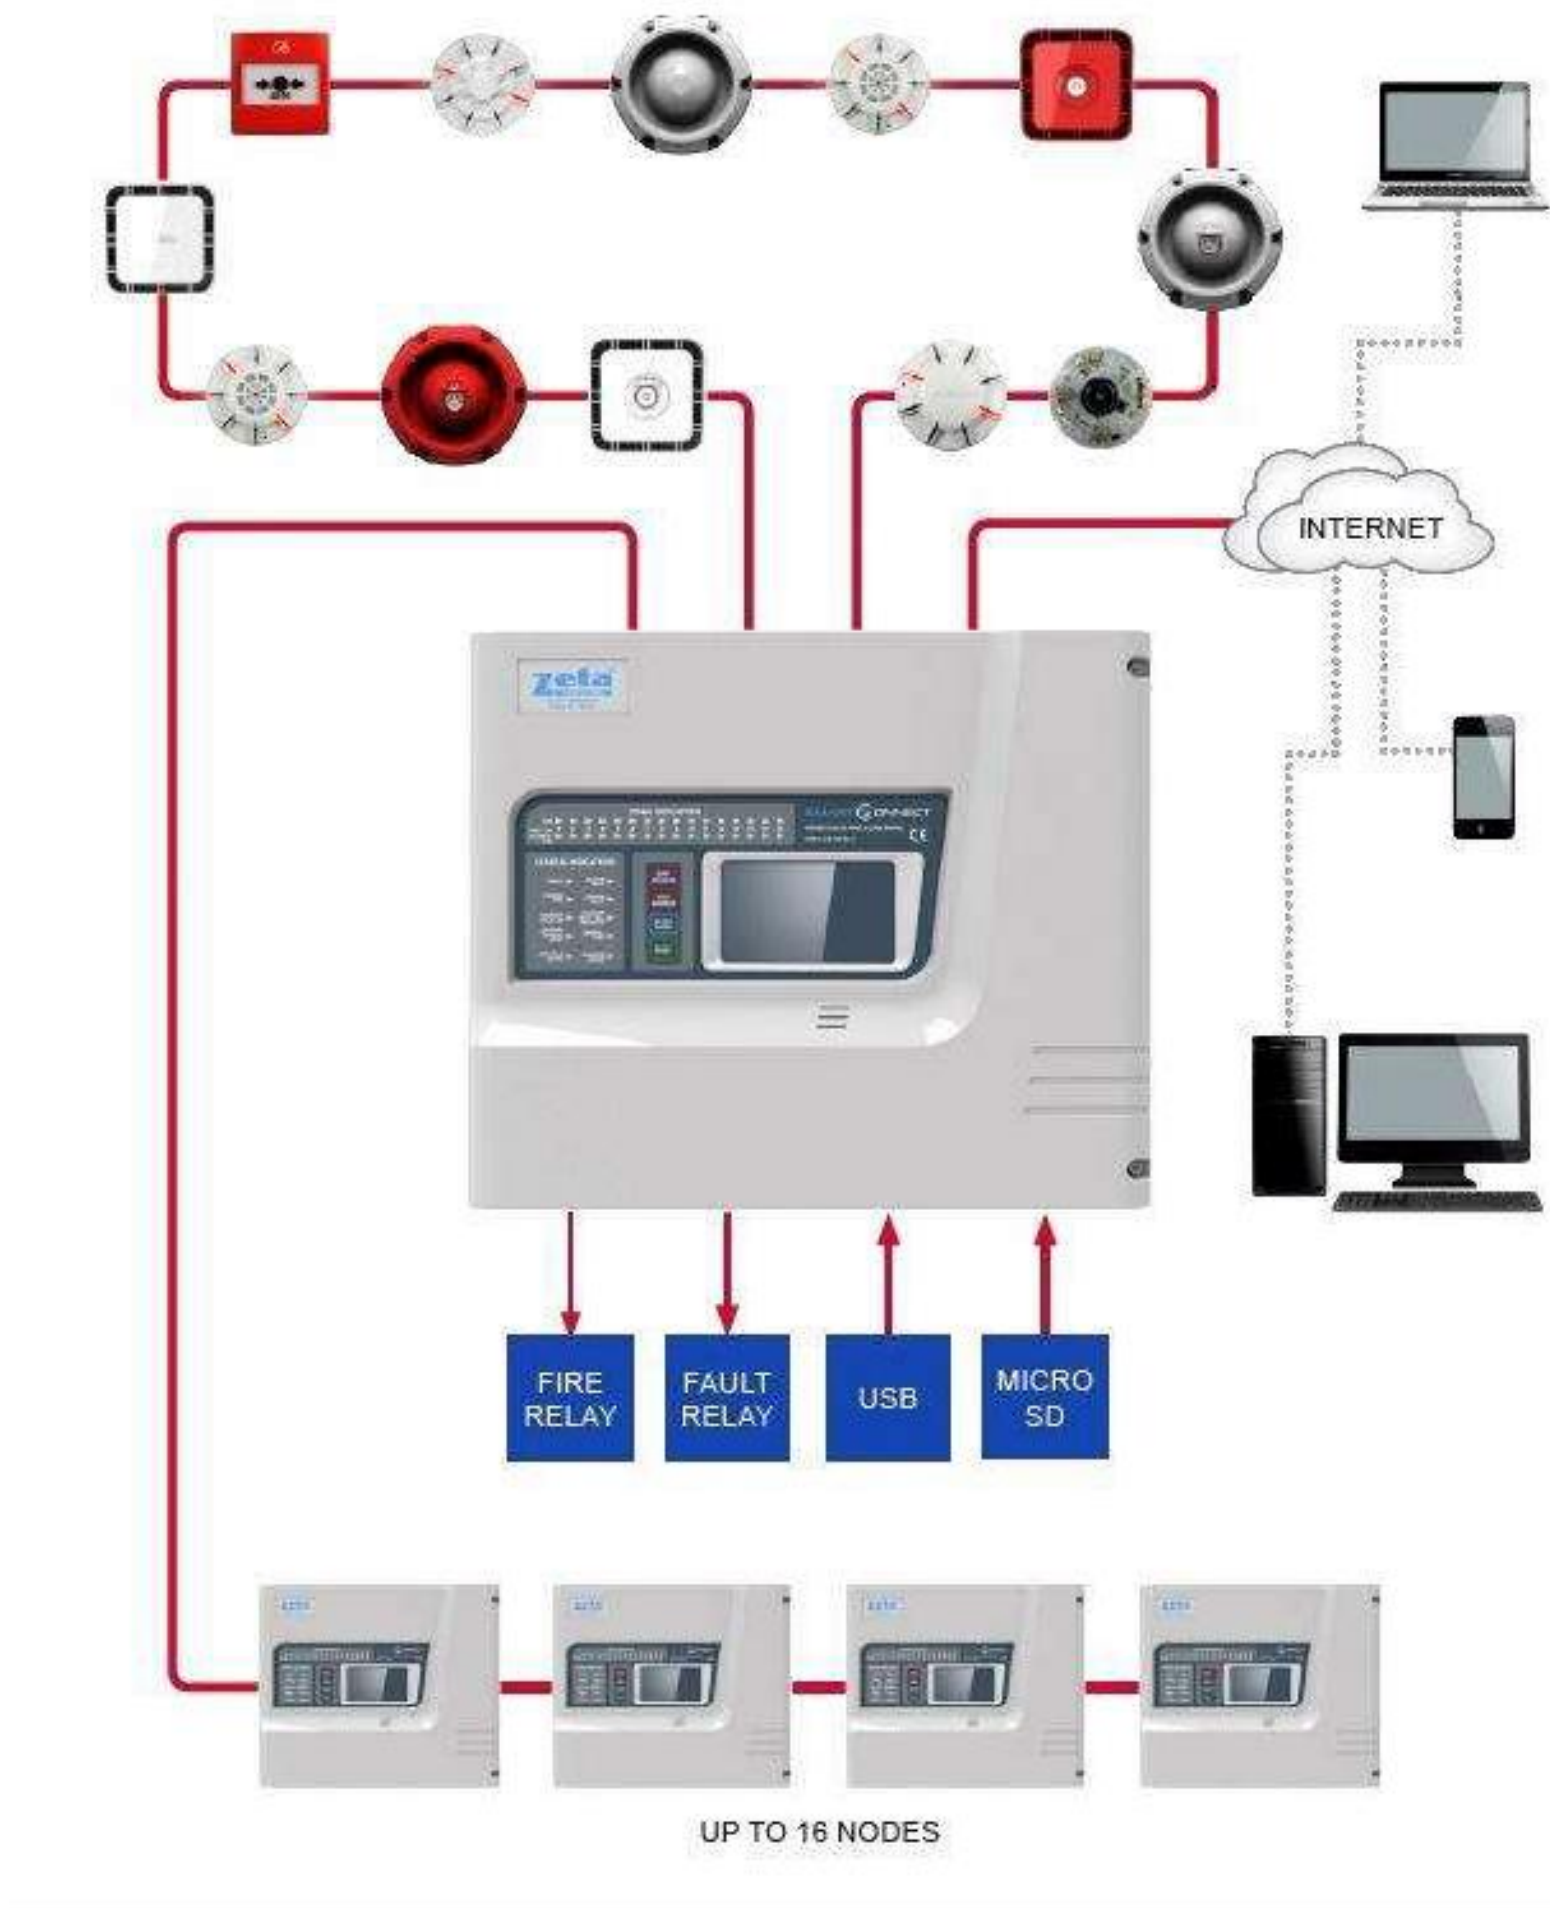


2. PANEL INTERNAL LAYOUT

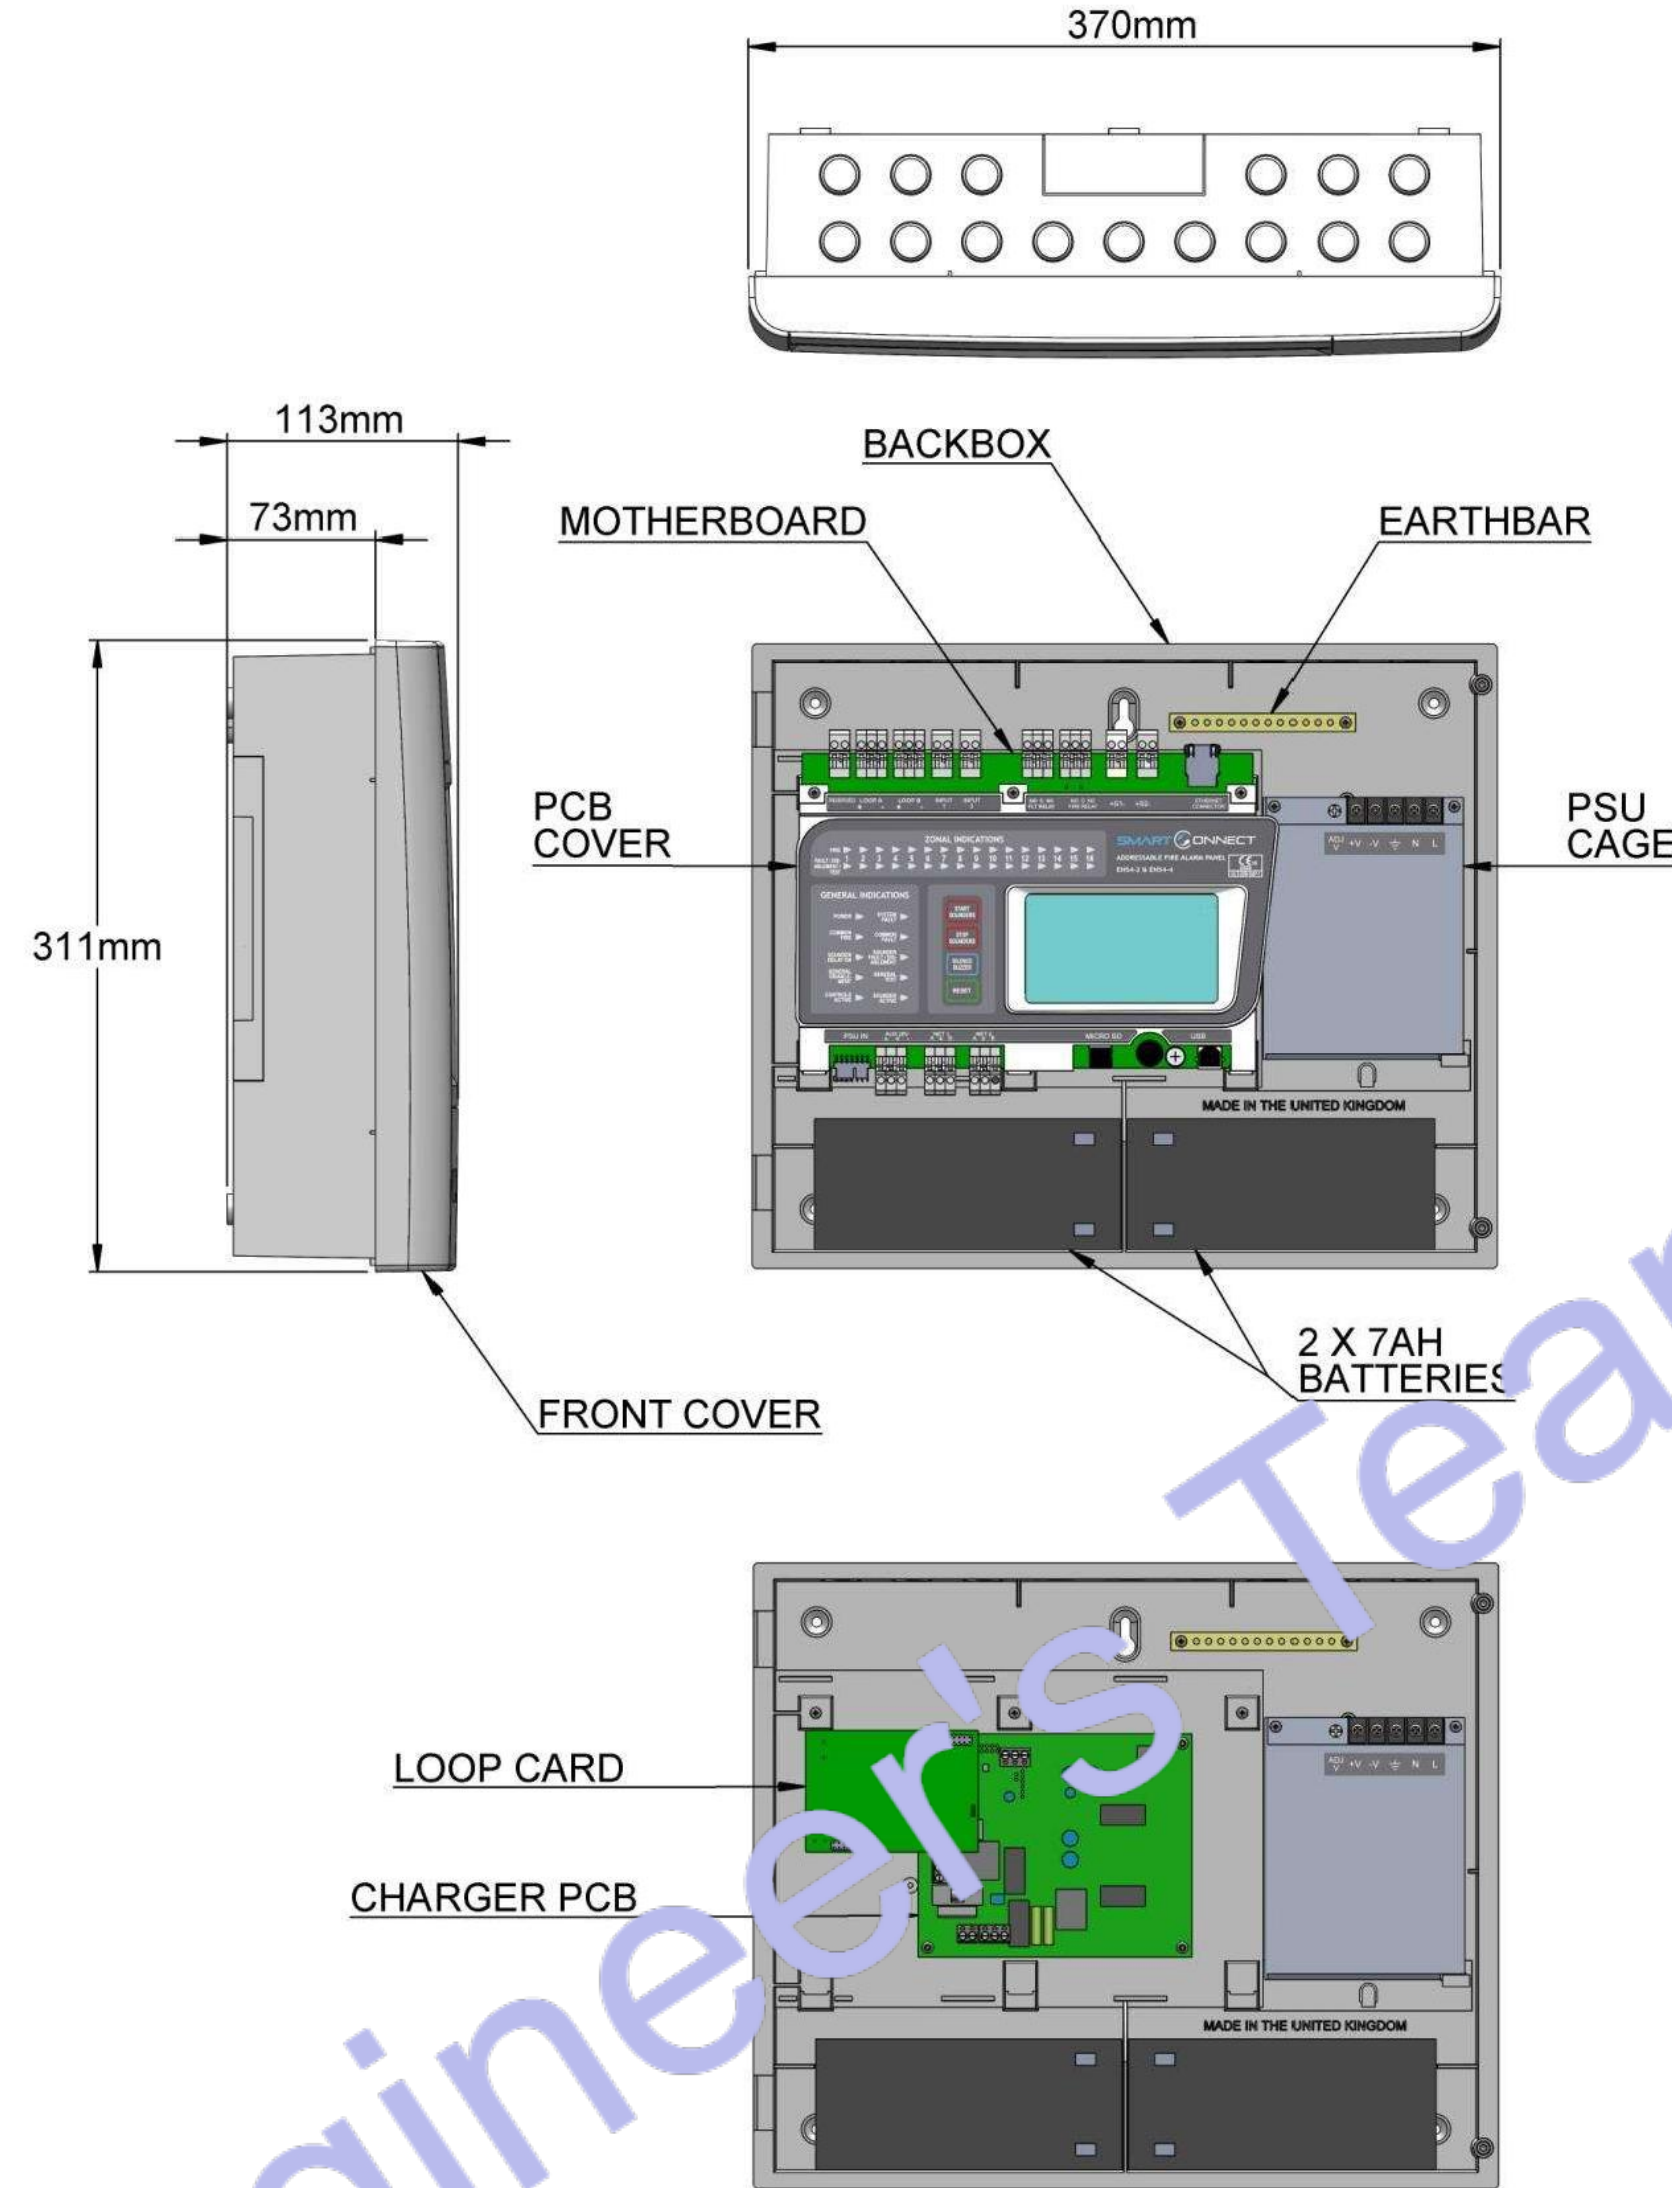


3. PCB CONVENTIONAL SOUNDER CIRCUITS

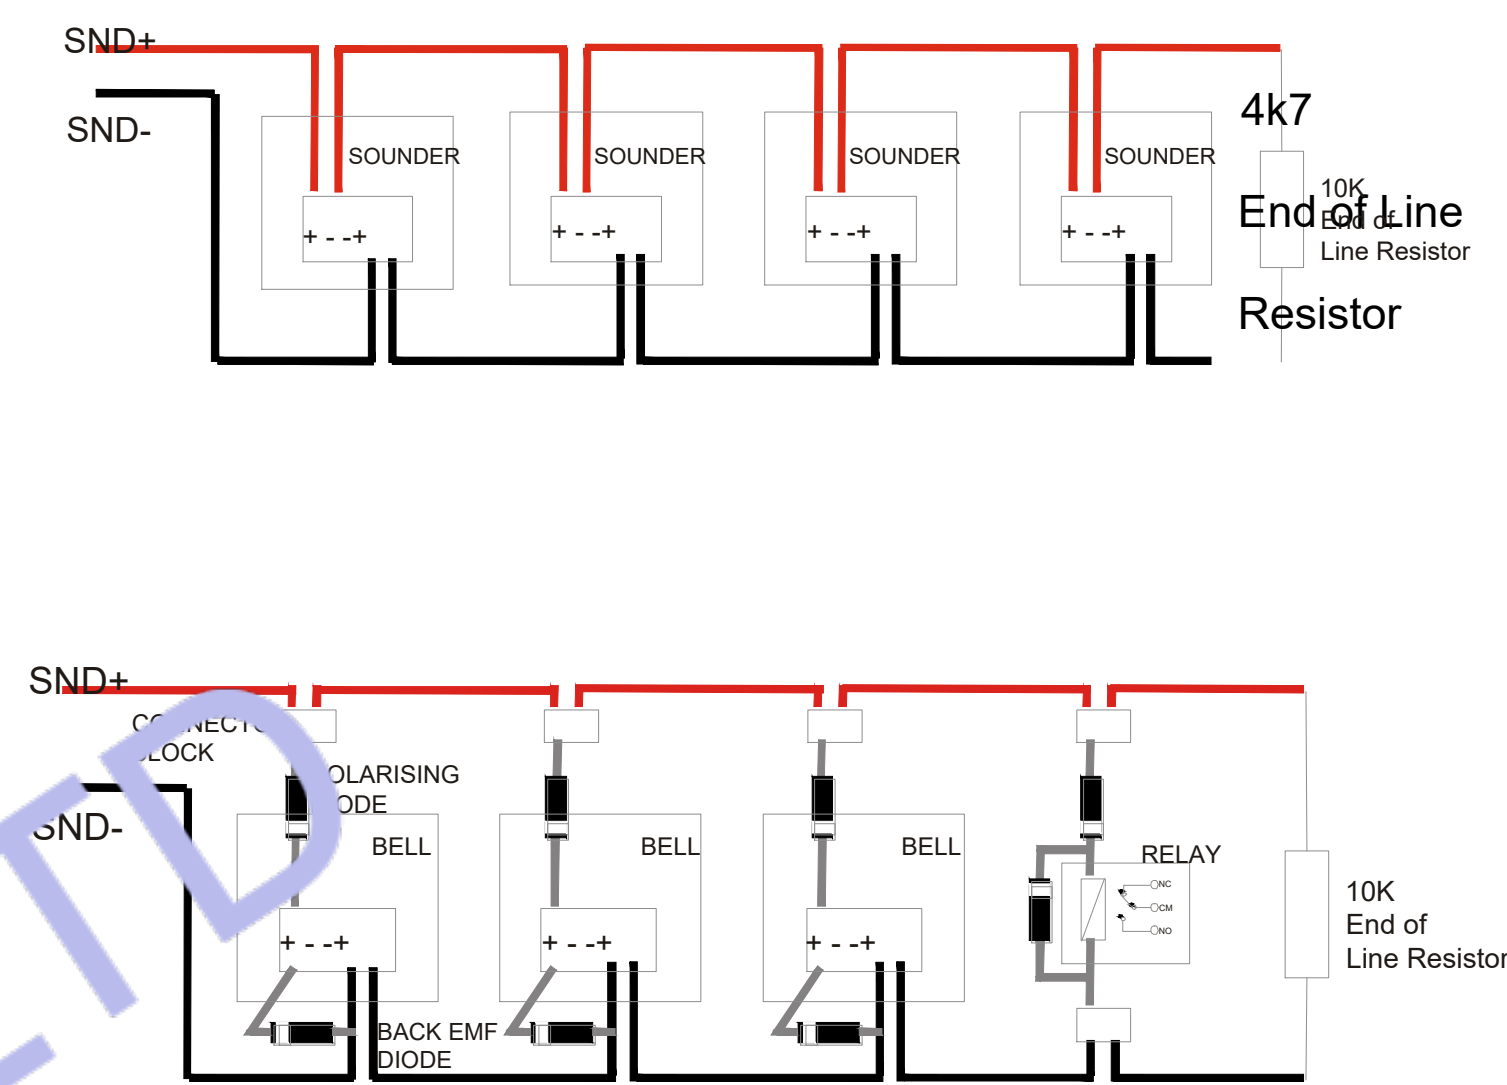


4. ZAI - MI Input Module

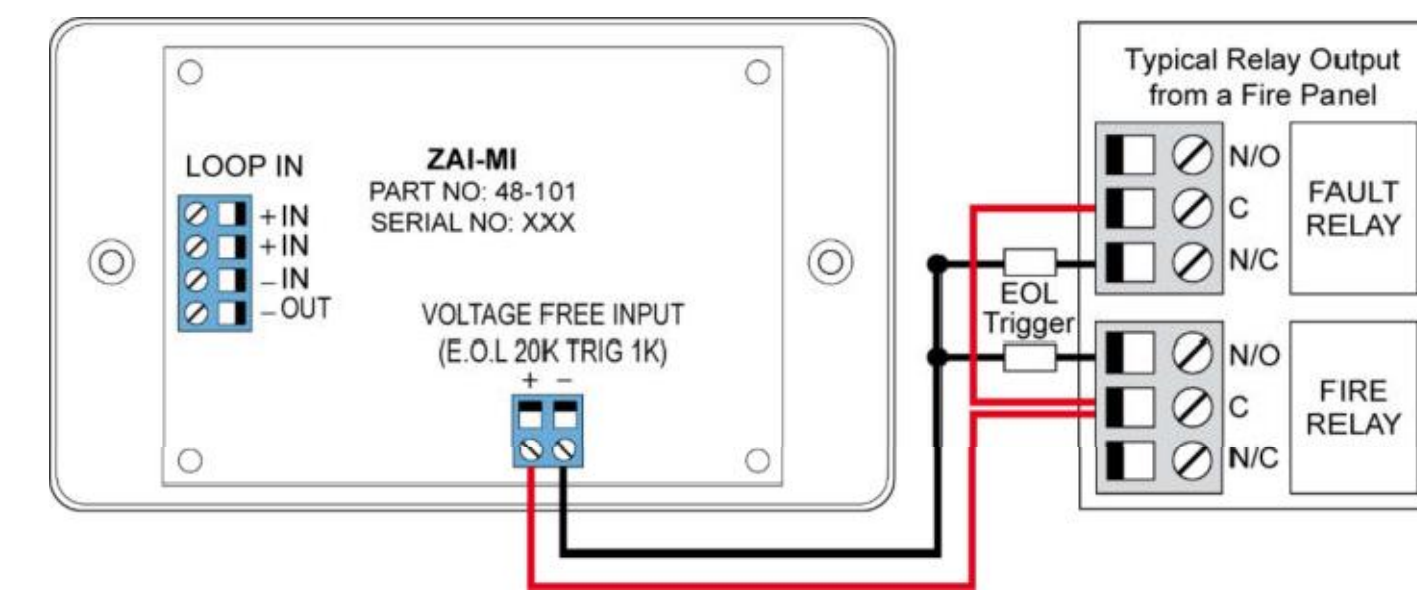

5. ZAI O - MI Input/output Module

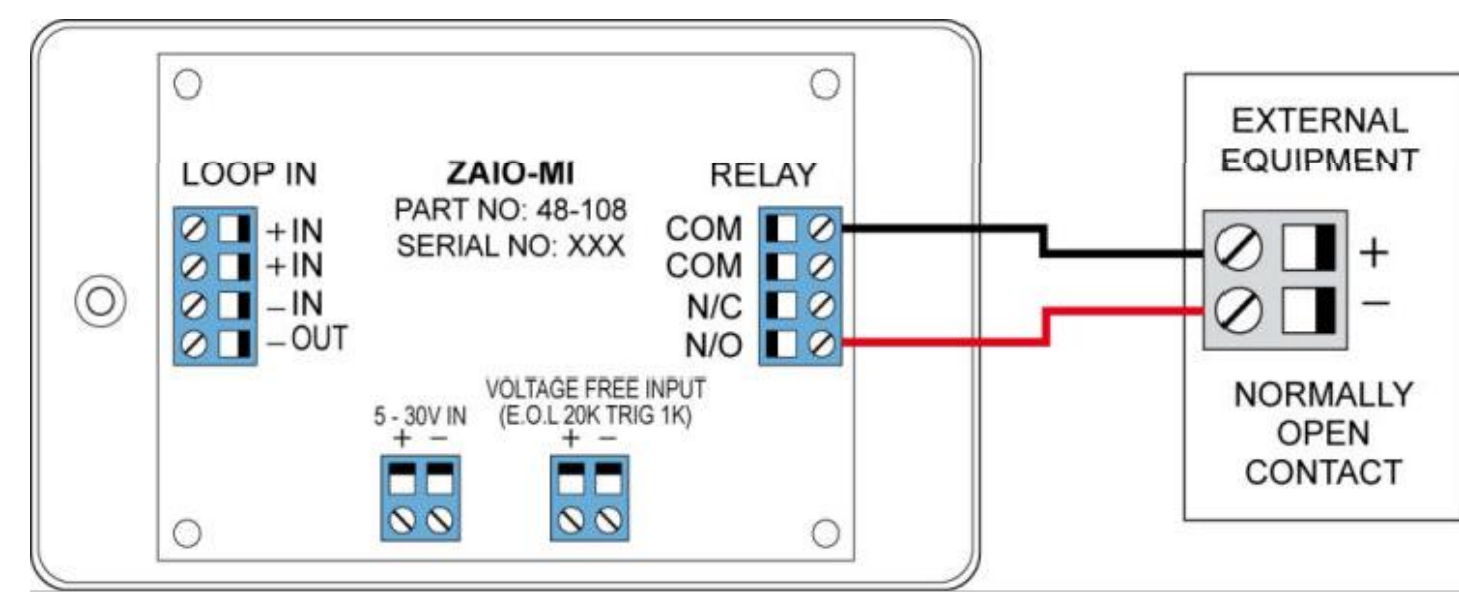

6. ZASC - MI Sounder Control Module

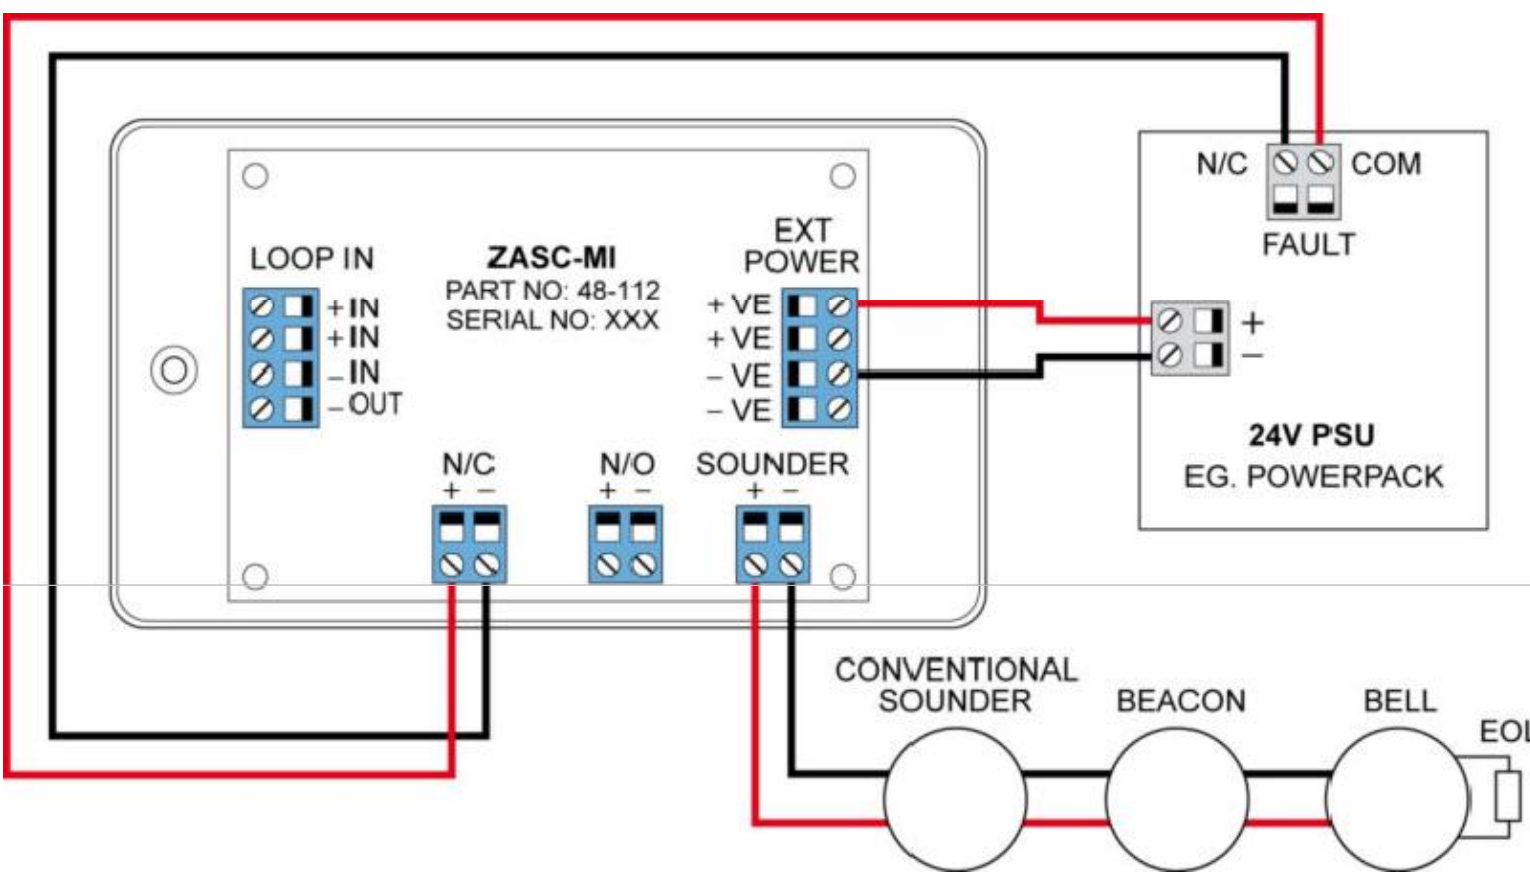

ENGINEER'S TEAM LTD
Web site: www.engrteam.com
Email: support@engrteam.com

CLIENT: MR AND MRS ANDERTON

ADDRESS: 25 WILBURY AVENUE, HOVE, BN3 6HS

CONFIDENTIALITY STATEMENT:
ALL DRAWINGS AND WRITTEN MATERIALS APPEARING HEREIN CONSTITUTE THE ORIGINAL AND UNPUBLISHED WORK OF THE DESIGNER AND THE SAME MAY NOT BE DUPLICATED, USED OR DISCLOSED WITHOUT CONSENT OF THE DESIGNER.

NOTES:
1. ALL DIMENSIONS HEREIN ARE IN IMPERIAL UNITS UNLESS STATED OTHERWISE.
2. THESE DRAWINGS ARE TO BE READ IN CONJUNCTION WITH ALL RELEVANT DESIGNER, ENGINEER OR SPECIALIST DRAWINGS AND SPECIFICATIONS.
3. THE CONTRACTOR MUST CHECK ALL DIMENSION AT SITE BEFORE COMMENCING WORK.
4. THE CONTRACTOR IS RESPONSIBLE FOR PROVIDING ALL NECESSARY TEMPORARY SUPPORT TO THE BUILDING AND ANY ADJACENT STRUCTURES.

REV. NO.	DESCRIPTION	DATE	BY
01	Add Grease Trap & update the plumbing plans	03/02/26	AA
02	Create leak detection, Gas & Fire protection etc plans	06/27/26	AA
03	Fix HVAC system and add new system	07/21/26	AA
04	Change VRF system & Fix Ventilation	07/27/26	AA
05	Provide more information about the HVAC system	08/04/26	AA
05	HVAC Elevation Plan & Filtrations Specification.	08/16/26	AA

PROJECT: 25 WILBURY AVENUE		
TITLE: SMART CONNECTION INSTALLATION		
PROJ. NO.	PROJ. ENGR.	SCALE @ 24X36: 1:100
DATE : September 14, 2026		
DRAWING NO. L S - 4	REV. 6	

GENERAL SPECIFICATIONS

1. GENERAL (All specifications on this sheet as applicable)
- A. Work indicated on these drawings is diagrammatic and shall not be scaled. The drawings are intended to convey the scope of works and indicate the general arrangement of engineered systems. The Contractor shall verify all existing site conditions, dimensions, and services and make all necessary adjustments to complete the works in accordance with the Contract Documents.
- B. Provide all labour, materials, plant, tools, equipment, and services required to execute the works in accordance with the Contract Documents. All supplementary or incidental items necessary for a complete, safe, and fully operational installation shall be deemed included, whether or not specifically shown, at no additional cost to the Client.
- C. All equipment under this contract shall be fully installed, tested, commissioned, and left operational to the satisfaction of the Client and Engineer. These drawings are intended to represent finished works, tested and ready for use. Wherever the word "provide" is used, it shall mean supply, install, test, and commission complete.
- D. All materials and equipment shall be new, of first quality, UKCA/CE marked where applicable, and compatible with existing systems. Installation shall be carried out strictly in accordance with manufacturers' recommendations, relevant British Standards, and recognised good engineering practice.
- E. Where existing pipework, ductwork, containment, cabling, or other obstructions are encountered, the Contractor shall remove, reroute, rearrange, or relocate such items as necessary, subject to approval, at no additional cost.
- F. The Contractor shall obtain written approval prior to cutting or forming penetrations through slabs, walls, ceilings, roofs, or shafts for services. All disturbed areas shall be made good using matching materials and finishes. All penetrations through fire-resisting elements shall be sealed with approved fire-stopping systems to maintain fire integrity in accordance with Building Regulations Approved Document B.
- G. The Contractor shall maintain a clean and safe site at all times. Waste and debris shall be removed regularly. Upon completion, all tools, surplus materials, and temporary works shall be removed and the site left clean and ready for occupation.
2. COORDINATION AND PROGRAMMING
- A. The Contractor shall fully coordinate and programme the works of all trades. All existing site conditions shall be verified to avoid conflicts in routing, sequencing, and installation.
- B. The Contractor shall be responsible for full coordination between all subcontractors, suppliers, statutory authorities, utility providers, Building Control, the Architect/Engineer, building management, and the Client.
- C. No work shall commence until accurate site measurements and verification of existing structures, ceilings, services, and retained installations have been completed, where these may affect the installation of new systems or equipment.
- D. Works shall be phased and programmed to minimise disruption to occupied areas. A detailed programme shall be submitted for approval. Temporary partitions, dust control, and protective barriers shall be provided where necessary.
- E. The Contractor shall provide a minimum of fourteen (14) days' written notice prior to any required shutdown of utilities and shall obtain written approval before proceeding.
- F. The Contractor shall be deemed to have examined the premises and understood all conditions under which the works are to be carried out. No allowance shall be made for errors or omissions arising from failure to inspect the site.
3. CODES, PERMITS, AND INSPECTIONS (UK)
- A. All works shall be carried out in accordance with the latest applicable UK legislation, regulations, and standards. The Contractor shall obtain and pay for all required permits and approvals and arrange all inspections by the relevant Authorities Having Jurisdiction.
- B. Final approval and sign-off by Building Control and all relevant authorities shall be obtained at project completion. All completion certificates shall be issued and provided to the Client.
- C. Works shall comply with the current editions of all applicable British Standards, Building Regulations, and statutory requirements enforced at the project location.
- D. Codes and standards referenced represent minimum requirements. Where Contract Documents require a higher standard, the Contract Documents shall take precedence. Any conflicts shall be reported in writing prior to commencement.
- E. The Contractor shall comply with all Health and Safety Executive (HSE) requirements, including the Health and Safety at Work Act 1974 and CDM Regulations 2015.
- F. The Contractor shall comply with all requirements of statutory utility providers and local authorities.
4. WARRANTY
- A. All works shall be free from defects in workmanship and materials for a period of twelve (12) months from the date of Practical Completion. Any defects arising within this period shall be rectified by the Contractor at no additional cost.
5. SHOP DRAWINGS
- A. Shop drawings and product data shall be submitted electronically to the Engineer, Architect, and Client for approval. Submittals shall include manufacturers' technical data and certified performance information for all new equipment.
6. RECORD DRAWINGS / AS-BUILTS
- A. The Contractor shall maintain a complete and up-to-date set of marked-up drawings on site, recording all changes made during construction. Final as-built drawings and associated documentation shall be submitted to the Client upon completion of the works.

PLUMBING GENERAL NOTES & SPECIFICATIONS

- A. All water supply and vent pipework shall be routed as high as practicable and concealed above ceilings unless noted otherwise. All soil and waste pipework shall be routed as high as practicable below floor slab or floor structure unless noted otherwise.
- B. All soil and waste pipework shall be installed at gradients appropriate to pipe size and in accordance with BS EN 12056 and Approved Document H. All gradients and invert levels shall be verified prior to installation to ensure correct falls are maintained. The Contractor shall confirm that pipe routes and connections are feasible before commencing works.
- C. Provide complete and proper soil, waste, vent, hot water, and cold water connections to all fixtures and equipment, whether or not all branches, fittings, or connectors are shown on the drawings. Refer to sanitary waste and water riser diagrams for pipe sizes and system configuration.
- D. The potable water system shall be flushed, cleaned, and disinfected in accordance with BS EN 806, Water Supply (Water Fittings) Regulations 1999, and local water authority requirements.
- E. The Plumbing Contractor shall coordinate with relevant subcontractors regarding the quantity and locations of access panels required for valves and fittings within walls and ceilings. Access panels shall be provided by the appropriate trade.
- F. Where horizontal water pipework conflicts with vent pipework within wall cavities, the Contractor shall provide additional water pipe drops or alternative routing to maintain compliance and accessibility.
- G. All pipe penetrations below sinks shall be sealed. All pipe penetrations through floor slabs or fire-resisting elements shall be sealed with approved fire-stopping materials in accordance with Approved Document B.
- H. Provide individual isolation valves to all plumbing fixtures and appliances. Valves shall be full-bore WRAS-approved ball valves suitable for potable water systems, with threaded, compression, or soldered connections as appropriate.
- I. The Contractor shall verify on site the exact location, depth, and direction of flow of all existing drainage and sewer pipework within the building and below ground prior to commencement of works.
- J. All pipework shall be adequately supported from existing or new structure using suitable proprietary pipe hangers and supports. Design, selection, spacing, and installation shall comply with relevant British Standards, manufacturers' recommendations, and good engineering practice.
- K. Slab Penetrations: Prior to any cutting or coring of slabs, suitable detection methods (such as ground-penetrating radar or equivalent) shall be used to identify reinforcement, post-tensioning cables, services, or conduits. Written approval from the Structural Engineer shall be obtained before proceeding.
- L. The Contractor shall make good all existing finishes, surfaces, and elements damaged during construction to match existing, unless otherwise noted.
- M. Provide and install dielectric or insulating unions where connections are made between dissimilar metals, as required to prevent galvanic corrosion.
- N. No new pipework shall be installed above new or existing electrical switchboards, distribution boards, panelboards, or motor control centres.
- O. Provide escutcheon plates at all locations where pipework passes through walls, floors, or ceilings. Plates shall fully cover penetration openings or sleeves. Finishes shall be chrome or nickel plated in exposed areas and primed/painted finish in concealed areas.

PLUMBING PIPING & INSULATION

- DOMESTIC WATER PIPING
1. Above ground domestic water pipework shall be copper tube manufactured in accordance with BS EN 1057, hard-drawn (R250) temper, complete with wrought copper fittings. Joints shall be made using lead-free solder and non-corrosive flux suitable for potable water systems, installed in accordance with Water Supply (Water Fittings) Regulations 1999.
2. Provide full-bore isolation ball valves of dezincification-resistant brass or bronze construction, WRAS-approved for potable water use, with threaded, compression, or soldered ends as appropriate. Valves shall be suitable for the system operating pressure and temperature.
- WASTE AND VENT PIPING
1. Soil, waste, and vent pipework shall be installed in accordance with BS EN 12056 and Approved Document H. Use only one of the following approved materials:
- Cast iron soil pipe systems to BS EN 877
- Copper waste and vent pipework to BS EN 1057
- Galvanised steel pipework where permitted
- All fittings shall be compatible with the selected pipe material and system.
2. Plastic pipework (PVC-U, HDPE, or other approved materials) may be used for cold water, hot water, soil, waste, and vent systems where permitted by Building Regulations and the local authority. All plastic pipework shall be installed in accordance with Approved Document H. Where roofs are accessible or use by the public, all plastic pipework shall terminate at a safe height above roof level in accordance with regulations.
- INSULATION
1. Provide thermal insulation to all pipework and equipment in accordance with BS 5422 and Building Regulations Approved Document L. Insulation materials shall have appropriate fire performance classifications in accordance with BS EN 13501-1. Installation shall comply strictly with the insulation manufacturer's instructions. All cold water pipework shall be provided with a continuous vapour barrier to prevent condensation. External pipework insulation shall be protected with a suitable weather-resistant jacket.
- 1.1. Domestic cold water pipework: minimum 13 mm thickness
- 1.2. Domestic hot water pipework: minimum 25 mm thickness
- 1.3. Domestic circulating hot water pipework: minimum 25 mm thickness

PLUMBING CODE NOTES

1. Condensate Drainage
- Condensate drains shall not be connected to the sanitary sewer system and shall not discharge into mop sinks or similar plumbing fixtures. Condensate shall be disposed of in accordance with applicable plumbing codes and local AHJ requirements.
2. Water Hammer Arrestors
- Provide water hammer arrestors at all quick-closing valves and fixtures, including but not limited to:
- Water closets
 - Dishwashers
 - Clothes washers
- Other solenoid- or fast-acting valve equipment, as applicable
- Water hammer arrestors shall conform to ASSE 1010 and be installed in accordance with manufacturer's recommendations.
3. Trap Seal Protection
- Provide trap primers or approved barrier-type trap seal protection devices for all floor drains subject to evaporation or infrequent use.
- Trap seal protection devices shall comply with ASSE 1072 and shall be installed per the manufacturer's installation instructions.

NATURAL GAS PIPING

1. GENERAL
- Gas installation shall conform to the requirements of the Gas Safety (Installation and Use) Regulations (GSIUR), BS 6891, IGM/UP/2, IGM/UP/1, and all applicable UK standards and Local Authority / Gas Transporter requirements.
2. PIPING
- A. Steel Pipe – 50 mm (2") and Smaller
- Carbon steel pipework shall comply with BS EN 10255 (Medium Grade), black steel, threaded ends. Threaded joints shall be in accordance with BS 21.
- Malleable iron threaded fittings shall comply with BS EN 10242, Class A or B.
- B. Steel Pipe – 65 mm (2½") and Larger
- Carbon steel pipework shall comply with BS EN 10255 (Medium or Heavy Grade), welded joints. Steel butt-weld fittings shall comply with BS EN 10253.
3. VALVE LOCATIONS
- Gas isolation valves shall not be installed within ceiling voids or air plenums and shall remain readily accessible for operation and maintenance in accordance with BS 6891.
4. CONCEALED PIPING
- A. Concealed Locations
- Gas pipework installed in concealed locations shall use approved permanent jointing methods only. The following fittings and joint types are not permitted in concealed locations:
- Unions
 - Compression fittings
 - Gasketed joints
 - Mechanical couplings
 - Bushings
 - Swing joints
 - Running threads
- All concealed joints shall be welded, brazed, or threaded as permitted by UK standards.
- B. Piping in Partitions
- Gas pipework shall not be embedded in solid walls, concrete, or masonry.
- Pipework routed within partitions shall be sleeved or otherwise protected against mechanical damage.
- Pipework passing through walls or partitions shall be sleeved and sealed in accordance with BS 6891.
5. UNIONS
- Where permitted, unions shall comply with BS EN 10242, malleable iron, ground-joint type, suitable for gas service, and installed only in accessible locations.
6. DIELECTRIC JOINTS
- Where dissimilar metals are connected, provide approved insulating joints to prevent galvanic corrosion in accordance with IGM standards and manufacturer recommendations.
7. CORROSION PROTECTION
- Where gas pipework is exposed to corrosive environments or installed externally, pipe and fittings shall be protected using:
- Factory-applied protective coating or
 - Site-applied corrosion protection system suitable for gas installations
- Protection systems shall comply with BS EN ISO 12944 and manufacturer requirements.
8. PLUG VALVES (65 mm and Larger)
- Plug valves shall comply with BS EN 331 or BS EN 13774, suitable for gas service, with a minimum pressure rating appropriate to the system design.
- Gas valves shall not be installed above ceilings.
9. GAS COCKS (50 mm and Smaller)
- Gas cocks shall be:
- CE-marked and approved for gas service
 - Bronze or brass body
 - Suitable for operating pressure and system design
 - Provided with lever or square-headed handle
 - Threaded connections shall comply with BS EN 10222
10. BALL VALVES
- Ball valves shall be:
- Full-bore type
 - CE-marked and approved for gas service
 - Brass or copper body with appropriate seals
 - Rated for the system design pressure
 - Installed in accessible locations only
11. GAS PRESSURE REGULATORS
- Gas pressure regulators shall be:
- CE-marked and approved for gas service
 - Sized for the inlet pressure, outlet pressure, and gas flow rate indicated
 - Installed in well-ventilated, accessible locations
- Regulators shall be vented to atmosphere where required by:
- The Gas Transporter
 - The regulator manufacturer
- Vent piping shall:
- Be of the same material as the gas pipework
 - Discharge externally to a safe, non-hazardous location
 - Terminate with a downward-facing outlet fitted with corrosion-resistant insect screening
12. TESTING AND COMMISSIONING
- Gas pipework shall be pressure tested, purged, and commissioned in accordance with:
- BS 6891
 - IGM/UP/1 or IGM/UP/2
 - Gas Transporter requirements
 - Local Authority and Building Control regulations
- Test certificates shall be submitted prior to system energisation.

PLUMBING SYMBOLS

SYMBOL	ABBREVIATION	DESCRIPTION
		EXISTING PIPING OR EQUIPMENT TO REMAIN
		EXISTING PIPING OR EQUIPMENT TO BE REMOVED
	CW	DOMESTIC COLD WATER
	HW	DOMESTIC HOT WATER
	HWC	DOMESTIC HOT WATER RECIRCULATION
	WP	SANITARY SOIL AND WASTE
	VP	SANITARY VENT
	D	DRAIN LINE
	PD	PUMPED DISCHARGE
	G	NATURAL GAS
	ST	STORM WATER
		PIPE TURNING UP
		PIPE TURNING DOWN
		VALVE IN VERTICAL
		PIPE BRANCH BOTTOM TAKEOFF
		PIPE BRANCH TOP TAKEOFF
		CAPPED PIPE
		BALL VALVE
		CHECK VALVE
		UNION
		GATE VALVE
	PRV	PRESSURE REDUCING VALVE
		GAS COCK
		GAS METER
		COMBINATION BALANCING AND SHUT-OFF VALVE
	FDC	FIRE DEPARTMENT CONNECTION
		PIPE DIRECTION OF FLOW
	FD	FLOOR DRAIN
		POINT OF REMOVAL
		POINT OF CONNECTION TO EXISTING
		KEYED NOTE, DEMOLITION
		KEYED NOTE, NEW WORK

ABBREVIATIONS

(E)	EXISTING TO REMAIN	KW	KILOWATTS
(R)	EXISTING TO BE REMOVED AND RELOCATED	L	LAVATORY
(RE)	RELOCATED EQUIPMENT	LB	POUNDS
(X)	DEMOLISHED EQUIPMENT	MAX	MAXIMUM
ABV	ABOVE	MECH	MECHANICAL
AFF	ABOVE FINISHED FLOOR	MBH	THOUSANDS OF BTU'S PER HOUR
BFP	BACKFLOW PREVENTER	MIN	MINIMUM
BTU	BRITISH THERMAL UNITS	MS	MOP SINK
CISPI	CAST IRON SOIL PIPE INSTITUTE	NSF	NATIONAL SANITARY FOUNDATION
CLG	CEILING	OD	OVERFLOW DRAIN
CO	CLEANOUT	OSD	OPEN SITE DRAIN
CONT	CONTINUATION	PH	PHASE
CM	COFFEE MAKER	PSI	POUNDS PER SQUARE INCH
DF	DRINKING FOUNTAIN	RD	ROOF DRAIN
DFU	DRAINAGE FIXTURE UNITS	REF	REFRIGERATOR
DN	DOWN	RL	RAIN LEADER
DW	DISHWASHER	SH	SHOWER
DWG	DRAWING	SK	SINK
EA	EACH	SQ FT	SQUARE FOOT, FEET
ELEC	ELECTRIC, ELECTRICAL	SS	SERVICE SINK
ELEV	ELEVATION	TPV	TRAP PRIMER VALVE
EW	ELECTRIC WATER COOLER	TS	TAMPER SWITCH
°F	DEGREES FAHRENHEIT	TYP	TYPICAL
FCO	FLOOR CLEANOUT	U	URINAL
FD	FLOOR DRAIN	V	VOLT, VOLTS
GAL	GALLON, GALLONS	VS	VENT STACK
GD	GARBAGE DISPOSAL	VTR	VENT THROUGH ROOF
GPH	GALLONS PER HOUR	WI	WITH
GPM	GALLONS PER MINUTE	WC	WATER CLOSET
HB	HOSE BIB	WH	WATER HEATER
HD	HUB DRAIN	WHA	WATER HAMMER ARRESTOR
IM	ICE MAKER	WS	WASTE STACK
INV	INVERT ELEVATION		



ENGINEER'S TEAM LTD

Web site: www.engrteam.com
Email: support@engrteam.com

CLIENT: MR AND MRS ANDERTON

ADDRESS: 25 WILBURY AVENUE,
HOVE, BN3 6HS

CONFIDENTIALITY STATEMENT:
ALL DRAWINGS AND WRITTEN MATERIALS
APPEARING HEREIN CONSTITUTE THE
ORIGINAL AND UNPUBLISHED WORK OF THE
DESIGNER AND THE SAME MAY NOT BE
DUPLICATED, USED OR DISCLOSED WITHOUT
CONSENT OF THE DESIGNER.

NOTES:
1. ALL DIMENSIONS HEREIN ARE IN IMPERIAL
UNITS UNLESS STATED OTHERWISE.
2. THESE DRAWINGS ARE TO BE READ IN
CONJUNCTION WITH ALL RELEVANT DESIGNER,
ENGINEER OR SPECIALIST DRAWINGS AND
SPECIFICATIONS.
3. THE CONTRACTOR MUST CHECK ALL
DIMENSION AT SITE BEFORE COMMENCING
WORK.
4. THE CONTRACTOR IS RESPONSIBLE FOR
PROVIDING ALL NECESSARY TEMPORARY
SUPPORT TO THE BUILDING AND ANY ADJACENT
STRUCTURES.

REFERENCE:
0146-ETE-110CS-GF-DR-P-40502

REV. NO.	DESCRIPTION	DATE	BY
01	Add Grease Trap & update the plumbing plans	03/02/26	AA
02	Create leak detection, Gas & Fire protection etc plans	06/27/26	AA
03	Fix HVAC system and add new system	07/21/26	AA
04	Change VRF system & Fix Ventilation	07/27/26	AA
05	Provide more information about the HVAC system	08/04/26	AA
05	HVAC Elevation Plan & Filtrations Specification.	08/16/26	AA

PROJECT: 25 WILBURY AVENUE

TITLE: GENERAL NOTE FOR
PLUMBING PLAN

PROJ. NO. PROJ. ENGR. SCALE @ 24X36:
1:100

DATE : September 14, 2026

DRAWING NO. M - 0
REV. 6



ADDRESS:
25 WILBURY AVENUE,
HOVE, BN3 6HS

CONFIDENTIALITY STATEMENT:
ALL DRAWINGS AND WRITTEN MATERIALS
APPEARING HEREIN CONSTITUTE THE
ORIGINAL AND UNPUBLISHED WORK OF THE
DESIGNER AND THE SAME MAY NOT BE
DUPLICATED, USED OR DISCLOSED WITHOUT
CONSENT OF THE DESIGNER.

NOTES:

1. ALL DIMENSIONS HEREIN ARE IN IMPERIAL UNITS UNLESS STATED OTHERWISE.
2. THESE DRAWINGS ARE TO BE READ IN CONJUNCTION WITH ALL RELEVANT DESIGNER, ENGINEER OR SPECIALIST DRAWINGS AND SPECIFICATIONS.
3. THE CONTRACTOR MUST CHECK ALL DIMENSION AT SITE BEFORE COMMENCING WORK.
4. THE CONTRACTOR IS RESPONSIBLE FOR PROVIDING ALL NECESSARY TEMPORARY SUPPORT TO THE BUILDING AND ANY ADJACENT STRUCTURES.

REFERENCE:
0146-ETE-110CS-GF-DR-P-40502

REV. NO.	DESCRIPTION	DATE	BY
01	Add Grease Trap & update the plumbing plans	03/02/26	AJ
02	Create leak detection, Gas & Fire protection etc plans	06/27/26	AJ
03	Fix HVAC system and add new system	07/21/26	AJ
04	Change VRF system & Fix Ventilation	07/27/26	AJ
05	Provide more information about the HVAC system	08/04/26	AJ
05	HVAC Elevation Plan & Filtrations specified	08/16/26	AJ

PROJECT: 25 WILBURY AVENUE

TITLE: **PROPOSED PLUMBING
LAYOUT PLAN**

PROJ. NO.	PROJ. ENGR.	SCALE @ 24X36 1:100
-----------	-------------	------------------------

DATE : September 14, 2026

DRAWING NO.	REV.
M - 1	6

Important Note

1. There was a rusted pipe visible from the basement ceiling, under the kitchen area, right above the existing fuse box. The pipe was suggested to be replaced.
2. The drainage pipe in the basement storage room under the ceiling was requested to make sure it doesn't have any leak.

WATER DEMAND CALCULATION

Design Standards
BS EN 806
CIBSE Guide G
UK Water Supply (Water Fittings) Regulations
Diversity applied for simultaneous use

FIXTURE & EQUIPMENT FLOW RATES			
FIXTURE / EQUIPMENT	QTY	UNIT FLOW RATE	TOTAL
Tiling/tilling floor waste sink	1	12 L/min	12
Sie-basket electric noodle cooker	1	10 L/min	10
Kitchen sink	6	8 L/min	48
Glass washer	1	6 L/min	6
WC (total)	1	6 L/min (equiv.)	6
Wash hand basin	1	6 L/min	6
TOTAL CONNECTED LOAD		50 L/min	

Diversity Factor
For restaurant and commercial kitchen use:
Diversity factor applied: 0.5
Peak Water Demand:
 $88 \times 0.5 = 44 \text{ L/min}$
Peak Demand = 44 L/min $\approx 0.73 \text{ L/s}$

Water Demand Summary

Design Peak Demand: 44 L/min (0.73 L/s)
Adequate for incoming mains supply and internal pipe sizing
No abnormal increase to base building water demand

WATER DEMAND DESIGN NOTE

Water demand for the restaurant has been calculated in accordance with BS EN 800-BSSE Guide G, and the UK Water Supply (Water Fittings) Regulations.

The total connected water load is approximately 1.0 L/min. A diversity factor of 0.5 has been applied to reflect realistic simultaneous usage resulting in a peak design water demand of approximately 44 L/min (0.73 L/s).

The proposed water demand can be accommodated by the existing building water supply without adverse impact.



The proposed water demand can be accommodated by the existing building water supply without adverse impact.

PLUMBING | LEGEND

- | | |
|---|--------------------------|
|  | BALL VALVE (BV) |
|  | GATE VALVE (GV) |
|  | MIXING VALVE (MV) |
|  | FLOOR CLEAN OUT (FCO) |
|  | FLOOR DRAIN (FD) |
|  | HUB DRAIN (HD) |
|  | FLOOR SINK (FS) |
|  | PIPE TURNING UP |
|  | PIPE TURNING DOWN |
|  | INSTANT WATER HEATER |
|  | SPRINKLER |
|  | SUB WATER METER |
|  | WATER METER |
|  | PRV |
| | PRESSURE REDUCING VALVE |
| | TRACE HEATING COMPONENTS |

LINE#	TYPE	LEGEND
1	1	1
2	2	2
3	3	3
100	100	100

	COLD WATER LINE (CW)
	HOT WATER LINE (HW)
	SEWER LINE (S)
	GAS LINE (G)

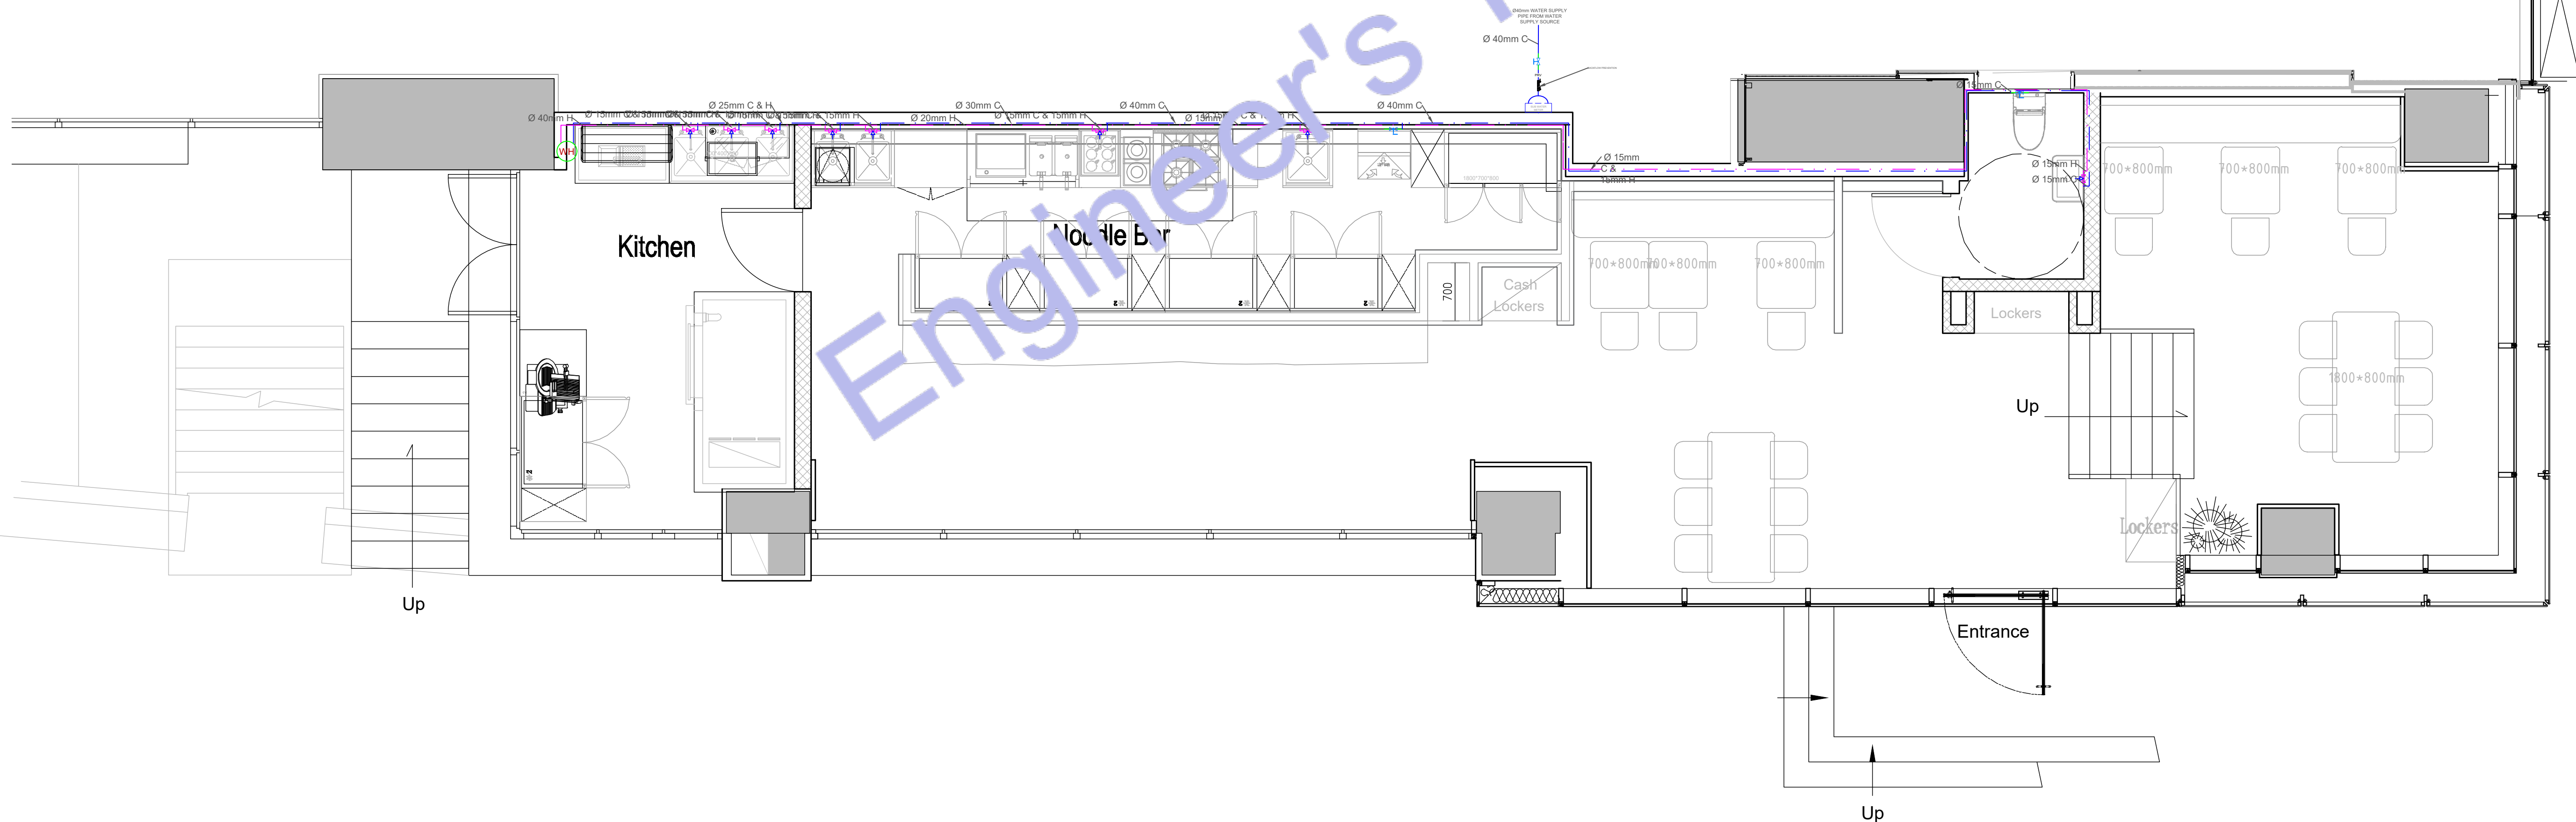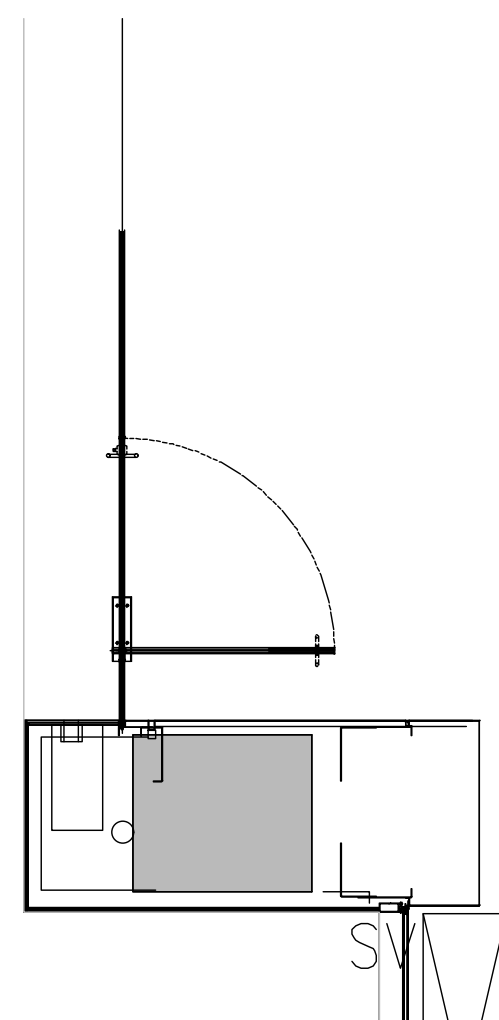



ENGINEER'S TEAM LTD

Web site: www.engrteam.com
Email: support@engrteam.com

CLIENT: MR AND MRS ANDERTON

ADDRESS: 25 WILBURY AVENUE,
HOVE, BN3 6HS

CONFIDENTIALITY STATEMENT:
ALL DRAWINGS AND WRITTEN MATERIALS
APPEARING HEREIN CONSTITUTE THE
ORIGINAL AND UNPUBLISHED WORK OF THE
DESIGNER AND THE SAME MAY NOT BE
DUPLICATED, USED OR DISCLOSED WITHOUT
CONSENT OF THE DESIGNER.

NOTES:
1. ALL DIMENSIONS HEREIN ARE IN IMPERIAL
UNITS UNLESS STATED OTHERWISE.
2. THESE DRAWINGS ARE TO BE READ IN
CONJUNCTION WITH ALL RELEVANT DESIGNER,
ENGINEER OR SPECIALIST DRAWINGS AND
SPECIFICATIONS.
3. THE CONTRACTOR MUST CHECK ALL
DIMENSION AT SITE BEFORE COMMENCING
WORK.
4. THE CONTRACTOR IS RESPONSIBLE FOR
PROVIDING ALL NECESSARY TEMPORARY
SUPPORT TO THE BUILDING AND ANY ADJACENT
STRUCTURES.

REFERENCE:
0146-ETE-110CS-GF-DR-P-40502

REV. NO.	DESCRIPTION	DATE	BY
01	Add Grease Trap & update the plumbing plans	03/02/26	AA
02	Create leak detection, Gas & Fire protection etc plans	06/27/26	AA
03	Fix HVAC system and add new system	07/21/26	AA
04	Change VRF system & Fix Ventilation	07/27/26	AA
05	Provide more information about the HVAC system	08/04/26	AA
05	HVAC Elevation Plan & Filtrations Specification.	08/16/26	AA

PROJECT: 25 WILBURY AVENUE		
TITLE: PROPOSED SEWER LAYOUT PLAN		
PROJ. NO.	PROJ. ENGR.	SCALE @ 24X36: 1:100
DATE : September 14, 2026		
DRAWING NO. M - 2		REV. 6

Drainage Installation Note:

All drainage and waste pipework shall be installed to appropriate falls in accordance with BS EN 12056 and Building Regulations to ensure effective gravity drainage.

Existing basement drainage pipe shall be inspected, repaired or replaced where leakage is identified.

Automatic Grease Recovery Unit (AGRU)


All commercial kitchen sinks and grease-producing fixtures shall discharge through an Automatic Grease Recovery Unit (AGRU). Traditional passive grease traps shall not be used. The AGRU shall be installed in accordance with the manufacturer's recommendations and shall be located to provide safe access for inspection, maintenance, and grease removal. The unit shall be positioned away from dishwasher discharge to prevent emulsified grease from reducing separation efficiency.

GENERAL NOTES

Provide Automatic Grease Recovery Units (AGRU) for all kitchen grease waste lines in accordance with the Employer's Requirements.
Install a leak detection system beneath all kitchen and bar water services. The system shall automatically alarm and initiate water shut-off upon leak detection where required.
All pipe penetrations through fire-rated walls and floors shall be sealed using approved fire stopping systems, including fire collars, fire-rated sealants, and mineral wool, to maintain the required fire resistance.
Waterproof all penetrations through floors, walls, and wet areas using approved waterproof sealing systems to prevent water ingress and moisture migration.
All plumbing installations shall comply with the Building Regulations, Water Supply (Water Fittings) Regulations, BS EN Standards, and manufacturer installation requirements.

SEWERAGE LEGEND

	WASTE WATER/ SEWER LINE (UPVC PIPE)
	TOILET WASTE/ SEWER LINE (UPVC PIPE)
	GREASE TRAP (PTLGT-18) 650x450x325

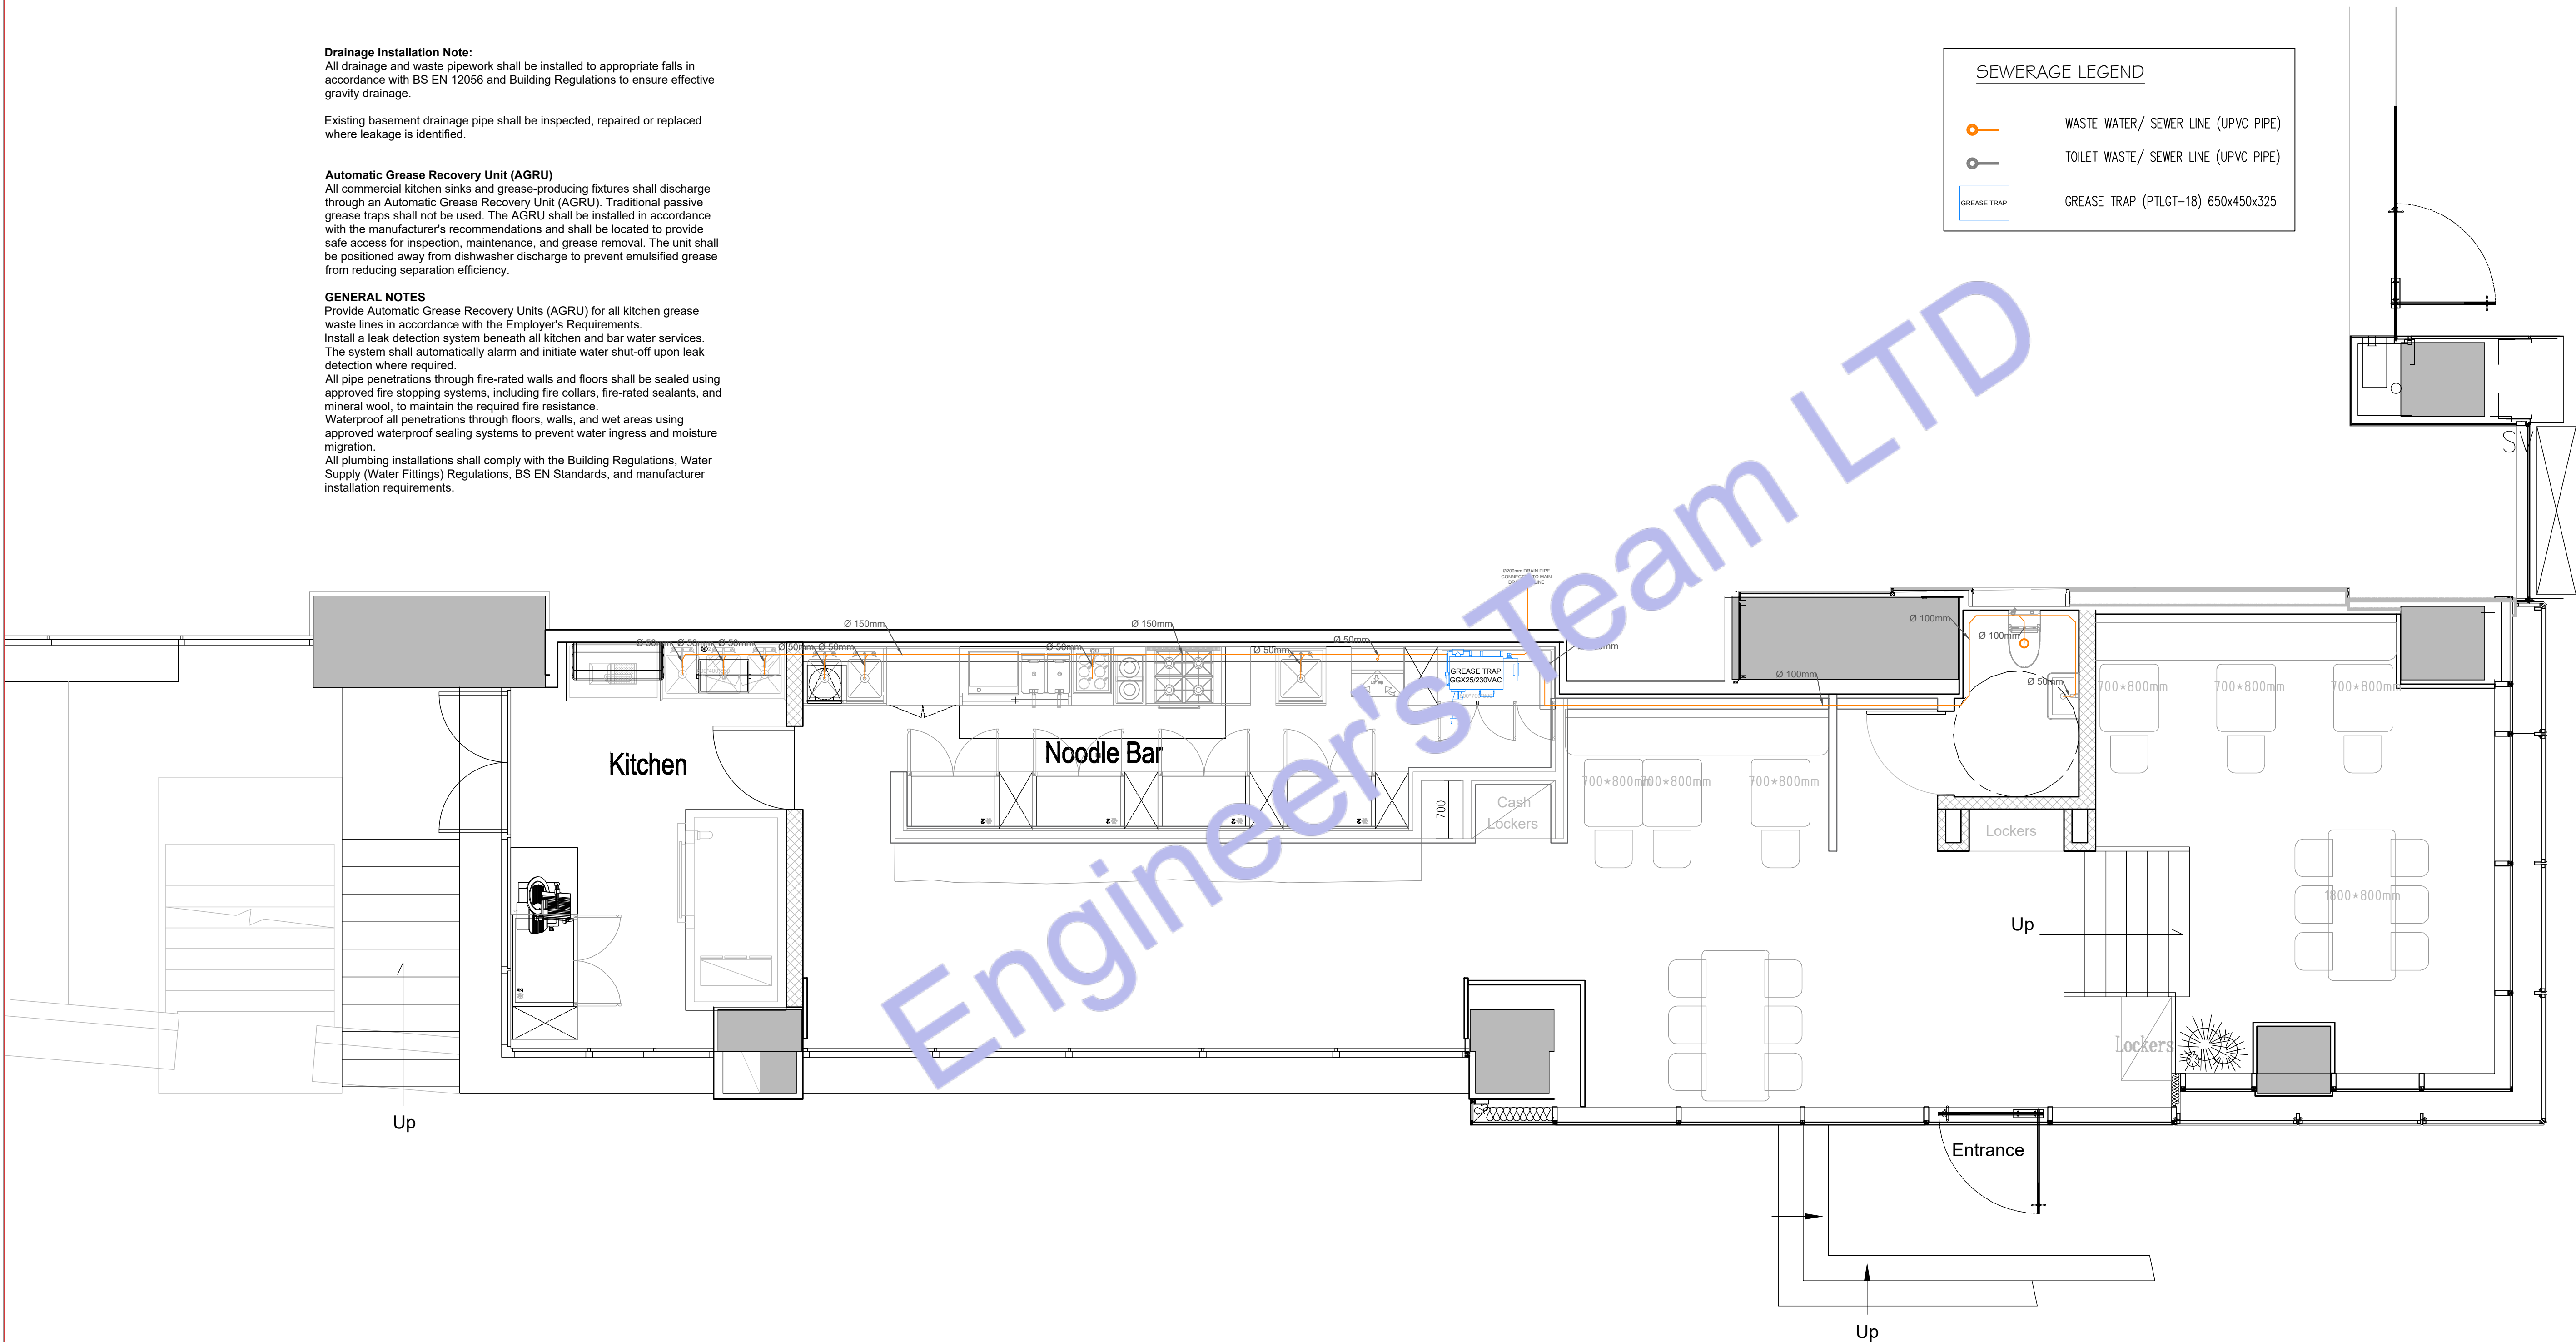



CLIENT: MR AND MRS ANDERTON

ADDRESS:
25 WILBURY AVENUE,
HOVE, BN3 6HS

CONFIDENTIALITY STATEMENT:
ALL DRAWINGS AND WRITTEN MATERIALS
APPEARING HEREIN CONSTITUTE THE
ORIGINAL AND UNPUBLISHED WORK OF THE
DESIGNER AND THE SAME MAY NOT BE
DUPLICATED, USED OR DISCLOSED WITHOUT
CONSENT OF THE DESIGNER.

NOTES:

1. ALL DIMENSIONS HEREIN ARE IN IMPERIAL UNITS UNLESS STATED OTHERWISE.
2. THESE DRAWINGS ARE TO BE READ IN CONJUNCTION WITH ALL RELEVANT DESIGNER, ENGINEER OR SPECIALIST DRAWINGS AND SPECIFICATIONS.
3. THE CONTRACTOR MUST CHECK ALL DIMENSION AT SITE BEFORE COMMENCING WORK.
4. THE CONTRACTOR IS RESPONSIBLE FOR PROVIDING ALL NECESSARY TEMPORARY SUPPORT TO THE BUILDING AND ANY ADJACENT STRUCTURES.

REFERENCE:
0146-ETE-110CS-GF-DR-P-40502

REV. NO	DESCRIPTION	DATE	BY
01	Add Grease Trap & update the plumbing plans	03/02/26	AA
02	Create leak detection, Gas & Fire protection etc details	06/27/26	AA
03	Fix HVAC system and add new system	07/21/26	AA
04	Change VRF system & Fix Ventilation	07/27/26	AA
05	Provide more information about the HVAC system	08/04/26	AA
05	HVAC Elevation Plan & Filtrations Specification.	08/16/26	AA


PROJECT: 25 WILBURY AVENUE


TITLE: **PROPOSED WATER LEAK
DETECTION SYSTEM**

PROJ. NO.	PROJ. ENGR.	SCALE @ 24X36: 1:100
-----------	-------------	-------------------------

DATE : September 14, 2026

DRAWING NO.	REV.
M - 3	6

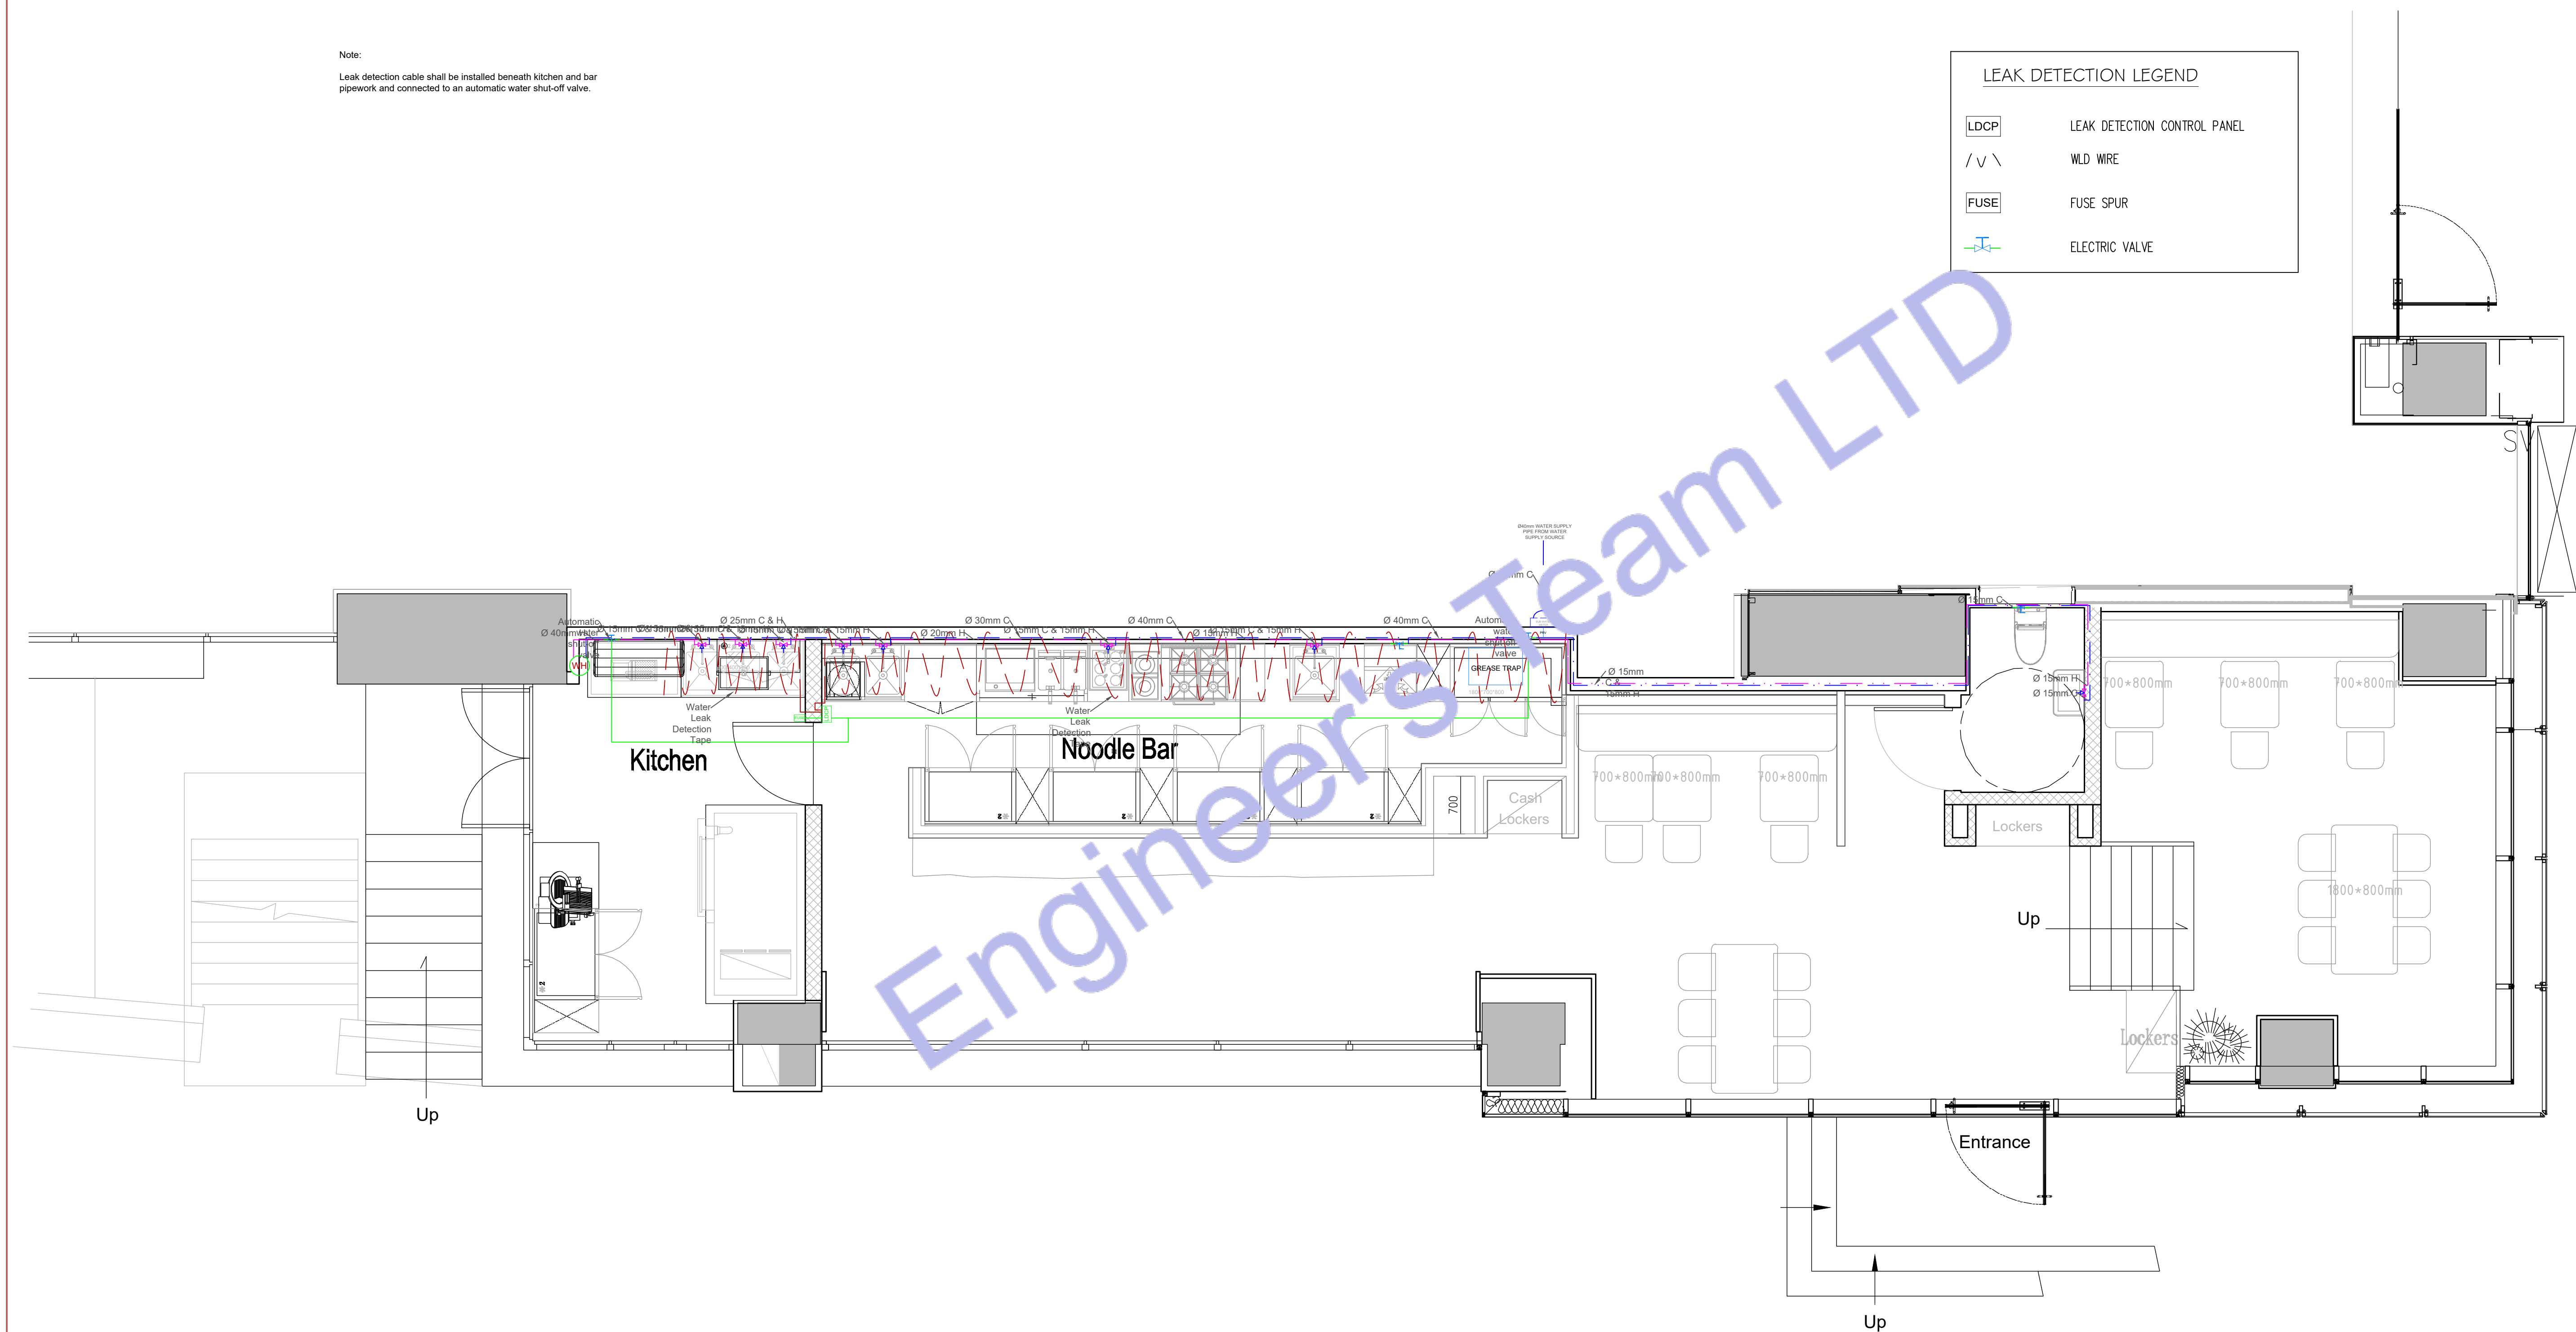

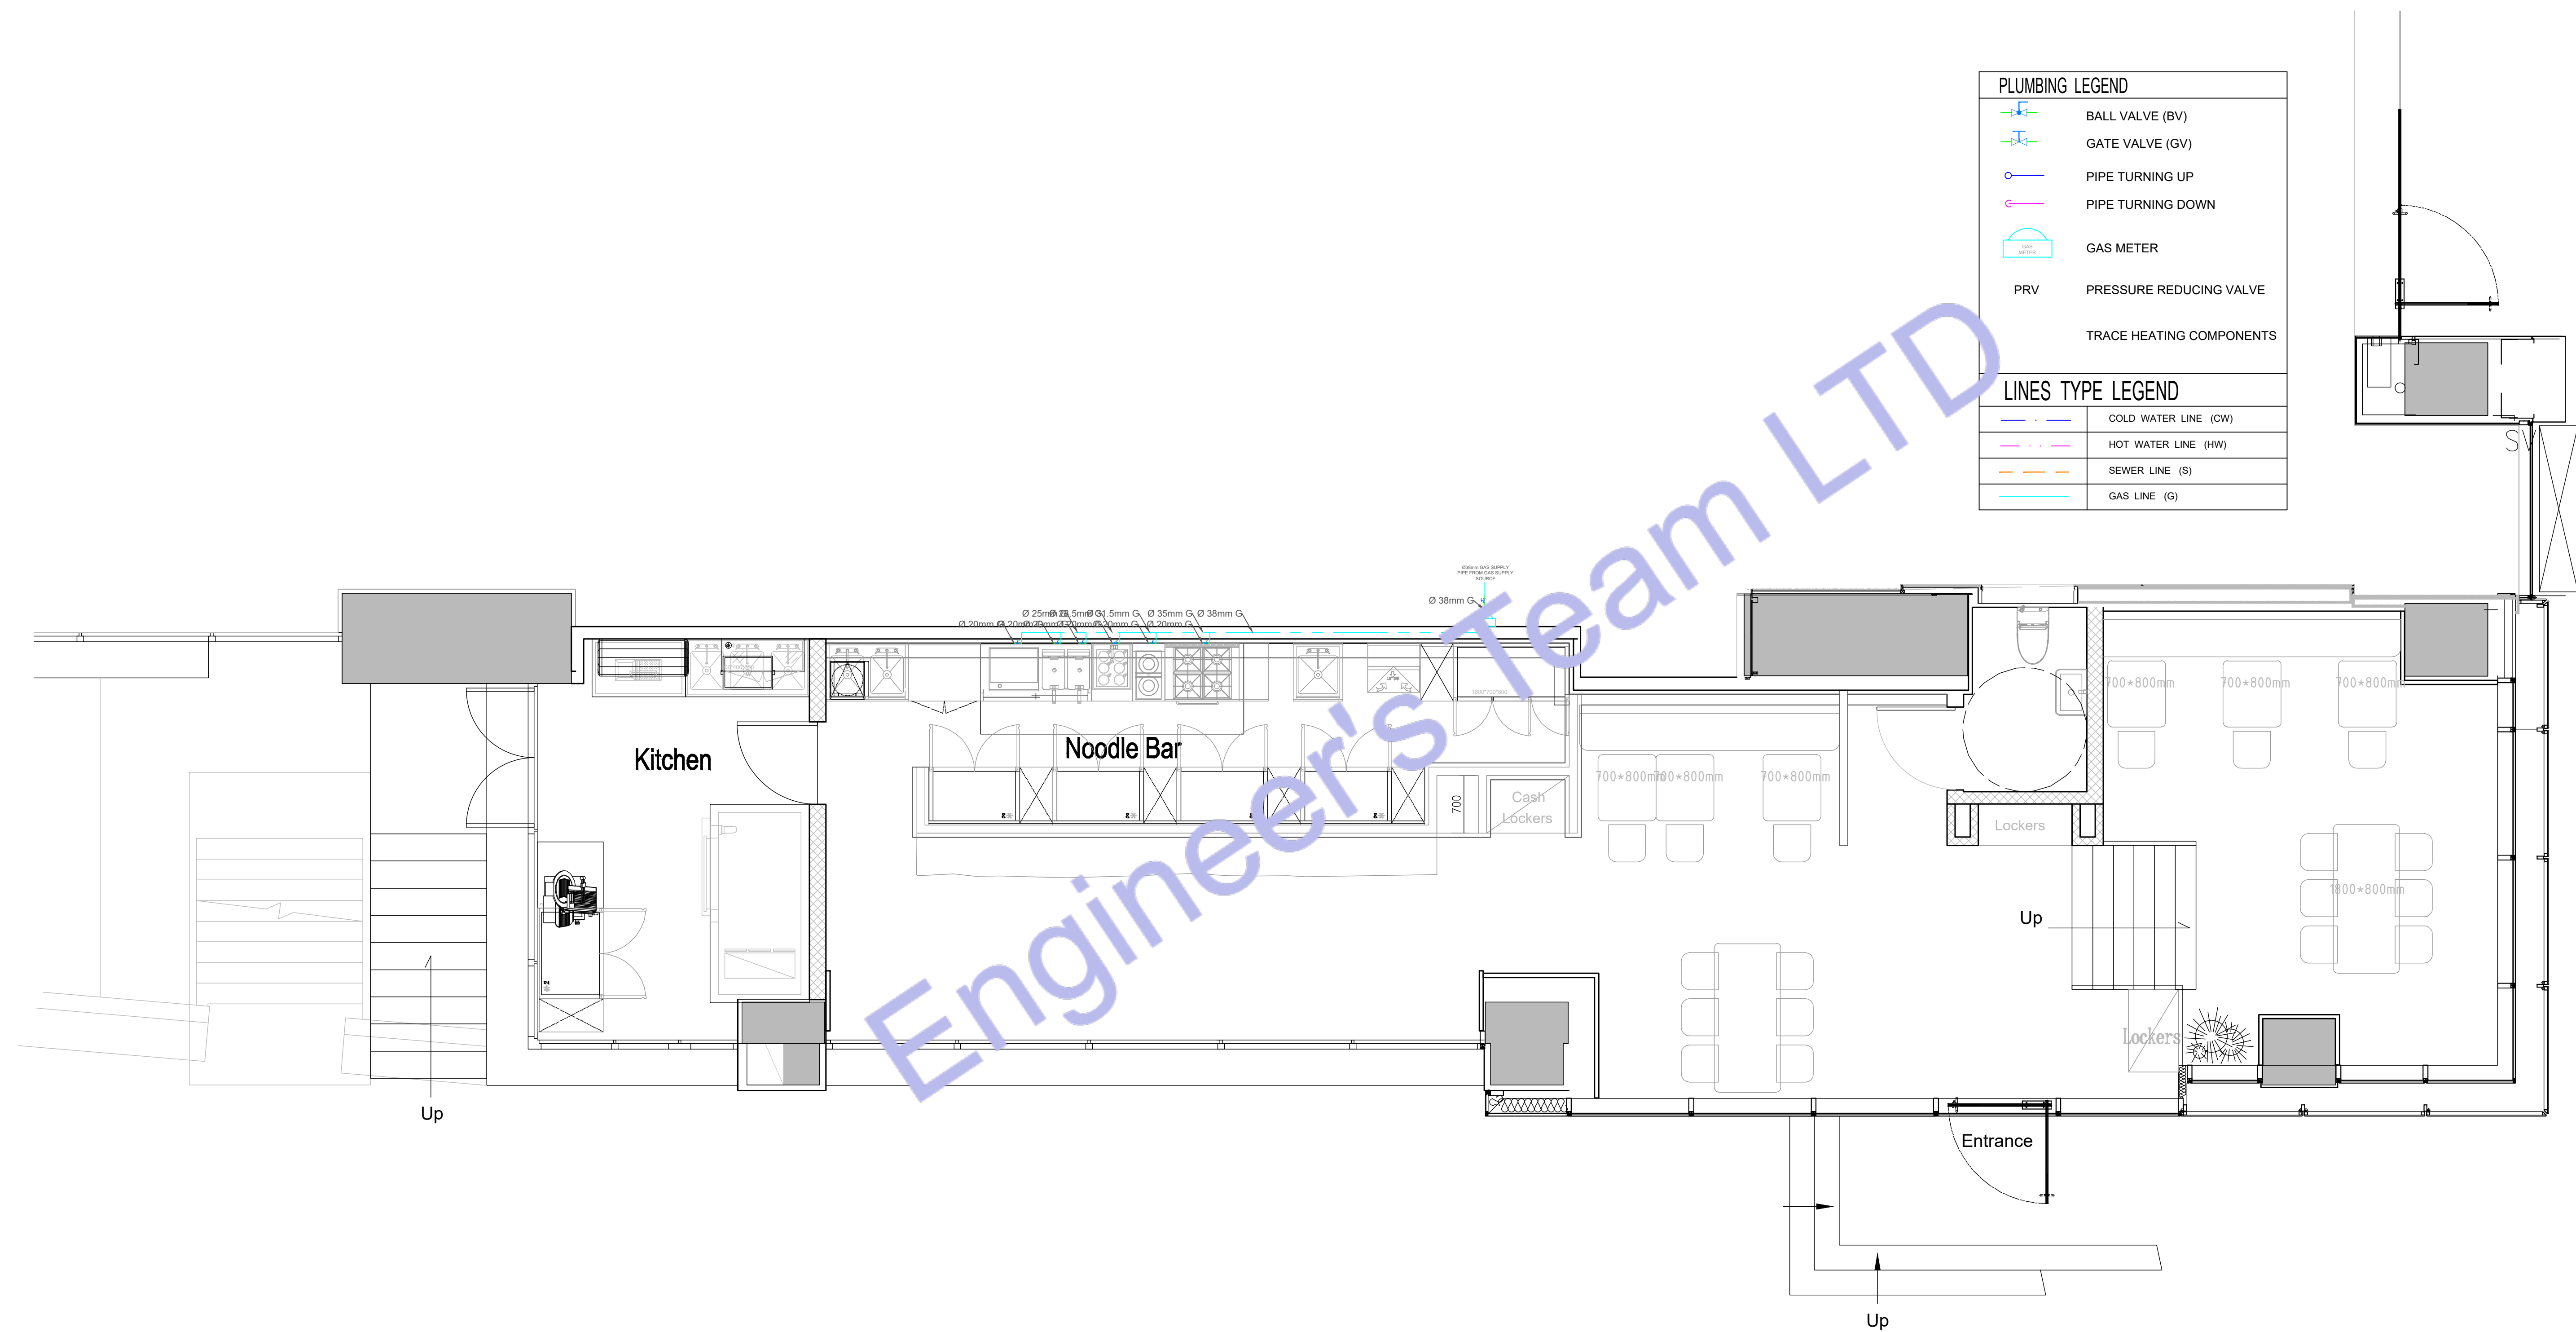

ENGINEER'S TEAM LTD
Web site: www.engrteam.com
Email: support@engrteam.com

CLIENT: MR AND MRS ANDERTON

ADDRESS:
25 WILBURY AVENUE,
HOVE, BN3 6HS

CONFIDENTIALITY STATEMENT:
ALL DRAWINGS AND WRITTEN MATERIALS
APPEARING HEREIN CONSTITUTE THE
ORIGINAL AND UNPUBLISHED WORK OF THE
DESIGNER AND THE SAME MAY NOT BE
DUPLICATED, USED OR DISCLOSED WITHOUT
CONSENT OF THE DESIGNER.

NOTES:
1. ALL DIMENSIONS HEREIN ARE IN IMPERIAL
UNITS UNLESS STATED OTHERWISE.
2. THESE DRAWINGS ARE TO BE READ IN
CONJUNCTION WITH ALL RELEVANT DESIGNER,
ENGINEER OR SPECIALIST DRAWINGS AND
SPECIFICATIONS.
3. THE CONTRACTOR MUST CHECK ALL
DIMENSION AT SITE BEFORE COMMENCING
WORK.
4. THE CONTRACTOR IS RESPONSIBLE FOR
PROVIDING ALL NECESSARY TEMPORARY
SUPPORT TO THE BUILDING AND ANY ADJACENT
STRUCTURES.

REFERENCE:
0146-ETE-110CS-GF-DR-P-40502

REV. NO.	DESCRIPTION	DATE	BY
01	Add Grease Trap & update the plumbing plans	03/02/26	AA
02	Create leak detection, Gas & Fire protection etc plans	06/27/26	AA
03	Fix HVAC system and add new system	07/21/26	AA
04	Change VRF system & Fix Ventilation	07/27/26	AA
05	Provide more information about the HVAC system	08/04/26	AA
05	HVAC Elevation Plan & Filtrations Specification.	08/16/26	AA

PROJECT:
25 WILBURY AVENUE

TITLE:
**PROPOSED GAS SUPPLY
PLAN**

PROJ. NO.	PROJ. ENGR.	SCALE @ 24X36: 1:100
-----------	-------------	--------------------------------

DATE :
September 14, 2026

DRAWING NO. M - 4	REV. 6
-----------------------------	------------------



ENGINEER'S TEAM LTD
Web site: www.engrteam.com
Email: support@engrteam.com

CLIENT: MR AND MRS ANDERTON

ADDRESS: 25 WILBURY AVENUE,
HOVE, BN3 6HS

CONFIDENTIALITY STATEMENT:
ALL DRAWINGS AND WRITTEN MATERIALS
APPEARING HEREIN CONSTITUTE THE
ORIGINAL AND UNPUBLISHED WORK OF THE
DESIGNER AND THE SAME MAY NOT BE
DUPLICATED, USED OR DISCLOSED WITHOUT
CONSENT OF THE DESIGNER.

NOTES:
1. ALL DIMENSIONS HEREIN ARE IN IMPERIAL
UNITS UNLESS STATED OTHERWISE.
2. THESE DRAWINGS ARE TO BE READ IN
CONJUNCTION WITH ALL RELEVANT DESIGNER,
ENGINEER OR SPECIALIST DRAWINGS AND
SPECIFICATIONS.
3. THE CONTRACTOR MUST CHECK ALL
DIMENSION AT SITE BEFORE COMMENCING
WORK.
4. THE CONTRACTOR IS RESPONSIBLE FOR
PROVIDING ALL NECESSARY TEMPORARY
SUPPORT TO THE BUILDING AND ANY ADJACENT
STRUCTURES.

REFERENCE:
0146-ETE-110CS-GF-DR-P-40502

REV. NO.	DESCRIPTION	DATE	BY
01	Add Grease Trap & update the plumbing plans	03/02/26	AA
02	Create leak detection, Gas & Fire protection etc plans	06/27/26	AA
03	Fix HVAC system and add new system	07/21/26	AA
04	Change VRF system & Fix Ventilation	07/27/26	AA
05	Provide more information about the HVAC system	08/04/26	AA
05	HVAC Elevation Plan & Filtrations Specification.	08/16/26	AA


PROJECT: 25 WILBURY AVENUE

TITLE: **PLUMBING
INSTALLATION**


PROJ. NO. PROJ. ENGR. SCALE @ 24X36:
N/A

DATE : September 14, 2026

DRAWING NO. M - 5
REV. 6

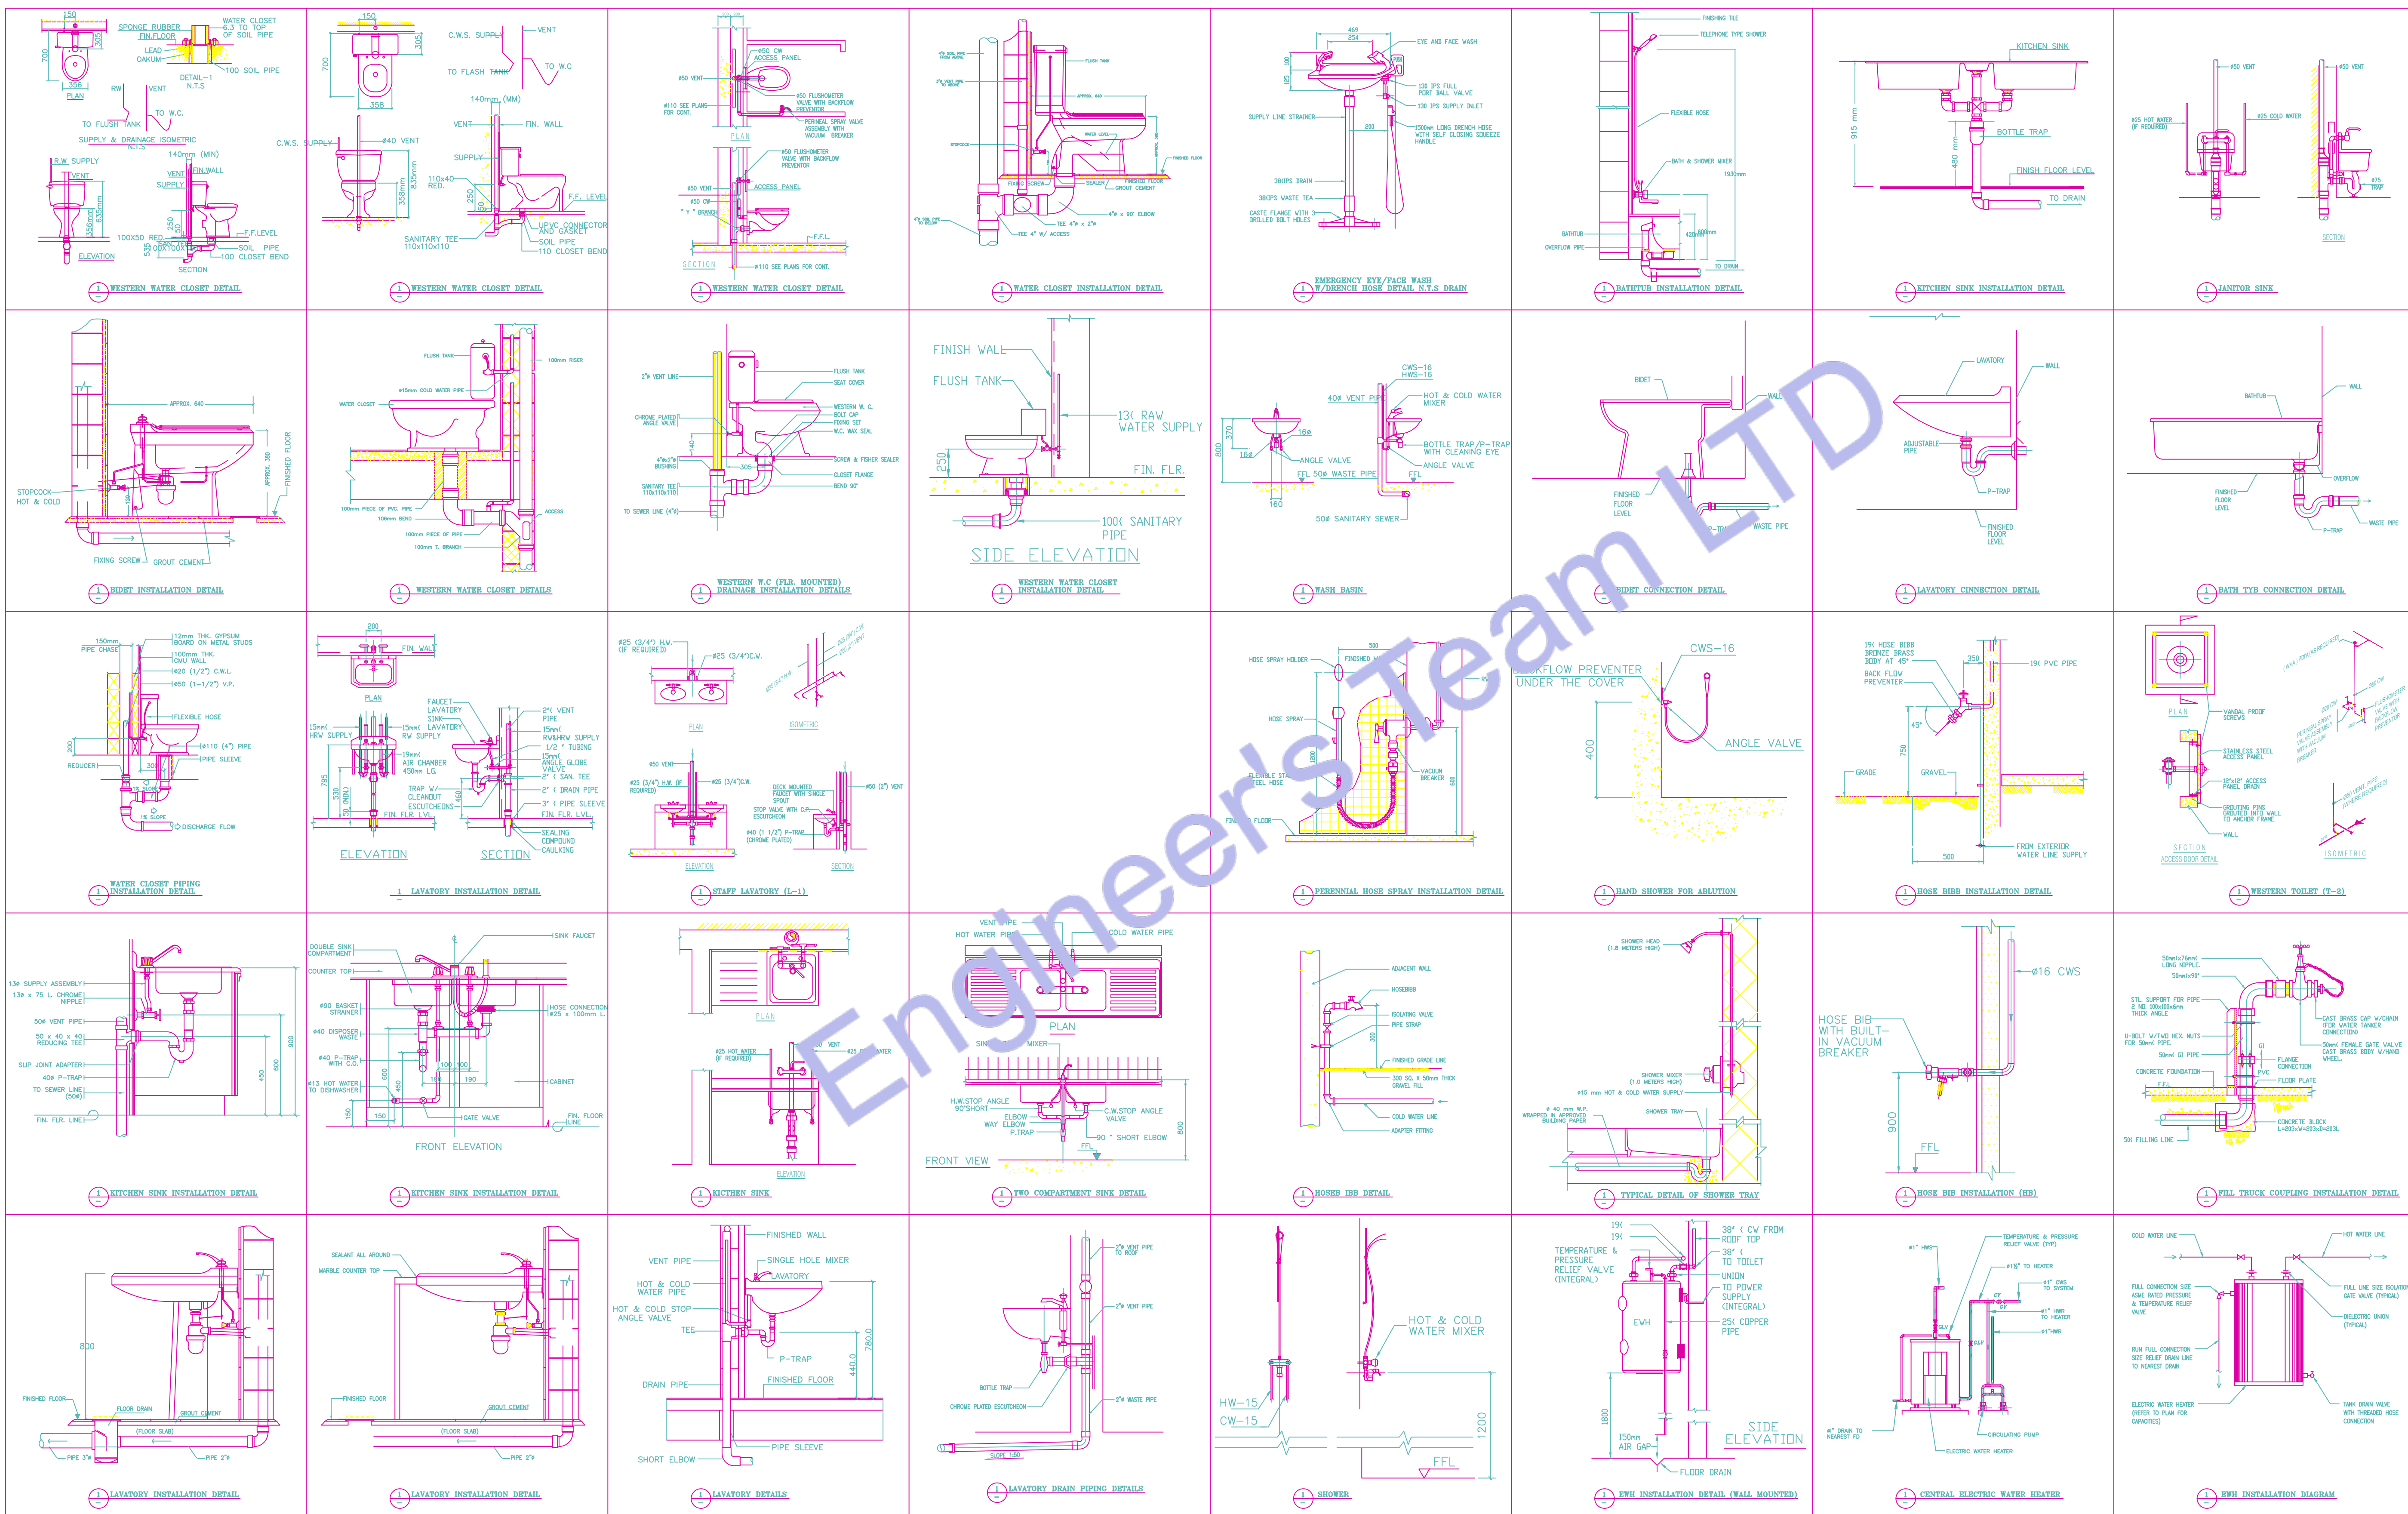

How it Works

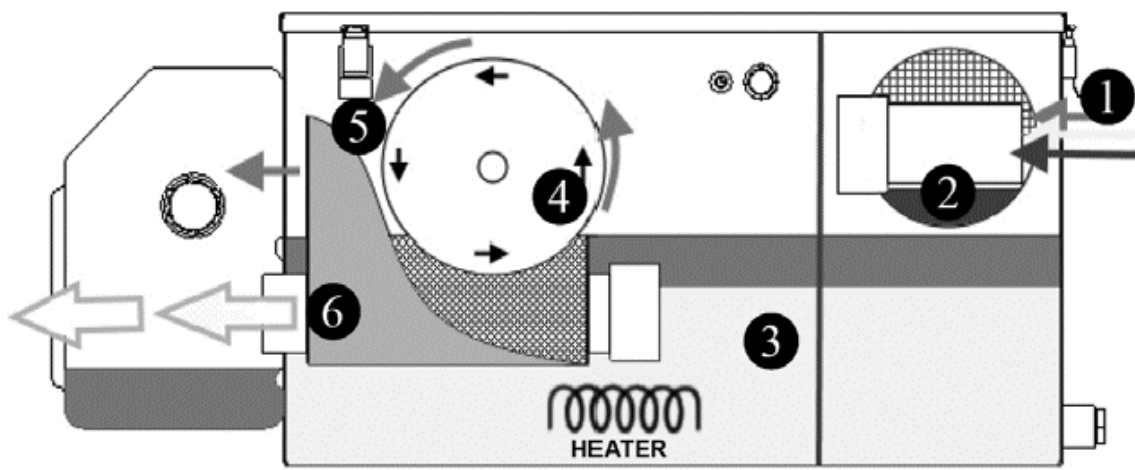

Rear view cutaway

- 1 Grease, solids and wastewater from the kitchen enters the Grease Guardian.
- 2 Solid food waste is caught in a removable cylindrical strainer.
- 3 A skimming cycle is set. The grease passes into the middle chamber through slots in the baffle wall where it remains trapped. With the assistance of a heater the grease rises to the surface forming a separated layer.
- 4 The liquefied grease adheres to the rotating skimming drum.
- 5 The grease passes down a scraper blade into a collection container where it can be removed and disposed hygienically.
- 6 The treated water exits under a baffle wall and through the outlet to drain.

PLUMBING And MECHANICAL INSTALLATION

lifting/Handling:


This product is classed as a heavy item that should not be handled alone. There is a requirement for 2 people to manually lift all models described in this manual. Steel tipped toe capped shoes and handling gloves should also be worn.



install these products models only at ambient room temperature, either under or adjacent to the fixtures being served. Do not repurpose the system or add to the number of fixtures specified for connection at time of sale.

Undersink example

ReAR view

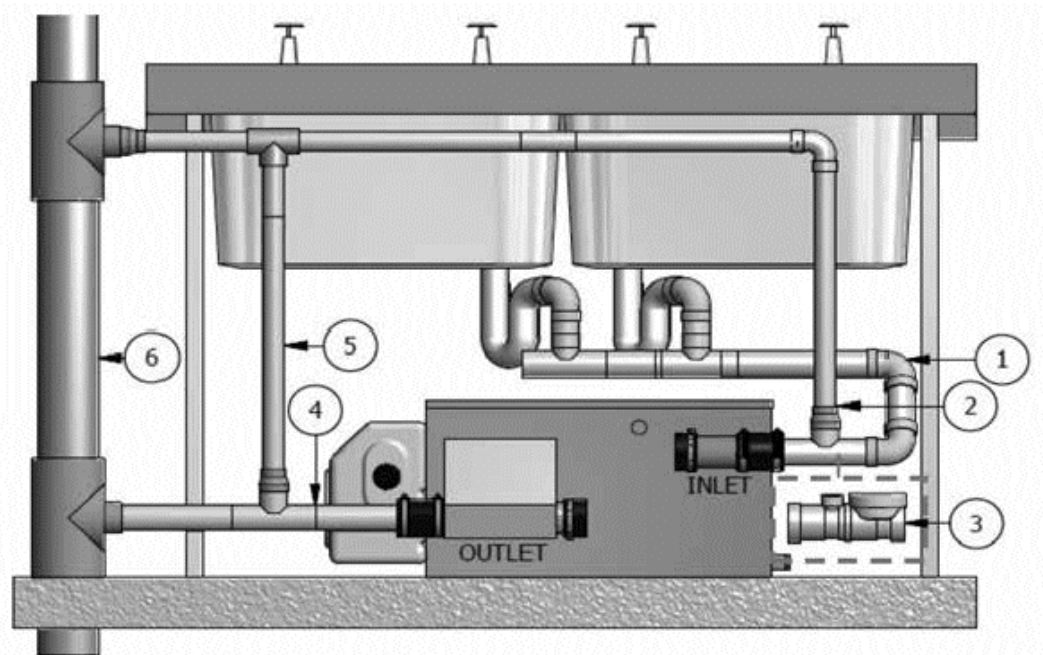


Check all required clearances in reference to the "Product Dimensions and Specification" page in this manual.


Product Dimensions & Specifications (230v AC)

Model	G & H are heights to pipe base (mm)							
	A	B	C	D	E	F	G	H
X7s	662	443	444	48	516	405	321	251
X7c	662	443	390	48	539	405	221	151
X15/15c	842	623	346	60	557	405	215	87
X25	870	657	423	60	570	405	298	170
X35	1092	873	422	89	577	405	281	170

front view

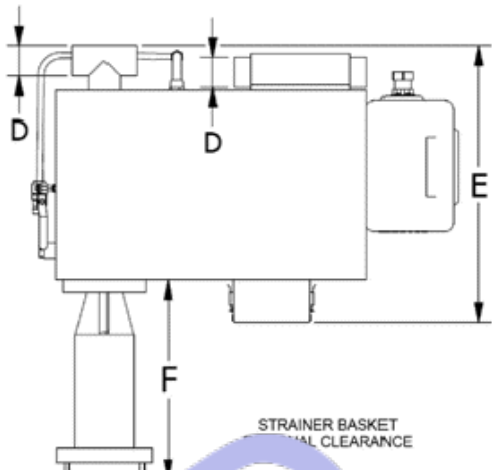

top view

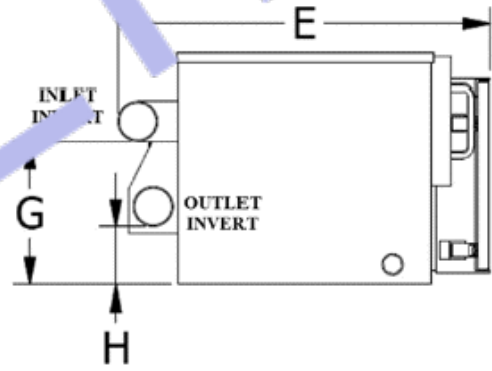

side view outlet end

Model	X15				
	X7s	X7c	X15c	X25	X35
Hydraulic Flow l/second	0.5	0.5	1	1.58	2.21
Skim Rate l/hr	5	5	5	5	5
Strainer Basket vol, kg	2.99	2.99	2.99	2.99	2.99
Grease Collector vol, litres	7	7	7	7	7

Motor (all units)	25 Watt, 230VAC, 50 Hz
Heater X7 - X15	600 Watt, 230VAC, Thermal cut-out inc.
Heater x25 - x35	1000 Watt, 230VAC, Thermal cut-out inc.
controller (all units)	Logic Controller: Backlit display Inputs 230VAC Outputs 230VAC Battery back up

plumbing sequence

- 1 Plumbing work. Install 2 inch (50mm) diameter wide pipes. Ensure a slight fall is provided in all pipe-work entering unit. The Grease Guardian includes quick connect rubber couplings and blanking caps. Note that the fixtures pipe can enter the Grease Guardian inlet from left or right. (above rear view shows from right) If multiple pipes are being plumbed from opposite directions, under normal plumbing codes these must all combine to enter via one pipe via one direction only and should not be plumbed from both directions.
- 2 Ventilation Tee and branch pipe. (Recommended) to prevent odours escaping from the Grease Guardian into kitchen area. Ventilation should be terminated at the building's stack vent. If ventilation is not provided at inlet, the pump/clean out frequency of the system may have to be increased to reduce potential waste odours.
- 3 UsA. flow control with Air intake. For those installations requiring Plumbing Drainage Institute of America compliance, a certified flow control (with air intake) must replace the inlet ventilation Tee. The relevant control required from www.canplas.com is listed:
 - GGX7, part reference: Canplas 3922107A
 - GGX15, part reference: Canplas 3922115A
 - GGX20, part reference: Canplas 3922120A
 - GGX25, part reference: Canplas 3922125A
 - GGX35, part reference: Canplas 3933135A(The air intake riser of the flow control is to be connected to the inlet side ventilation pipe as described in point (2))
- 4 Wastewater pipework. WARNING To avoid reduced flow or backflows issues, the site outlet pipework must be connected as detailed below for all GGX systems.
 - pipe diameter must be minimally of 2 inch diameter (50mm)
 - pipe must be installed at a gravity fall of 1:10 minimally, but preferably 1:40.
 - pipe must contain no more than 2 x 90 degree pipe bends between Grease Guardian outlet and final waste point in floor.
- 5 Outlet vent pipe. Required to:
 - a. prevent sewer back odours entering Grease Guardian
 - b. to prevent any siphonage of the system under peak flows. The pipework should be terminated at final stack vent.
- 6 Final vent stack to atmosphere. Failure to connect ventilation points of Grease Guardian to the final stack can result in odour issues internally.



ENGINEER'S TEAM LTD
Web site: www.engrteam.com
Email: support@engrteam.com

CLIENT: MR AND MRS ANDERTON

ADDRESS: 25 WILBURY AVENUE, HOVE, BN3 6HS

CONFIDENTIALITY STATEMENT:
ALL DRAWINGS AND WRITTEN MATERIALS APPEARING HEREIN CONSTITUTE THE ORIGINAL AND UNPUBLISHED WORK OF THE DESIGNER AND THE SAME MAY NOT BE DUPLICATED, USED OR DISCLOSED WITHOUT CONSENT OF THE DESIGNER.

NOTES:
1. ALL DIMENSIONS HEREIN ARE IN IMPERIAL UNITS UNLESS STATED OTHERWISE.
2. THESE DRAWINGS ARE TO BE READ IN CONJUNCTION WITH ALL RELEVANT DESIGNER, ENGINEER OR SPECIALIST DRAWINGS AND SPECIFICATIONS.
3. THE CONTRACTOR MUST CHECK ALL DIMENSION AT SITE BEFORE COMMENCING WORK.
4. THE CONTRACTOR IS RESPONSIBLE FOR PROVIDING ALL NECESSARY TEMPORARY SUPPORT TO THE BUILDING AND ANY ADJACENT STRUCTURES.

REFERENCE:

REV. NO.	DESCRIPTION	DATE	BY
01	Add Grease Trap & update the plumbing plans	03/02/26	AA
02	Create leak detection, Gas & Fire protection etc plans	06/27/26	AA
03	Fix HVAC system and add new system	07/21/26	AA
04	Change VRF system & Fix Ventilation	07/27/26	AA
05	Provide more information about the HVAC system	08/04/26	AA
05	HVAC Elevation Plan & Filtrations Specification.	08/16/26	AA

PROJECT: 25 WILBURY AVENUE

TITLE: GREASE TRAP INSTALLATION

PROJ. NO.	PROJ. ENGR.	SCALE @ 24X36:
		N/A

DATE : September 14, 2026

DRAWING NO.	REV.
M - 6	6

GENERAL SPECIFICATIONS
1. GENERAL (ALL SPECIFICATIONS ON THIS SHEET AS APPLICABLE) A. Work indicated on these drawings is diagrammatic and shall not be scaled. The drawings are intended to convey the scope of work and general arrangement of services. The Contractor shall verify all existing site conditions prior to installation and make all necessary adjustments to complete the works in accordance with the Contract Documents and UK statutory requirements. B. Provide all labour, materials, plant, tools, equipment, and services necessary for the complete execution of the works in accordance with the Contract Documents. All incidental or supplementary items required for a complete, safe, and operational installation shall be deemed included, whether or not specifically shown or described, at no additional cost to the Employer. C. All systems and equipment shall be fully installed, tested, commissioned, and left in a complete operational condition to the satisfaction of the Employer. The term "Provide" shall be interpreted as supply, install, test, and commission. D. All materials and equipment shall be new, of good quality, fit for purpose, and compatible with existing systems where interfaces occur. Installation shall be in accordance with manufacturers' instructions, relevant British Standards, CIBSE guidance, and recognised good engineering practice. E. Where existing services or building elements obstruct new works, the Contractor shall coordinate and rearrange such items as required, subject to approval by the Contract Administrator, and without additional cost. F. Written approval shall be obtained prior to cutting or forming penetrations through slabs, walls, ceilings, roofs, or fire compartments. All disturbed finishes shall be reinstated to match existing. All fire-resisting elements shall be reinstated to maintain required fire resistance in accordance with Approved Document B. G. Maintain the site in a clean and safe condition at all times in accordance with CDM Regulations 2015. Remove waste daily. Upon completion, clear the site of all tools, materials, and debris and leave areas clean and ready for occupation.
2. COORDINATION AND PROGRAMMING A. The Contractor shall fully coordinate all trades and verify existing conditions to prevent clashes in routing, access, or programme. B. The Contractor is responsible for coordination between subcontractors, suppliers, statutory authorities, utility providers, the Client, and the Design Team. C. No installation shall commence until all site dimensions, structural constraints, existing services, and retained fixtures have been verified. D. Works shall be programmed and phased to minimise disruption to occupied areas. A detailed programme shall be submitted for approval. Temporary partitions or protection shall be provided where required. E. Provide a minimum of fourteen (14) days' written notice prior to any planned shutdown of utilities. Written approval shall be obtained before shutdown. F. The Contractor shall be deemed to have inspected the site and fully understood all conditions affecting the works. No claims shall be entertained for failure to do so.
3. STATUTORY COMPLIANCE, PERMITS AND INSPECTIONS (UK) A. All works shall comply with the latest editions of applicable UK legislation and standards, including but not limited to: Building Regulations (England/Wales) Approved Documents A, B, F, G, L, M BS and EN Standards CIBSE Guides Health and Safety at Work Act 1974 CDM Regulations 2015 B. The Contractor shall obtain all required approvals, inspections, and completion certificates from Building Control and relevant Authorities Having Jurisdiction. C. All works shall comply with statutory utility provider requirements and local authority regulations. D. Where Contract Documents exceed statutory minimum requirements, the Contract Documents shall take precedence. Any conflict shall be reported in writing prior to installation. E. The Contractor shall comply with all UK health, safety, and environmental legislation, including COSHH and waste management regulations. F. All works shall comply with the requirements of relevant utility companies and network operators.
4. WARRANTY A. All workmanship and materials shall be warranted for a minimum period of twelve (12) months from the date of Practical Completion. Defects arising during this period shall be remedied at no cost to the Employer.
5. SHOP DRAWINGS A. Submit electronic shop drawings, manufacturers' data sheets, and performance information for all equipment for review and approval prior to installation.
6. RECORD DRAWINGS / AS-BUILT INFORMATION A. Maintain a complete set of marked-up drawings on site recording all changes. Upon completion, provide electronic and hard-copy as-built drawings and manuals in accordance with CIBSE TM31 / Soft Landings principles, if applicable.

DUCTWORK & INSULATION
SHEET METAL DUCTWORK A. All ductwork shall be galvanised steel fabricated and installed in accordance with DW/144 and BS EN 1507 / BS EN 12237. B. All ductwork routes shall be site-verified prior to fabrication. C. Duct leakage classes shall comply with DW/143. Testing shall be carried out where required. D. Turning vanes shall be installed in elbows as recommended by DW/144. E. Flexible duct connections shall be limited in length and installed in accordance with BS EN 13180. F. Exposed ductwork shall be single-skin galvanised steel with approved seams.
DUCT INSULATION & ACOUSTIC LINING Thermal Insulation Insulation thickness shall comply with Approved Document L and CIBSE Guide A. Insulation Materials Insulation shall achieve appropriate fire performance in accordance with BS EN 13501-1. Acoustic Lining Acoustic lining shall comply with BS EN ISO 11654 and be mould-resistant.

PIPING & INSULATION
REFRIGERANT & CONDENSATE PIPEWORK 1. Refrigerant pipework shall comply with BS EN 378 and manufacturer requirements. 1. Pipe identification shall comply with BS 1710. 3. Pipe routing shall not obstruct equipment servicing. 4. Condensate pipework shall be PVC-U or equivalent and installed to falls per Approved Document H. 5. Traps shall be provided where required. 6. Dissimilar metals shall be isolated to prevent corrosion.
PIPE INSULATION 1. Pipe insulation shall comply with Approved Document L. 2. External insulation shall be weather-protected. 3. Fire stopping shall comply with Approved Document B and BS 476 / BS EN 1366.

MECHANICAL CODE NOTES
1. No ductwork or pipework shall be installed above electrical switchgear, distribution boards, or control panels in accordance with BS 7671 and good engineering practice. 2. Materials within air plenums shall be non-combustible or achieve Class 0 or Class A2, s1, d0 protection to fire in accordance with Approved Document B and BS EN 13501-1. 3. Verify roof warranty status prior to works. All roof penetrations shall be carried out by approved contractors. 4. Ductwork and horizontal pipework shall be installed as high as practicable and coordinated to avoid clashes. 5. Provide adequate access for maintenance, filter placement, valves, and electrical isolation in accordance with CIBSE Guide M. 6. Structural approval shall be obtained for equipment loads exceeding manufacturer or structural limits. 7. Motorised dampers shall be provided on all outdoor air and exhaust air ducts where required by Approved Document F. 8. Provide balancing dampers on all main and branch ducts. 9. Fire dampers shall be installed where ductwork penetrates fire compartments in accordance with BS 9999 and BS EN 1366. 10. Provide access panels for fire, smoke, and control dampers. 11. Access panels shall be provided for all concealed valves and dampers. 12. Provide remote volume control where dampers are inaccessible. 13. External vents shall be corrosion-resistant and suitable for UK environmental conditions.

CONTROLS
1. Controls installation and commissioning shall be undertaken by competent specialists. 2. Thermostats shall be insulated from cold bridging on external walls. 3. Thermostats shall be installed at appropriate heights and coordinated with the Design Team. 4. Provide all required interfaces for full system control. 5. Demonstrate and commission all systems prior to handover in accordance with CIBSE Commissioning Codes.

TESTING & BALANCING
1. Scope Testing and balancing shall be carried out by competent commissioning specialists in accordance with CIBSE Commissioning Codes A, B, and M. 2. Pre-conditions All systems shall be complete, clean, and operational prior to commissioning. 3. Documentation Provide commissioning reports demonstrating compliance with design performance. 4. Recorded Data Record airflow rates, temperatures, capacities, and electrical data. 5. Functional Testing Demonstrate heating and cooling operation and record performance results.

ABBREVIATIONS			
(E)	EXISTING TO REMAIN	IN WG	INCHES OF WATER GAUGE
(R)	EXISTING TO BE REMOVED AND RELOCATED	KW	KILOWATTS
(RE)	RELOCATED EQUIPMENT	LAT	LEAVING AIR TEMPERATURE
ACU	AIR CONDITIONING UNIT	LBS	POUNDS
AFF	AS-FINISHED FLOOR	LRA	LOCKED ROTOR AMPS
AHJ	AIR HANDLING UNIT	LWT	LEAVING WATER TEMPERATURE
BAS	BUILDING AUTOMATION SYSTEM	MBH	THOUSAND BRITISH THERMAL UNITS PER HOUR
BTU/H	BRITISH THERMAL UNITS PER HOUR	MCA	MINIMUM CIRCUIT AMPACITY
CFM	CUBIC FEET PER MINUTE	MIN	MINIMUM
CG	CEILING	MOCP	MAX OVER-CURRENT PROTECTION
LA	LEAVING AIR	OA	OUTSIDE AIR
DN	DOWN	PD	PRESSURE DROP
EAT	ENTERING AIR TEMPERATURE	PH	PHASE
F	EXHAUST FAN	PSI	POUNDS PER SQUARE INCH
FF	EFFICIENCY	RA	RETURN AIR
ESP	EXTERNAL STATIC PRESSURE	RH	RELATIVE HUMIDITY
EWB	ENTERING WET BULB TEMPERATURE	RLA	RUNNING LOAD AMPS
EWT	ENTERING WATER TEMPERATURE	RPM	REVOLUTIONS PER MINUTE
°F	DEGREES FAHRENHEIT	SA	SUPPLY AIR
FLA	FULL LOAD AMPS	SL	SOUND LINING
FPB	FAN POWERED BOX	TYP	TYPICAL
FT	FOOT, FEET	TF	TRANSFER FAN
GPM	GALLONS PER MINUTE	V	VOLT, VOLTS
HP	HORSEPOWER	VAV	VARIABLE AIR VOLUME
HZ	HERTZ (CYCLES PER SECOND)	W/	WITH
IN	INCH, INCHES	WB	WET BULB TEMPERATURE
		WG	WATER GAUGE

HVAC SYMBOLS	
SYMBOL	DESCRIPTION
	EXISTING DUCTWORK, EQUIPMENT OR PIPING TO REMAIN
	EXISTING DUCTWORK, EQUIPMENT OR PIPING TO BE REMOVED OR RELOCATED
	NEW OR RELOCATED DUCTWORK, EQUIPMENT OR PIPING
	DUCTWORK WITH SOUNDLINING
	SUPPLY DUCT TURNING UP
	RETURN/EXHAUST DUCT TURNING UP
	SUPPLY DUCT TURNING DOWN
	RETURN/EXHAUST DUCT TURNING DOWN
	TRANSITION IN DUCT, SQUARE TO SQUARE
	TRANSITION IN DUCT, SQUARE TO ROUND
	SQUARE THROAT DUCT ELBOW WITHOUT TURNING VANES
	SQUARE THROAT DUCT ELBOW WITH TURNING VANES
	RADIUS ELBOW
	45 DEGREE TAP
	SPIN-IN RUNOUT FITTING WITH BALANCING DAMPER AND FLEXIBLE DUCT
	CONICAL TAP
	FLEXIBLE DUCT
	FLEXIBLE DUCT CONNECTION
	RECTANGULAR SUPPLY AIR DIFFUSER
	RETURN AIR GRILLE
	HUMIDISTAT, THERMOSTAT, CO2 SENSOR
	EXHAUST FAN
	SIDE WALL/DUCT REGISTER
	CFM DESIGNATION SYMBOL & QUANTITY
	KEYED NOTE, DEMOLITION
	KEYED NOTE, NEW WORK
	POINT OF REMOVAL
	POINT OF CONNECTION TO EXISTING
	DIFFUSER OR GRILLE DESIGNATION SYMBOL
	ACCESS DOOR, SIZE ON FLOOR PLANS
	RECTANGULAR SUPPLY AIR DIFFUSER
	VOLUME DAMPER
	FD: FIRE DAMPER SD: SMOKE DAMPER MD: MOTORIZED DAMPER F/SD: COMBINATION FIRE/SMOKE DAMPER BDD: BACKDRAFT DAMPER
	VAV TAG: TYPE, BOX NUMBER AIRFLOW AND KW
	VAV BOX TYPE V-SHUT-OFF TYPE VAV BOX S-SERIES FAN POWERED BOX P-PARALLEL FAN POWERED BOX



ENGINEER'S TEAM LTD
Web site: www.engrteam.com
Email: support@engrteam.com

CLIENT: MR AND MRS ANDERTON

ADDRESS: 25 WILBURY AVENUE, HOVE, BN3 6HS

CONFIDENTIALITY STATEMENT:
ALL DRAWINGS AND WRITTEN MATERIALS APPEARING HEREIN CONSTITUTE THE ORIGINAL AND UNPUBLISHED WORK OF THE DESIGNER AND THE SAME MAY NOT BE DUPLICATED, USED OR DISCLOSED WITHOUT CONSENT OF THE DESIGNER.

NOTES:
1. ALL DIMENSIONS HEREIN ARE IN IMPERIAL UNITS UNLESS STATED OTHERWISE.
2. THESE DRAWINGS ARE TO BE READ IN CONJUNCTION WITH ALL RELEVANT DESIGNER, ENGINEER OR SPECIALIST DRAWINGS AND SPECIFICATIONS.
3. THE CONTRACTOR MUST CHECK ALL DIMENSION AT SITE BEFORE COMMENCING WORK.
4. THE CONTRACTOR IS RESPONSIBLE FOR PROVIDING ALL NECESSARY TEMPORARY SUPPORT TO THE BUILDING AND ANY ADJACENT STRUCTURES.

REV. NO.	DESCRIPTION	DATE	BY
01	Add Grease Trap & update the plumbing plans	03/02/26	AA
02	Create leak detection, Gas & Fire protection etc plans	06/27/26	AA
03	Fix HVAC system and add new system	07/21/26	AA
04	Change VRF system & Fix Ventilation	07/27/26	AA
05	Provide more information about the HVAC system	08/04/26	AA
05	HVAC Elevation Plan & Filtrations Specification.	08/16/26	AA

PROJECT: 25 WILBURY AVENUE

TITLE: **GENERAL NOTE FOR HVAC PLAN**

PROJ. NO.	PROJ. ENGR.	SCALE @ 24X36: 1:100
-----------	-------------	----------------------

DATE : September 14, 2026

DRAWING NO. M - 1 0	REV. 6
---------------------	--------



ENGINEER'S TEAM LTD

Web site: www.engrteam.com
Email: support@engrteam.com

CLIENT: MR AND MRS ANDERTON

ADDRESS: 25 WILBURY AVENUE,
HOVE, BN3 6HS

CONFIDENTIALITY STATEMENT:

ALL DRAWINGS AND WRITTEN MATERIALS

APPEARING HEREIN CONSTITUTE THE ORIGINAL AND UNPUBLISHED WORK OF THE DESIGNER AND THE SAME MAY NOT BE DUPLICATED, USED OR DISCLOSED WITHOUT CONSENT OF THE DESIGNER.

NOTES:

1. ALL DIMENSIONS HEREIN ARE IN IMPERIAL UNITS UNLESS STATED OTHERWISE.
2. THESE DRAWINGS ARE TO BE READ IN CONJUNCTION WITH ALL RELEVANT DESIGNER, ENGINEER OR SPECIALIST DRAWINGS AND SPECIFICATIONS.
3. THE CONTRACTOR MUST CHECK ALL DIMENSION AT SITE BEFORE COMMENCING WORK.
4. THE CONTRACTOR IS RESPONSIBLE FOR PROVIDING ALL NECESSARY TEMPORARY SUPPORT TO THE BUILDING AND ANY ADJACENT STRUCTURES.

REV. NO.	DESCRIPTION	DATE	BY
01	Add Grease Trap & update the plumbing plans	03/02/26	AA
02	Create leak detection, Gas & Fire protection etc plans	06/27/26	AA
03	Fix HVAC system and add new system	07/21/26	AA
04	Change VRF system & Fix Ventilation	07/27/26	AA
05	Provide more information about the HVAC system	08/04/26	AA
05	HVAC Elevation Plan & Filtrations Specification.	08/16/26	AA

PROJECT: 25 WILBURY AVENUE

TITLE: PROPOSED HVAC LAYOUT PLAN

PROJ. NO. PROJ. ENGR. SCALE @ 24X36: 1:100

DATE : September 14, 2026

DRAWING NO. REV.

M - 11

6

NOTE:

Scope & Compliance
This HVAC Layout Plan has been prepared for the property at 110 Cannon Street, London, EC4N 6EU, United Kingdom. All heating, ventilation, air-conditioning, ductwork, plant, controls, and associated mechanical systems shown on this plan are designed to comply with the applicable and currently adopted national and local building regulations, standards, guidance, performance requirements, and product approval criteria enforced by the UK Government (England) and relevant Authorities Having Jurisdiction.

Applicable Building Regulations & Approved Documents
The HVAC design has been developed in accordance with the Building Regulations 2010 (as amended) and relevant Approved Documents which form the statutory code for building design and construction in England. The principal regulatory provisions applicable to HVAC systems include:
a. Approved Document Part F – Ventilation (requirements for ventilation, indoor air quality, and mechanical systems including mechanical ventilation with heat recovery)
b. Approved Document Part L – Conservation of Fuel and Power (requirements for energy efficiency of fixed building services including heating and cooling plant, controls, and system efficiency, and alignment with national energy performance policy).
c. Building Regulations 2010 and subsequent amendments governing the design and installation of mechanical services to ensure safety, health, environmental quality and compliance.
d. Relevant statutory requirements under the Building Safety Act 2022 and associated regulatory framework for design, construction, commissioning, and handover processes where applicable.

Industry Standards, Guidance & Best Practice
To support compliance with the regulatory framework and best design practice, the following professional standards, codes of practice, design guides and commissioning procedures have been referenced:
a. CIBSE (Chartered Institution of Building Services Engineers) Guides – including guidance on ventilation, thermal comfort, energy use and indoor air quality as applicable to HVAC in commercial buildings.
b. CIBSE Commissioning Codes – for air distribution, controls, system commissioning, and balancing of HVAC systems.
c. British Standards (BS EN / BS) as applicable to HVAC products and system performance, duct testing, airflow measurement (e.g., BS EN 12599, BS EN 16211), smoke control, acoustics and other HVAC-related elements.
d. Recognised industry guidance for selection of plant, ductwork, controls, airflow, balancing, control strategies and integration with building systems in the UK context.

Mandatory Design Requirements
a. Ventilation systems (natural, mechanical extract, mechanical supply & extract, or mechanical ventilation with heat recovery) have been sized and configured to meet minimum fresh air supply rates, extraction rates and ventilation performance prescribed in Approved Document Part F.
b. Energy performance of heating and cooling services, controls and associated plant has been designed in accordance with the principles and minimum standards of Approved Document Part L.
c. All system design, sizing, control sequences and integration with building services consider occupant comfort, air quality, thermal performance, acoustic criteria, maintainability, and compatibility with other building systems and architectural constraints.

Product & Equipment Approval – 110 Cannon Street, London, EC4N 6EU, United Kingdom Product Approval Codes
a. All HVAC equipment and components including but not limited to air handling units, fans, chillers, heat pumps, boilers, terminal devices, heat recovery units, dampers, controls, sensors, filters and accessories must be certified, tested and listed for use in the United Kingdom.
b. Products shall carry appropriate conformity markings such as UKCA, CE (where applicable), or recognised third-party certification demonstrating compliance with product performance, safety and environmental standards.
c. Manufacturer documentation including performance data, installation instructions, control sequences, service clearances and maintenance requirements must be submitted to the design professional and the Authority Having Jurisdiction as part of product approval and plan checking.
d. Any proposed alternate or non-standard product shall be submitted in writing and must be approved by the design professional and the AHJ prior to procurement and installation.
e. Products not meeting current UK regulatory or certification requirements shall not be installed.

Permitting, Inspection & Certification
a. Prior to commencing installation, the appropriate building control approval and permits must be obtained from the relevant local authority in London.
b. All stages of HVAC installation including ductwork, plant setup, controls, system integration, testing and commissioning shall be inspected, verified and certified as required by the Building Regulations framework and local inspection protocols.
c. System commissioning reports, balancing documentation and evidence of compliance with Part F and Part L provisions shall be provided to Building Control for final acceptance.

Installation & Coordination Requirements
a. HVAC components and systems must be installed in accordance with the design documents, manufacturer instructions, relevant standards and health & safety requirements.
b. Coordination with other services (electrical, fire protection, plumbing, structural) shall be undertaken to ensure proper clearances, penetration protection, isolation, access for maintenance, vibration isolation and interface with building control systems.
c. Penetrations through fire-rated elements and other protective barriers shall be sealed and reinstated in compliance with fire safety requirements.

Testing, Commissioning & Documentation
a. All HVAC systems shall be tested, adjusted and balanced (TAB) by qualified personnel and shall deliver the required airflow, heating/cooling capacity and control performance documented on plan.
b. Commissioning shall include verification of control sequences, ventilation effectiveness, airflow measurements at terminals, pressure relationships, noise levels, energy performance and safety interlocks.
c. As-built drawings, test certificates, commissioning reports, operation & maintenance manuals and warranty documentation shall be provided to the owner and made available to the AHJ as part of project completion documentation.

Deviations & Field Changes
Any deviation from this approved layout plan or from applicable codes, standards or product approvals shall be documented and submitted as a formal revision or field change request for review and written approval by the design professional and the AHJ prior to implementation.

Contractor Responsibility & Limitation of Design Liability
This plan and note serve as a design document for permitting and construction coordination. The contractor is responsible for verifying field conditions, means & methods of installation, compliance with design and regulatory requirements, and for safe execution of all work. The design professional's responsibility is limited to the design scope; final installation must meet all regulatory and statutory requirements as enforced at the time of construction.

HVAC NOTE:

PROJECT: HADO RESTAURANT
SITE ADDRESS: 110 Cannon Street, London EC4N 6EU, United Kingdom

- GENERAL COMPLIANCE**
 - All HVAC works shall comply with the Building Regulations 2010 (as amended), including but not limited to Approved Document Part F (Ventilation), Approved Document Part L (Conservation of Fuel and Power), and all other applicable statutory requirements.
 - All works shall be carried out in accordance with the latest editions of relevant CIBSE Guides, CIBSE Commissioning Codes, British Standards, manufacturer's recommendations and recognised industry best practice.
 - All equipment shall be UKCA and/or CE marked where applicable and approved for installation within the United Kingdom.
 - Contractor shall verify all site dimensions, existing services and installation constraints prior to commencement of works.
- VENTILATION SYSTEM REQUIREMENTS**
 - Mechanical ventilation systems shall be designed, installed, tested and commissioned to achieve the ventilation rates required by Approved Document Part F and applicable CIBSE guidance.
 - Supply and extract air systems shall be provided as separate ductwork systems. Shared ductwork serving both supply and extract functions shall not be permitted.
 - Main ductwork runs shall be rigid spiral galvanneal steel ductwork. Flexible ductwork shall be limited to final connections between rigid ductwork and terminal devices.
 - Flexible ductwork may be utilised within restricted ceiling voids beneath the mezzanine structure where rigid ductwork installation is not practical due to headroom limitations.
 - All ductwork shall be adequately supported, sealed and insulated in accordance with current standards and manufacturer's recommendations.

- TOILET AND ANCILLARY AREA EXTRACT**
 - Toilet extract systems shall be independent of any office, storage, staff or ancillary area ventilation systems.
 - Toilet extract ductwork shall discharge independently and shall not be interconnected with general room ventilation systems unless specifically indicated on the approved design drawings.
 - Any new wall penetrations required for separation of extract systems shall be coordinated with the architect and structural engineer prior to installation.

- RESTAURANT GENERAL VENTILATION**
 - Existing ventilation equipment serving the restaurant shall be upgraded or replaced as required to achieve the design ventilation rates and improve odour control performance.
 - Additional extract terminals and/or diffusers shall be installed where required to achieve uniform extraction coverage throughout the restaurant floor area.
 - Ventilation distribution shall be balanced to eliminate stagnant air zones and improve air movement within customer seating areas.
 - Final air quantities shall be verified through testing, adjusting and balancing (TAB) procedures.

- KITCHEN EXTRACT SYSTEM**
 - Existing kitchen canopy and Ansul fire suppression system shall be retained unless otherwise noted.
 - Existing kitchen extract fan and associated extract ductwork shall be replaced with a new system sized in accordance with the final kitchen extract calculations.
 - Kitchen extract systems shall be designed to minimise cooking odours and prevent migration of contaminants into adjacent tenant spaces.
 - Kitchen extract ductwork shall be installed and protected in accordance with applicable fire and ventilation regulations.

- AIR CONDITIONING SYSTEM**
 - New air conditioning equipment shall be installed in accordance with approved equipment schedules and manufacturer's requirements.
 - Proposed Mitsubishi Electric PUMY-P200YKM4TH outdoor unit and associated indoor cassette units shall be installed subject to final load calculations and equipment selection verification.
 - Refrigerant pipework, condensate drainage and controls shall be installed in accordance with manufacturer's recommendations and applicable regulations.

- FIRE AND COMPARTMENTATION REQUIREMENTS**
 - All penetrations through fire-rated walls, floors and compartment boundaries shall be fire-stopped using approved fire-rated systems maintaining the required fire resistance rating.
 - Fire collars, fire dampers, fire-rated sealants and associated fire stopping products shall be installed where required by regulation and approved details.
 - All openings, service penetrations and voids identified during construction shall be sealed to maintain fire, smoke and acoustic compartmentation.

- TESTING, COMMISSIONING AND DOCUMENTATION**
 - All HVAC systems shall be tested, adjusted and balanced by competent personnel prior to handover.
 - Commissioning shall include airflow measurements, balancing reports, equipment performance verification, controls testing and operational demonstration.
 - Copies of commissioning certificates, balancing reports, operation and maintenance manuals, equipment data sheets and warranties shall be provided upon completion.

- CONTRACTOR RESPONSIBILITY**
 - Contractor shall verify all existing site conditions prior to fabrication and installation.
 - Any discrepancies between site conditions and construction documents shall be reported to the design consultant before proceeding with installation.
 - No deviations from the approved design shall be made without written approval from the design consultant and relevant authorities having jurisdiction.

FIRE SAFETY & HVAC COORDINATION NOTES

All fire-rated ductwork shall be designed, constructed, tested, and installed in accordance with the requirements of BESA DW144, BESA DW172 (where applicable for kitchen extract systems), BS EN 1366, BS 9999, and the relevant provisions of the Building Regulations (Approved Document B).
Where ductwork penetrates fire-resisting walls, floors, ceilings, or compartment lines, the fire resistance of the building element shall be fully maintained by the installation of approved fire-rated duct systems, fire dampers (where permitted), or tested penetration sealing systems as appropriate.

All service penetrations, including ductwork, pipework, cable trays, conduits, and associated supports passing through fire-rated construction, shall be sealed using approved fire-stopping systems, including fire collars, fire batts, intumescent sealants, or other tested products, to provide a fire resistance rating not less than that of the penetrated element.
Kitchen extract ductwork serving grease-producing cooking appliances shall be installed as an independent fire-rated grease extract system in accordance with BESA DW172, with continuous welded construction, suitable access panels for inspection and cleaning, and fire protection measures where required.


The kitchen hood fire suppression system (Ansul or approved equivalent) shall be fully coordinated with the kitchen extract system. Operation of the fire suppression system shall automatically isolate the kitchen gas supply (where applicable), stop the kitchen supply air system, and operate the extract system in accordance with the fire strategy and manufacturer's recommendations.

The mechanical ventilation and air conditioning systems shall be interfaced with the building fire alarm system. Upon activation of the fire alarm, HVAC equipment shall operate in accordance with the approved fire strategy, including shutdown of non-essential ventilation systems, operation of smoke control systems where applicable, closure of fire dampers (if installed), and shutdown of the AV system where required by the Employer's Requirements.
Fire dampers, smoke dampers, motorised fire dampers, and associated controls shall be installed, commissioned, labelled, and tested in accordance with the manufacturer's instructions, BS 9999, and all applicable British Standards.

All fire safety systems, interlocks, control sequences, and fire-stopping installations shall be tested, commissioned, and certified before practical completion. Relevant test certificates, commissioning records, and product approvals shall be submitted to the Contract Administrator, Building Control, and the Authority Having Jurisdiction as part of the project handover documentation.

General
The HVAC system is designed as a single-zone constant air volume (SCAV) split-AHU system, fully coordinated with the architectural layout and intended occupancy. All equipment capacities, airflow rates, and system arrangements are subject to detailed coordination and final manufacturer selection at construction stage.

HVAC Attenuator Schedule									
Tag	System / Application	Proposed Brand	Proposed Model	Size / Diameter (mm)	Design Airflow Rate (m³/s)	Target Noise Criteria (NC)	Sound Power Level (dB)	Sound Criteria & Review Remarks / Design Duty	
SD-SA	Supply Air Duct (Fresh Air Intake)	Lindab	SLBU 100	250	2	NC 35	18	Main MVHR fan noise down to NC 35 in dining zones. Max pressure drop across the duct must not exceed 25 Pa to maintain MVHR fan efficiency.	
SD-KE	Kitchen Extract Ductwork (Grease Exhaust)	Lindab	SLXU 100	315	1.667	NR 45 / NR 50	18	Heavy Grease Extract (DW172 Compliant): Handles high-velocity flow of 1,667 L/s (6,000 m³/h) from KEF-1. Acoustic media must be completely encapsulated in unperforated Mylar film to prevent grease saturation. Max face velocity must stay below 9 m/s to prevent regenerated whisking.	
SD-DI	General / Return Exhaust (Main Dining Room)	Lindab	SLU 100	315	1	NC 35	18	Dining Extract Branches: Balanced for branch flows up to 153 L/s (e.g., Noodle Bar dining lines). Casting must provide a minimum insertion loss of 12 dB at the critical 250 Hz octave band to cancel ambient background rumble.	
SD-TE	Toilet Extract Duct (Humid Exhaust)	Lindab	DACKA 100	100	0.078	NR 40	18	Humid Utility Extract: Sized for the 78 L/s EF-1 utility fan. Selection requires fiber-free Acoustic polyester media. Standard mineral wool is prohibited here due to continuous high-humidity extract and moisture degradation risks.	

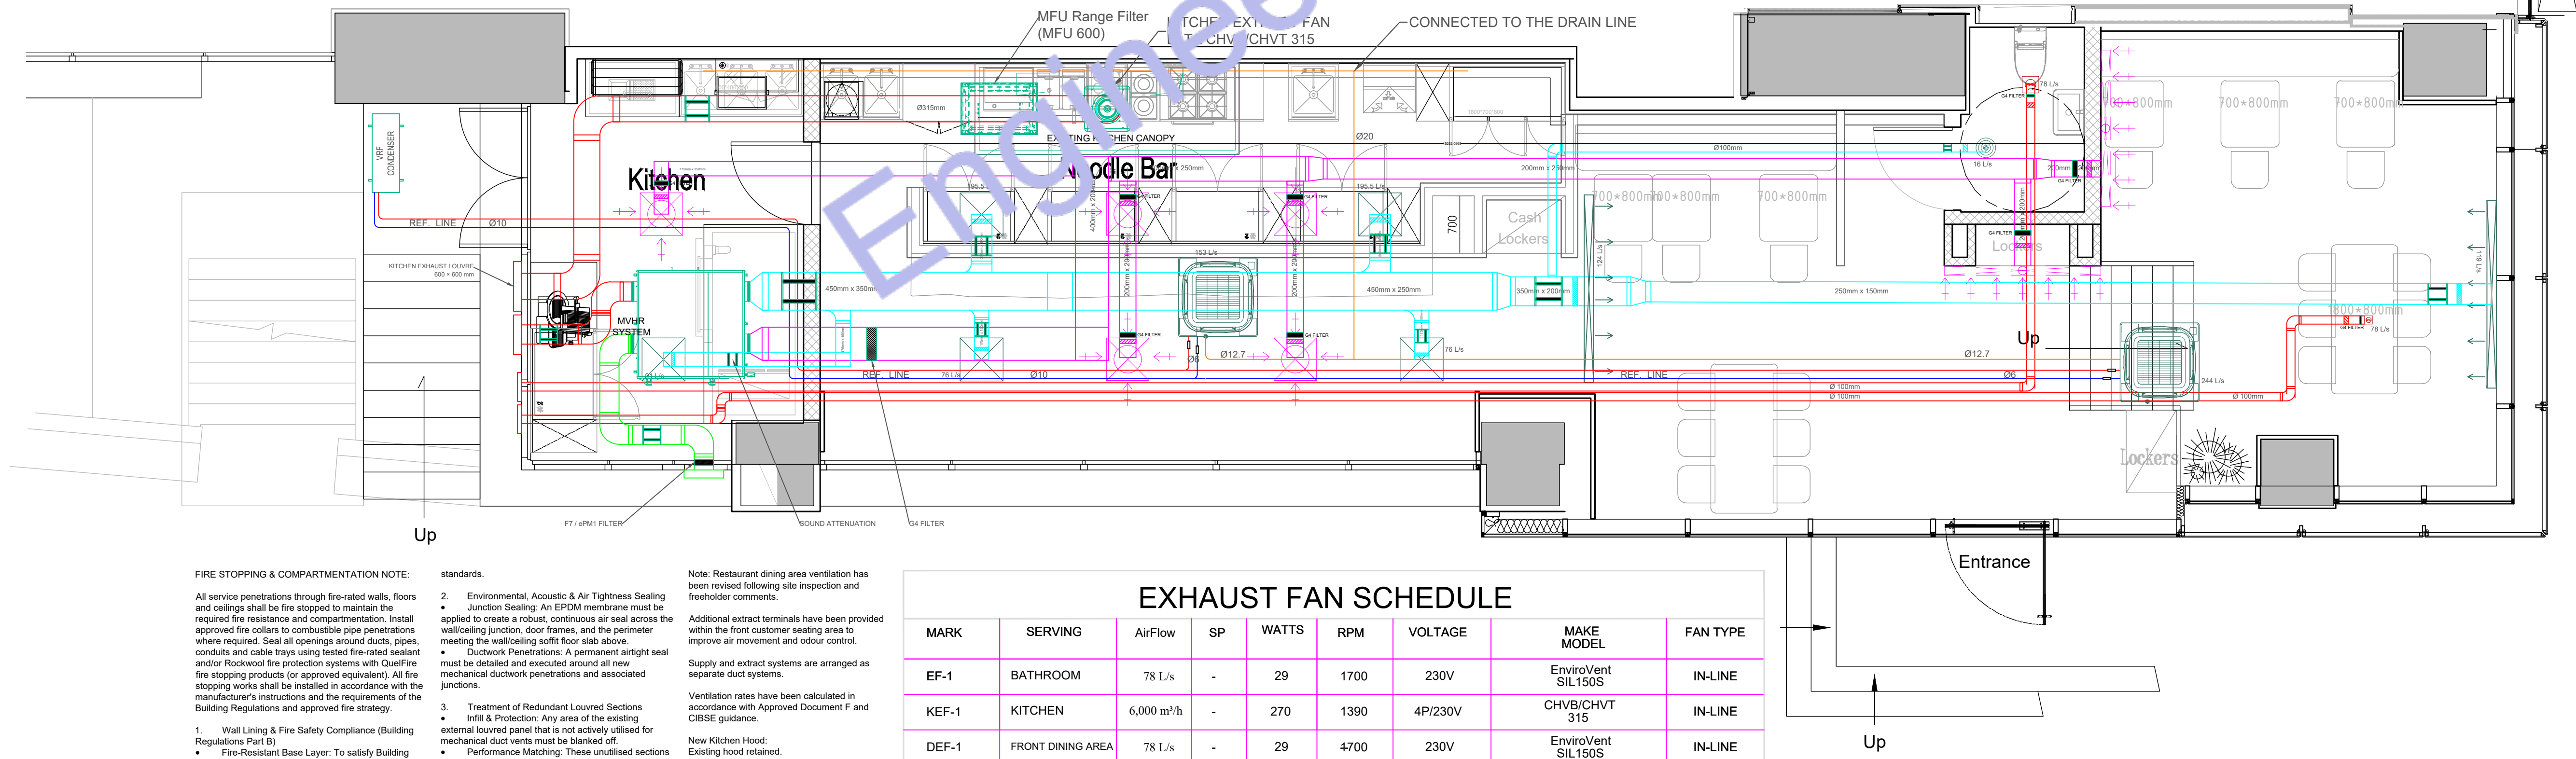

FIRE STOPPING & COMPARTMENTATION NOTE:

- All service penetrations through fire-rated walls, floors and ceilings shall be fire stopped to maintain the required fire resistance and compartmentation. Install approved fire collars to combustible pipe penetrations where required. Seal all openings around ducts, pipes, conduits and cable trays using tested fire-rated sealant and/or Rockwool fire protection systems with Quelfire fire stopping products (or approved equivalent). All fire stopping works shall be installed in accordance with the manufacturer's instructions and the requirements of the Building Regulations and approved fire strategy.
1. Wall Lining & Fire Safety Compliance (Building Regulations Part B)
 - Fire-Resistant Base Layer: To satisfy Building Regulations Part B (Fire Safety), the internal face of the rear louvred wall must incorporate an approved fire-rated lining. An A1-rated Cement Particle Board must be affixed as the primary (first) layer of the internal wall lining setup.
 - Thermal Performance: The entire internal wall lining configuration must be designed and installed to fully comply with current statutory thermal performance standards.
 2. Environmental, Acoustic & Air Tightness Sealing
 - Junction Sealing: An EPDM membrane must be applied to create a robust, continuous air seal across the wall/ceiling junction, door frames, and the perimeter meeting the wall/ceiling soffit floor slab above.
 - Ductwork Penetrations: A permanent airtight seal must be detailed and executed around all new mechanical ductwork penetrations and associated junctions.
 3. Treatment of Redundant Louvred Sections
 - Blanking & Protection: Any area of the existing external louvred panel that is not actively utilised for mechanical duct vents must be blanked off.
 - Performance Matching: These utilised sections must be appropriately sealed, fire-protected, and insulated to meet the same structural fire and thermal performance levels as the surrounding upgraded wall asset.

Note: Restaurant dining area ventilation has been revised following site inspection and fire/hood comments.

Additional extract terminals have been provided within the front customer seating area to improve air movement and odour control.

Supply and extract systems are arranged as separate duct systems.

Ventilation rates have been calculated in accordance with Approved Document F and CIBSE guidance.

New Kitchen Hood: Fan and extract duct upgraded.

Dining Area: Additional extract diffusers provided. AHU upgraded.

Ductwork: Spiral rigid ductwork for accessible long runs. Flexible duct limited to final connections only.

EXHAUST FAN SCHEDULE

MARK	SERVING	AirFlow	SP	WATTS	RPM	VOLTAGE	MAKE MODEL	FAN TYPE
EF-1	BATHROOM	78 L/s	-	29	1700	230V	EnviroVent SIL150S	IN-LINE
KEF-1	KITCHEN	6,000 m³/h	-	270	1390	4P/230V	CHVB/CHVT 315	IN-LINE
DEF-1	FRONT DINING AREA	78 L/s	-	29	4700	230V	EnviroVent SIL150S	IN-LINE

- NOTES
1. COMPLETE W/BACKDRAFT DAMPER.
 2. PROVIDE THERMOSTATIC CONTROL DEVICES

3. INTERLOCK TO OPERATE WHENEVER RTU'S OPERATE.
4. MAINTAIN A MINIMUM CLEARANCE OF 10'-0" FROM ALL INTAKE AIR FANS AND ALL ROOF TOP UNITS OUTSIDE AIR INTAKE OPENINGS.



ENGINEER'S TEAM LTD
Web site: www.egrteam.com
Email: support@egrteam.com

CLIENT: MR AND MRS ANDERTON

ADDRESS:
25 WILBURY AVENUE,
HOVE, BN3 6HS

CONFIDENTIALITY STATEMENT:
ALL DRAWINGS AND WRITTEN MATERIALS
APPEARING HEREIN CONSTITUTE THE
ORIGINAL AND UNPUBLISHED WORK OF THE
DESIGNER AND THE SAME MAY NOT BE
DUPLICATED, USED OR DISCLOSED WITHOUT
CONSENT OF THE DESIGNER.

NOTES:
1. ALL DIMENSIONS HEREIN ARE IN IMPERIAL
UNITS UNLESS STATED OTHERWISE.
2. THESE DRAWINGS ARE TO BE READ IN
CONJUNCTION WITH ALL RELEVANT DESIGNER,
ENGINEER OR SPECIALIST DRAWINGS AND
SPECIFICATIONS.
3. THE CONTRACTOR MUST CHECK ALL
DIMENSION AT SITE BEFORE COMMENCING
WORK.
4. THE CONTRACTOR IS RESPONSIBLE FOR
PROVIDING ALL NECESSARY TEMPORARY
SUPPORT TO THE BUILDING AND ANY ADJACENT
STRUCTURES.

REFERENCE:
HAN-GOYA-00-XX-CO-5601

REV. NO.	DESCRIPTION	DATE	BY
01	Add Grease Trap & update the plumbing plans	03/02/26	AA
02	Create leak detection, Gas & Fire protection etc plans	06/27/26	AA
03	Fix HVAC system and add new system	07/21/26	AA
04	Change VRF system & Fix Ventilation	07/27/26	AA
05	Provide more information about the HVAC system	08/04/26	AA
05	HVAC Elevation Plan & Filtrations Specification.	08/16/26	AA


PROJECT:
25 WILBURY AVENUE

TITLE:
**R-102 Restaurant
Fire Suppression Systems**

PROJ. NO.	PROJ. ENGR.	SCALE @ 24X36: 1:100
-----------	-------------	--------------------------------

DATE :
September 14, 2026

DRAWING NO. M - 1 2	REV. 6
-------------------------------	------------------

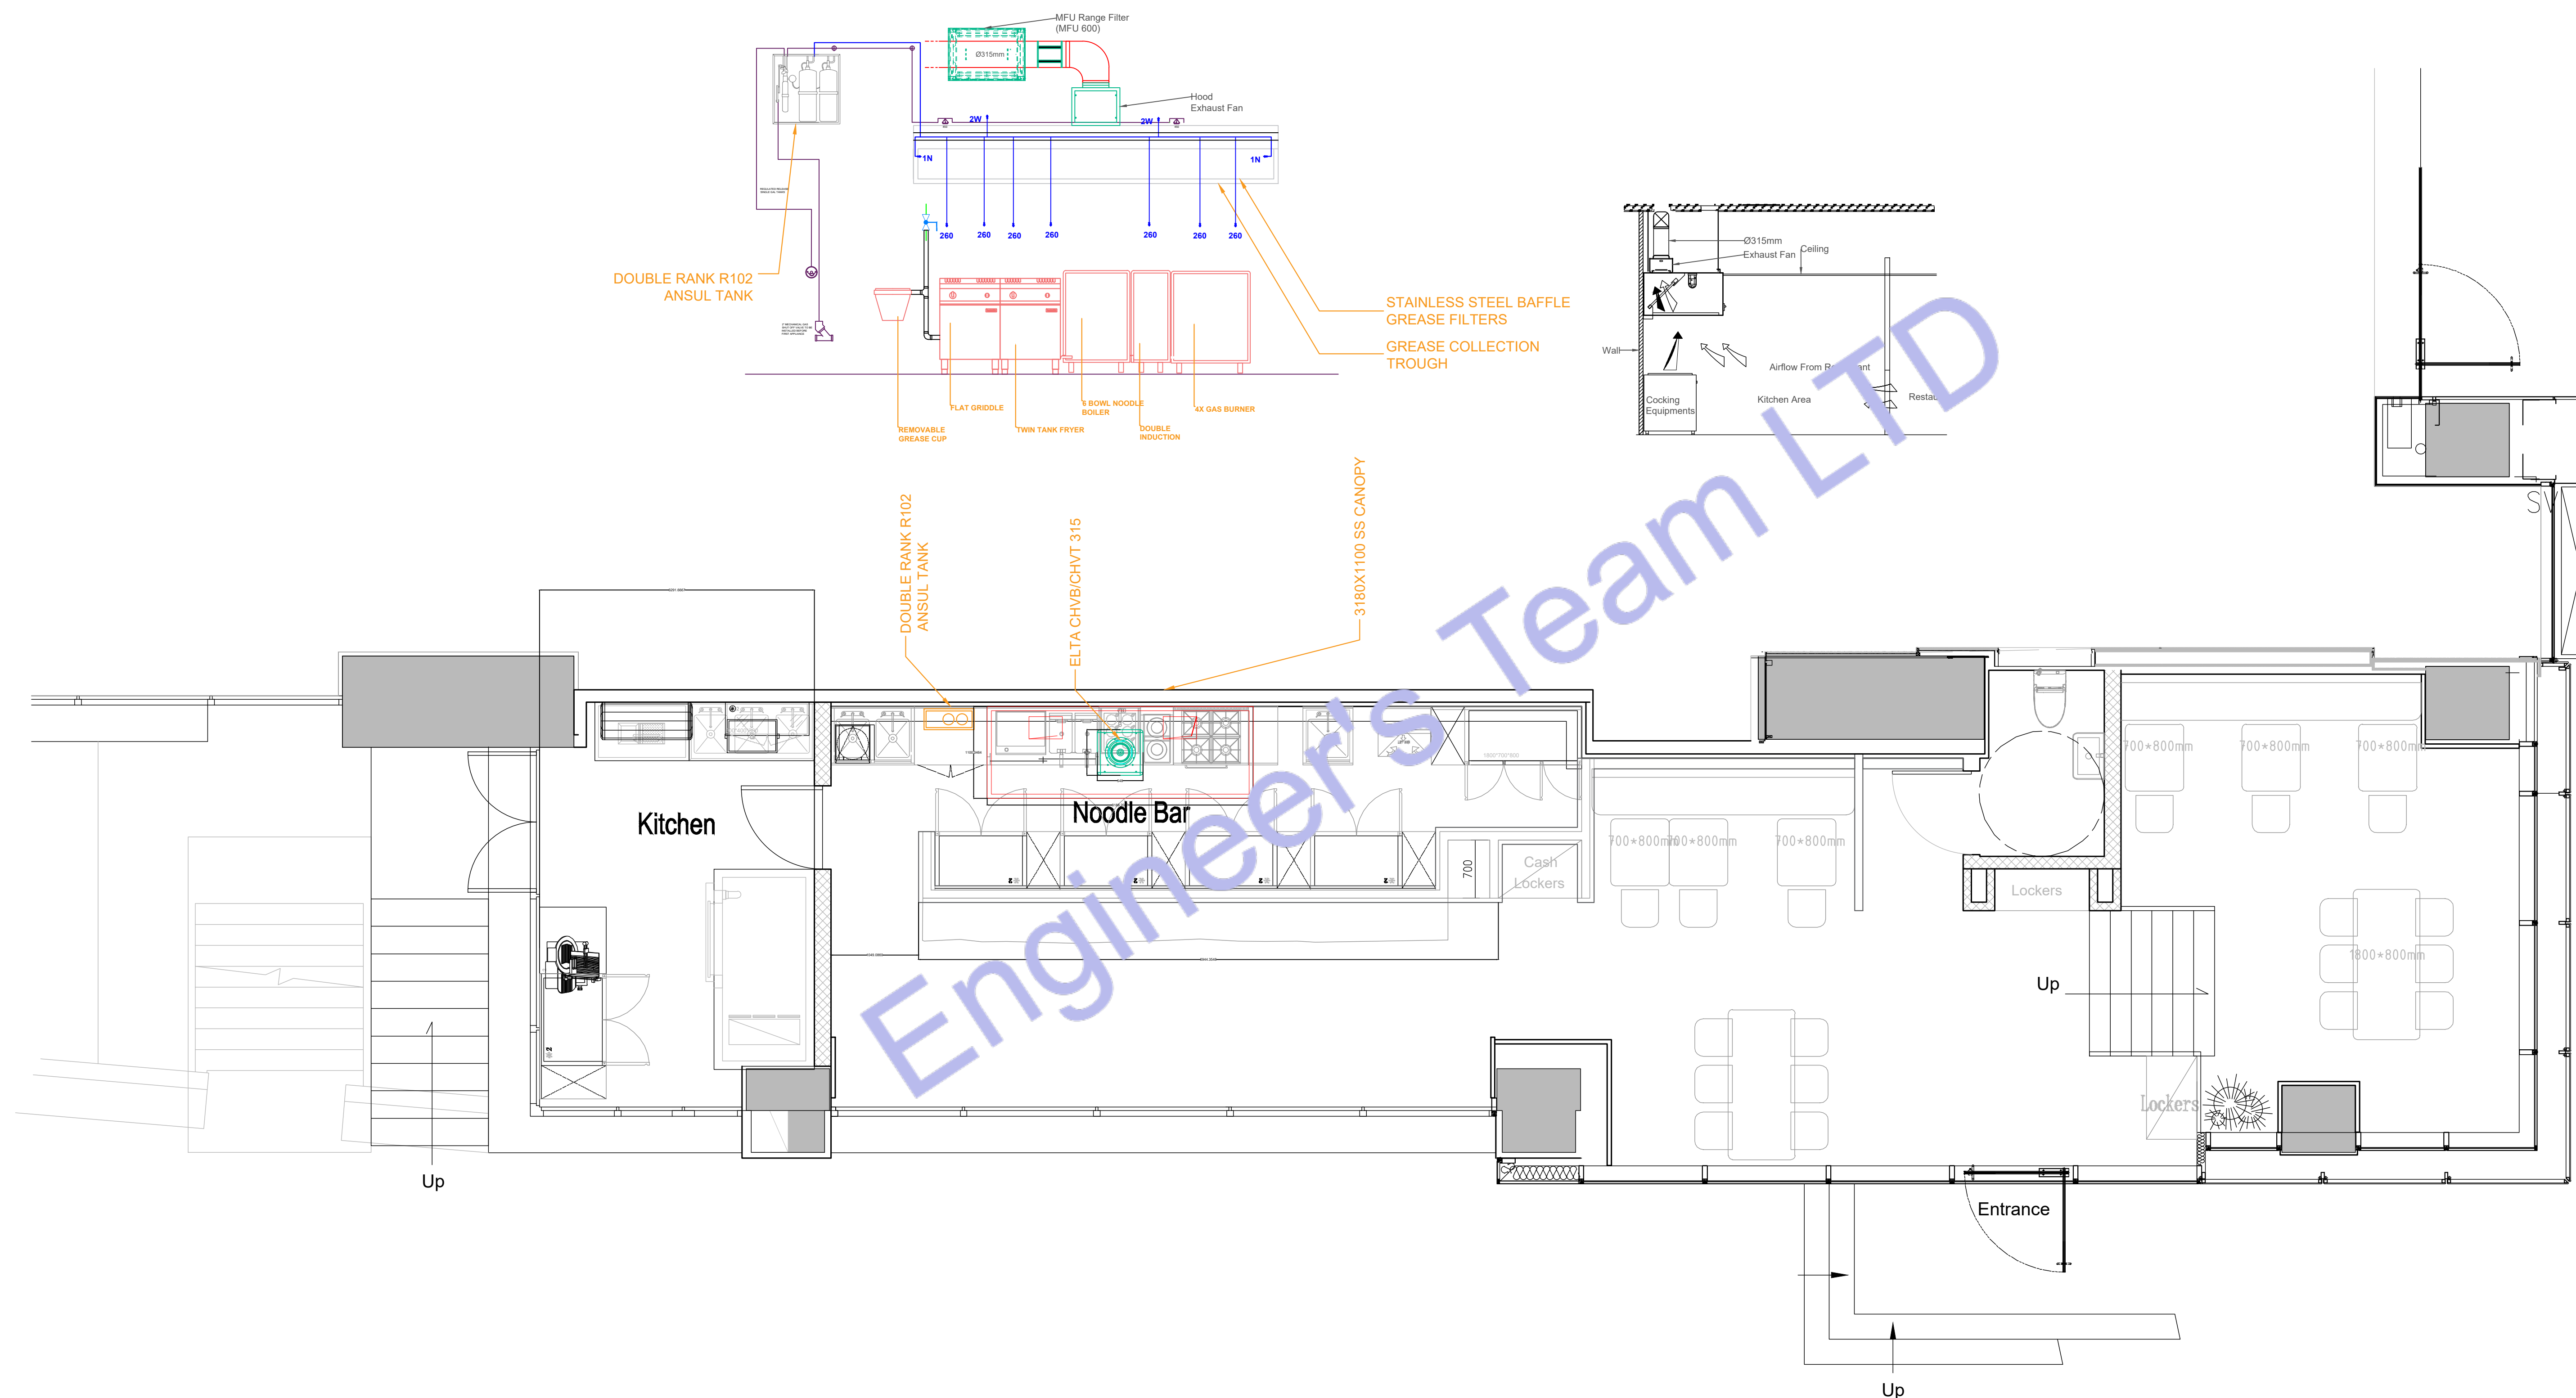



ENGINEER'S TEAM LTD
Web site: www.engrteam.com
Email: support@engrteam.com

CLIENT: MR AND MRS ANDERTON

ADDRESS:
25 WILBURY AVENUE,
HOVE, BN3 6HS

CONFIDENTIALITY STATEMENT:
ALL DRAWINGS AND WRITTEN MATERIALS
APPEARING HEREIN CONSTITUTE THE
ORIGINAL AND UNPUBLISHED WORK OF THE
DESIGNER AND THE SAME MAY NOT BE
DUPLICATED, USED OR DISCLOSED WITHOUT
CONSENT OF THE DESIGNER.

NOTES:
1. ALL DIMENSIONS HEREIN ARE IN IMPERIAL
UNITS UNLESS STATED OTHERWISE.
2. THESE DRAWINGS ARE TO BE READ IN
CONJUNCTION WITH ALL RELEVANT DESIGNER,
ENGINEER OR SPECIALIST DRAWINGS AND
SPECIFICATIONS.
3. THE CONTRACTOR MUST CHECK ALL
DIMENSION AT SITE BEFORE COMMENCING
WORK.
4. THE CONTRACTOR IS RESPONSIBLE FOR
PROVIDING ALL NECESSARY TEMPORARY
SUPPORT TO THE BUILDING AND ANY ADJACENT
STRUCTURES.

REFERENCE:
HAN-GOYA-00-XX-CO-5601

REV. NO	DESCRIPTION	DATE	BY
01	Add Grease Trap & update the plumbing plans	03/02/26	AA
02	Create leak detection, Gas & Fire protection etc plans	06/27/26	AA
03	Fix HVAC system and add new system	07/21/26	AA
04	Change VRF system & Fix Ventilation	07/27/26	AA
05	Provide more information about the HVAC system	08/04/26	AA
05	HVAC Elevation Plan & Filtrations Specification.	08/16/26	AA

PROJECT:
25 WILBURY AVENUE

TITLE: HVAC ELEVATION PLAN

PROJ. NO. PROJ. ENGR. SCALE @ 24X36:
1:100

DATE :
September 14, 2026

DRAWING NO. REV.
M - 1 3 6

 
Mechanical Legends




MECHANICAL VENTILATION HEAT RECOVERY



VRF OUTDOOR CONDENSER
950 x 1380 x 330 mm



SUPPLY AIR DIFFUSER

 

EXHAUST AIR DIFFUSER



KITCHEN CHIMNEY



EXHAUST FAN



SUPPLY AIR DUCT




FIRE STOP



SOUND ATTENUATION



AIR FILTRATION

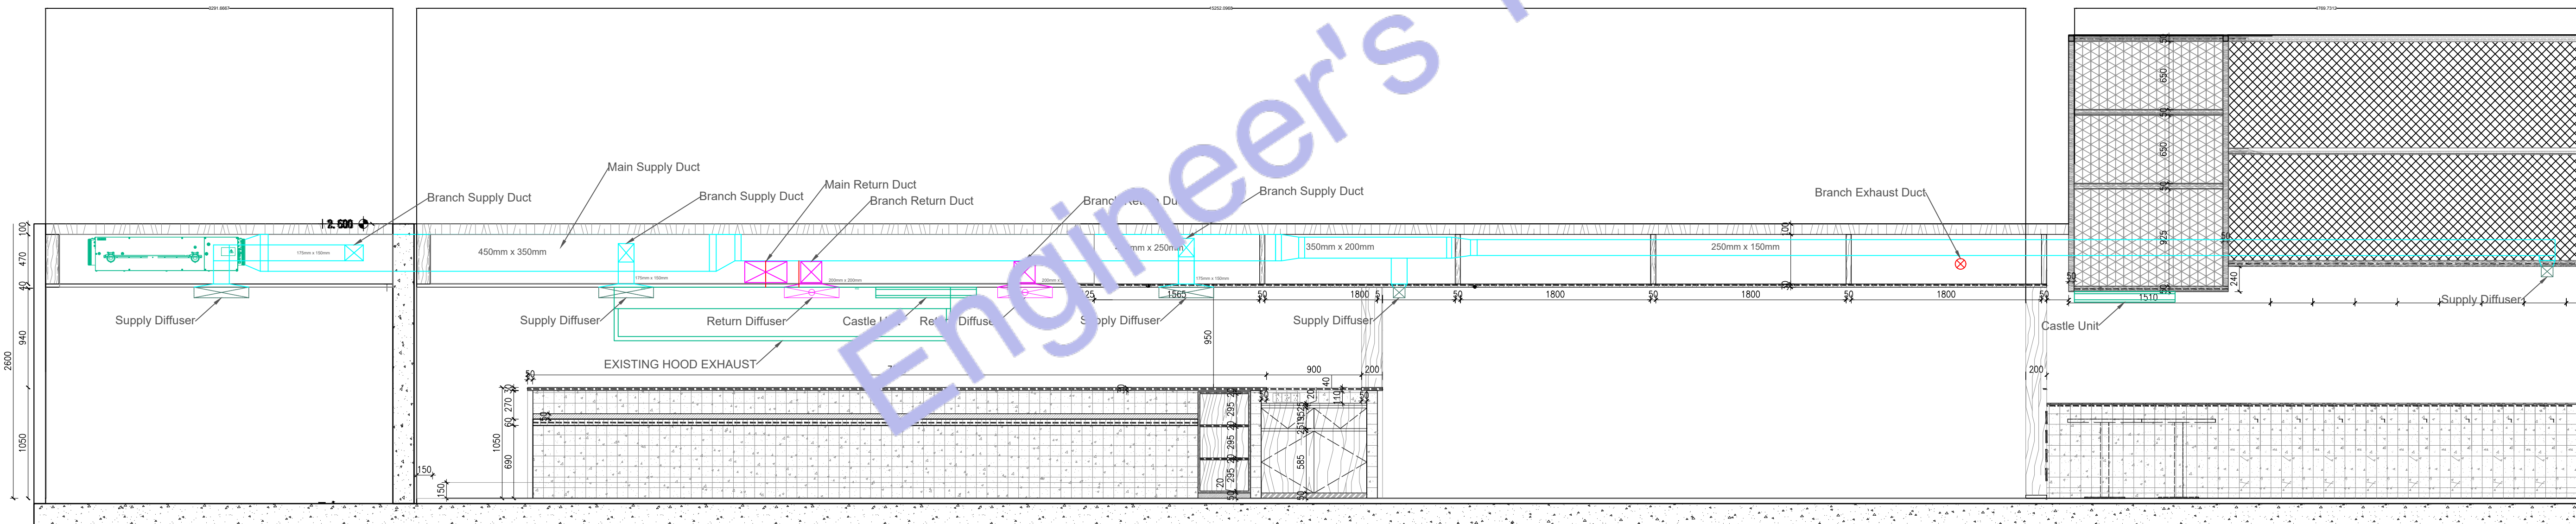



ENGINEER'S TEAM LTD

Web site: www.engrteam.com
Email: support@engrteam.com

CLIENT: MR AND MRS ANDERTON

ADDRESS: 25 WILBURY AVENUE,
HOVE, BN3 6HS

CONFIDENTIALITY STATEMENT:

ALL DRAWINGS AND WRITTEN MATERIALS

APPEARING HEREIN CONSTITUTE THE

ORIGINAL AND UNPUBLISHED WORK OF THE

DESIGNER AND THE SAME MAY NOT BE

DUPLICATED, USED OR DISCLOSED WITHOUT

CONSENT OF THE DESIGNER.

NOTES:

1. ALL DIMENSIONS HEREIN ARE IN IMPERIAL UNITS UNLESS STATED OTHERWISE.
2. THESE DRAWINGS ARE TO BE READ IN CONJUNCTION WITH ALL RELEVANT DESIGNER, ENGINEER OR SPECIALIST DRAWINGS AND SPECIFICATIONS.
3. THE CONTRACTOR MUST CHECK ALL DIMENSION AT SITE BEFORE COMMENCING WORK.
4. THE CONTRACTOR IS RESPONSIBLE FOR PROVIDING ALL NECESSARY TEMPORARY SUPPORT TO THE BUILDING AND ANY ADJACENT STRUCTURES.

REV. NO.	DESCRIPTION	DATE	BY
01	Add Grease Trap & update the plumbing plans	03/02/26	AA
02	Create leak detection, Gas & Fire protection etc plans	06/27/26	AA
03	Fix HVAC system and add new system	07/21/26	AA
04	Change VRF system & Fix Ventilation	07/27/26	AA
05	Provide more information about the HVAC system	08/04/26	AA
05	HVAC Elevation Plan & Filtrations Specification.	08/16/26	AA

PROJECT: 25 WILBURY AVENUE

TITLE: HVAC CALCULATION

PROJ. NO. PROJ. ENGR. SCALE @ 24X36: 1:100

DATE : September 14, 2026

DRAWING NO. M - 1 4 REV. 6

Air System Sizing Summary for HVAC CASTLE SYSTEM

Project Name: 219 Project 07/16/2026
Prepared by: Engineer's Team LTD 03:52PM

Air System Information

Air System Name HVAC CASTLE SYSTEM Number of zones 1
Equipment Class SPLT AHU Floor Area 102.6 m²
Air System Type SZCAV Location London - Kew, United Kingdom

Sizing Calculation Information

Calculation Months Jan to Dec Zone L/s Sizing Sum of space airflow rates
Sizing Data Calculated Space L/s Sizing Individual peak space loads

Central Cooling Coil Sizing Data

Total coil load 14.6 kW Load occurs at Aug 1700
Sensible coil load 10.9 kW OA DB / WB 27.8 / 19.9 °C
Coil L/s at Aug 1700 787 L/s Entering DB / WB 25.5 / 18.8 °C
Max block L/s 787 L/s Leaving DB / WB 14.0 / 13.3 °C
Sum of peak zone L/s 787 L/s Coil ADP 12.4 °C
Sensible heat ratio 0.747 Bypass Factor 0.120
L/s (kW) 53.9 Resulting RH 55 %
m³/kW 7.0 Design supply temp. 12.8 °C
W/m² 142.2 Zone T-stat Check 1 of 1 OK
Water flow @ 5.6 K rise N/A Max zone temperature deviation 0.0 K

Central Heating Coil Sizing Data

Max coil load 10.0 kW Load occurs at Des Htg
Coil L/s at Des Htg 787 L/s W/m² 97.2
Max coil L/s 787 L/s Ent. DB / Lvg DB 13.7 / 24.2 °C
Water flow @ 11.1 K drop N/A

Supply Fan Sizing Data

Actual max L/s 787 L/s Fan motor BHP 0.00 BHP
Standard L/s 786 L/s Fan motor kW 0.00 kW
Actual max L/(s·m²) 7.67 L/(s·m²) Fan static 0 Pa

Outdoor Ventilation Air Data

Design airflow L/s 230 L/s L/s/person 6.07 L/s/person
L/(s·m²) 2.25 L/(s·m²)

Zone Sizing Summary for HVAC CASTLE SYSTEM

Project Name: 219 Project 07/16/2026
Prepared by: Engineer's Team LTD 03:52PM

Air System Information

Air System Name HVAC CASTLE SYSTEM Number of zones 1
Equipment Class SPLT AHU Floor Area 102.6 m²
Air System Type SZCAV Location London - Kew, United Kingdom

Sizing Calculation Information

Calculation Months Jan to Dec Zone L/s Sizing Sum of space airflow rates
Sizing Data Calculated Space L/s Sizing Individual peak space loads

Zone Terminal Sizing Data

Zone Name	Design Supply Airflow (L/s)	Minimum Supply Airflow (L/s)	Sensible Peak Sensible Zone L/s (m²)	Reheat Coil Load (kW)	Reheat Coil Load @ 11.1 K (kW)	Zone Htg Unit Coil Load (kW)	Zone Htg Unit Water L/s @ 11.1 K	Mixing Box Fan Airflow (L/s)
Zone 1	787	787	7.67	0.0	-	0.0	-	0

Zone Peak Sensible Loads

Zone Name	Zone Cooling Sensible (kW)	Time of Peak Sensible Cooling Load	Zone Heating Load (kW)	Zone Floor Area (m²)
Zone 1	10.5	Jul 2200	2.9	102.6

Space Loads and Airflows

Zone Name / Space Name	Mult.	Cooling Sensible (kW)	Time of Peak Sensible Load	Air Flow (L/s)	Heating Load (kW)	Floor Area (m²)	Space L/(s·m²)
Zone 1							
Dining Area 1	1	1.7	Jul 2000	124	1.0	31.6	3.92
Dining Area 2	1	1.6	Jul 2200	119	0.8	28.1	4.24
Noodle bar Area	1	5.2	Jul 2200	391	0.5	20.9	18.71
Noodle bar dining	1	2.0	Jul 2200	152	0.6	22.0	

Ventilation Sizing Summary for HVAC CASTLE SYSTEM

Project Name: 219 Project 07/16/2026
Prepared by: Engineer's Team LTD 03:52PM

1. Summary

Ventilation Sizing Method Sum of Space OA Airflows
Design Ventilation Airflow Rate 230 L/s

2. Space Ventilation Analysis

Zone Name / Space Name	Mult.	Floor Area (m²)	Maximum Occupants	Maximum Supply Air (L/s)	Required Outdoor Air (L/s/person)	Required Outdoor Air (L/(s·m²))	Required Outdoor Air (L/s)	Required Outdoor Air (% of supply)	Uncorrected Outdoor Air (L/s)
Zone 1									
Dining Area 1	1	31.6	9.0	123.9	3.80	0.90	0.0	0.0	62.6
Dining Area 2	1	28.1	9.0	119.2	3.80	0.90	0.0	0.0	59.5
Noodle bar Area	1	20.9	5.0	391.1	3.80	0.60	0.0	0.0	31.5
Noodle bar dining	1	22.0	15.0	152.3	3.80	0.90	0.0	0.0	76.8
Totals (incl. Space Multipliers)				786.5					230.5

Engineer's Team LTD

Dedicated Outdoor Air System (DOAS) Sizing Summary for HVAC DEDICATED OUTDOOR AIR

Project Name: 219 Project 06/20/2026
Prepared by: Engineer's Team LTD 05:32PM

Air System Information

Air System Name HVAC DEDICATED OUTDOOR AIR Number of zones 1
Equipment Class TERM Floor Area 121.4 m²
Air System Type PKG-FC Location London - Kew, United Kingdom

Sizing Calculation Information

Calculation Months Jan to Dec Zone L/s Sizing Sum of space airflow rates
Sizing Data Calculated Space L/s Sizing Individual peak space loads

Ventilation Fan Sizing Data

Actual max L/s 262 L/s Fan motor BHP 0.00 BHP
Standard L/s 262 L/s Fan motor kW 0.00 kW
Actual max L/(s·m²) 2.16 L/(s·m²) Fan static 0 Pa

Outdoor Ventilation Air Data

Design airflow L/s 262 L/s L/s/person 6.09 L/s/person
L/(s·m²) 2.16 L/(s·m²)

Zone Sizing Summary for HVAC DEDICATED OUTDOOR AIR

Project Name: 219 Project 06/20/2026
Prepared by: Engineer's Team LTD 05:32PM

Air System Information

Air System Name HVAC DEDICATED OUTDOOR AIR Number of zones 1
Equipment Class TERM Floor Area 121.4 m²
Air System Type PKG-FC Location London - Kew, United Kingdom

Sizing Calculation Information

Calculation Months Jan to Dec Zone L/s Sizing Sum of space airflow rates
Sizing Data Calculated Space L/s Sizing Individual peak space loads

Terminal Unit Sizing Data - Cooling

Zone Name	Total Coil Load (kW)	Sens Coil Load (kW)	Coil Entering DB / WB (°C)	Coil Leaving DB / WB (°C)	Water Flow @ 5.6 K (L/s)	Time of Peak Coil Load	Zone L/(s·m²)
Zone 1	16.0	11.7	19.6 / 24.3	13.1	-	Jul 1900	7.38

Terminal Unit Sizing Data - Heating, Fan, Ventilation

Zone Name	Heating Coil Load (kW)	Heating Coil Ent/Lvg DB (°C)	Htg Coil Water Flow @11.1 K (L/s)	Fan Design Airflow (L/s)	Fan Motor (BHP)	Fan Motor (kW)	OA Vent Design Airflow (L/s)
Zone 1	5.1	19.6 / 24.3	-	895	0.000	0.000	262

Zone Peak Sensible Loads

Zone Name	Zone Cooling Sensible (kW)	Time of Peak Sensible Cooling Load	Zone Heating Load (kW)	Zone Floor Area (m²)
Zone 1	12.0	Jul 2200	3.3	121.4

Space Loads and Airflows

Zone Name / Space Name	Mult.	Cooling Sensible (kW)	Time of Peak Sensible Load	Air Flow (L/s)	Heating Load (kW)	Floor Area (m²)	Space L/(s·m²)
Zone 1							
Dining Area 1	1	1.7	Jul 2000	124	1.0	31.6	3.93
Dining Area 2	1	1.6	Jul 2200	119	0.8	28.1	4.25
Kitchen	1	1.2	Jul 2000	91	0.3	15.7	5.81
Noodle bar Area	1	5.2	Jul 2200	392	0.5	20.9	18.75
Noodle bar dining	1	2.0	Jul 2200	153	0.6	22.0	6.94
Washroom	1	0.2	Jul 1900	16	0.1	3.1	5.21

According to calculation:

Maximum occupants 43 person

Required outdoor air 10 L/s per person

Total required outdoor air 430 L/s

And the new system supply 430 L/s fresh outdoor air



CLIENT: MR AND MRS ANDERTON

ADDRESS:
25 WILBURY AVENUE,
HOVE, BN3 6HS

CONFIDENTIALITY STATEMENT:
ALL DRAWINGS AND WRITTEN MATERIALS
APPEARING HEREIN CONSTITUTE THE
ORIGINAL AND UNPUBLISHED WORK OF THE
DESIGNER AND THE SAME MAY NOT BE
DUPLICATED, USED OR DISCLOSED WITHOUT
CONSENT OF THE DESIGNER.

NOTES:

1. ALL DIMENSIONS HEREIN ARE IN IMPERIAL UNITS UNLESS STATED OTHERWISE.
2. THESE DRAWINGS ARE TO BE READ IN CONJUNCTION WITH ALL RELEVANT DESIGNER, ENGINEER OR SPECIALIST DRAWINGS AND SPECIFICATIONS.
3. THE CONTRACTOR MUST CHECK ALL DIMENSION AT SITE BEFORE COMMENCING WORK.
4. THE CONTRACTOR IS RESPONSIBLE FOR PROVIDING ALL NECESSARY TEMPORARY SUPPORT TO THE BUILDING AND ANY ADJACENT STRUCTURES.

REV. NO	DESCRIPTION	DATE	BY
01	Add Grease Trap & update the plumbing plans	03/02/26	J
02	Create leak detection, Gas & Fire protection etc plans	06/27/26	J
03	Fix HVAC system and add new system	07/21/26	J
04	Change VRF system & Fix Ventilation	07/27/26	J
05	Provide more information about the HVAC system	08/04/26	J
05	HVAC Elevation Plan & Filtrations Schedule	08/16/26	J

PROJECT: 25 WILBURY AVENUE

TITLE:

HVAC EQUIPMENT SCHEDULE

PROJ. NO.	PROJ. ENGR.	SCALE @ 24X36: N/A
-----------	-------------	-----------------------




DATE : September 14, 2026

DRAWING NO.	REV.
M - 1 5	6


HVAC EQUIPMENT SCHEDULE

Tag	Equipment	Proposed Equipment	New / Existing	Qty	Design Duty	Airflow	Power Supply	Remarks
ODU-1	VRF Outdoor Unit	Fujitsu General AOEG54KRTA	N	1	Capacity: 13.5-15.5 kW	787 L/s	400V, 3Ph, 50Hz	R32 subject is final
IDU-1	4-Way Ceiling Cassette	Fujitsu General cassette AUXG24KVLA R32	N	1	7 kW Cooling	243 L/s	230V, 1Ph	Dining Area
IDU-2	4-Way Ceiling Cassette	Fujitsu General cassette AUXG24KVLA R33	N	1	7 kW Cooling	152 L/s	230V, 1Ph	Noodle Bar Dining
HRU-1	MVHR / DOAS Unit	Blauberg EcoSlim 900	N	1	Heat Recovery $\geq 88\%$	232 L/s Outdoor Air	230V, 1Ph	Fresh air supply to restaurant
KEF-1	Kitchen Extract Fan	Elta CHVB/CHVT 315	E	1	1000 m ³ /h @ 343 Pa	1667 L/s	230V, 1Ph	Heavy-duty grease extract (DW/172)
EF-1	Toilet Extract Fan	EnviroVent SIL150S	N	1	78 L/s	79 L/s	230V	Ground Floor WC
DEF-1	FRONT DINING AREA	EnviroVent SIL150S	N	1	78 L/s	79 L/s	230V	Ground Floor DINING AREA
FD	Fire Damper	CE/UKCA Certified Fire Damper	N	14	2 Hour Fire Rating	—	—	Installed at fire-rated penetrations
SD	Circular Silencer	Lindab / Waterloo	N	As Required	—	—	—	Kitchen extract ductwork
GF	Grease Filters	Stainless Steel Baffle Filters	N	6	DW/172 Compliant	—	—	Removable and washable
WL	Weather Louvres	Aluminium Drainable Weather Louvres	N	As Required	Low Leakage	—	—	Fresh air intake and exhaust discharge


DUCTWORK SYMBOLS LEGEND

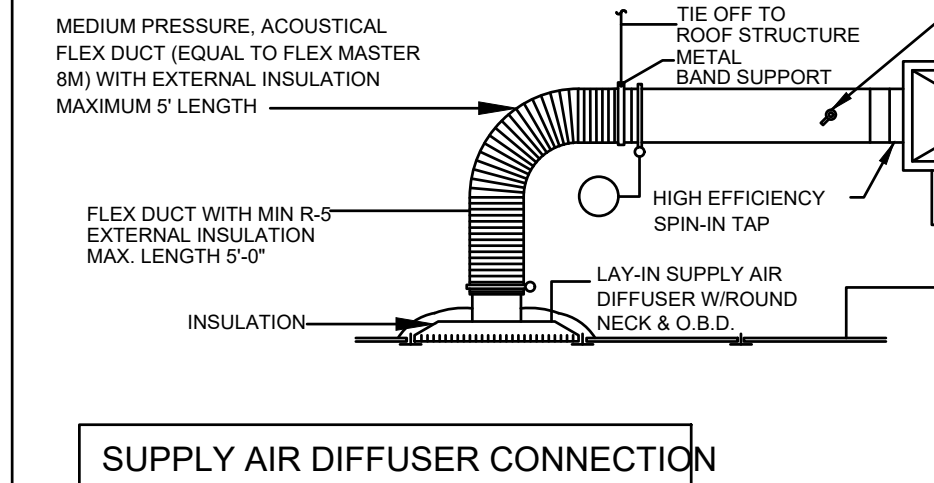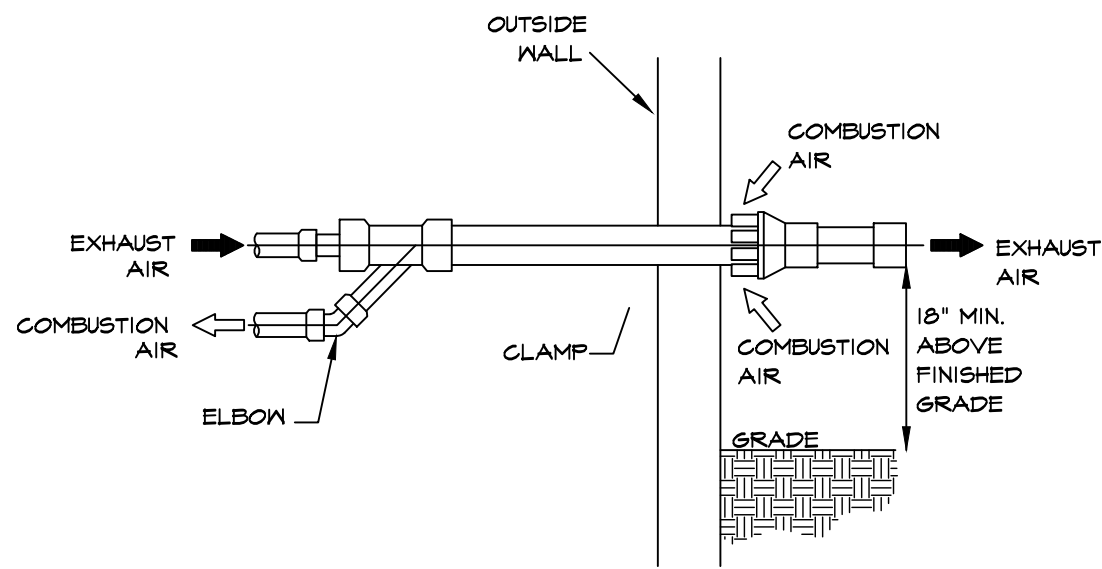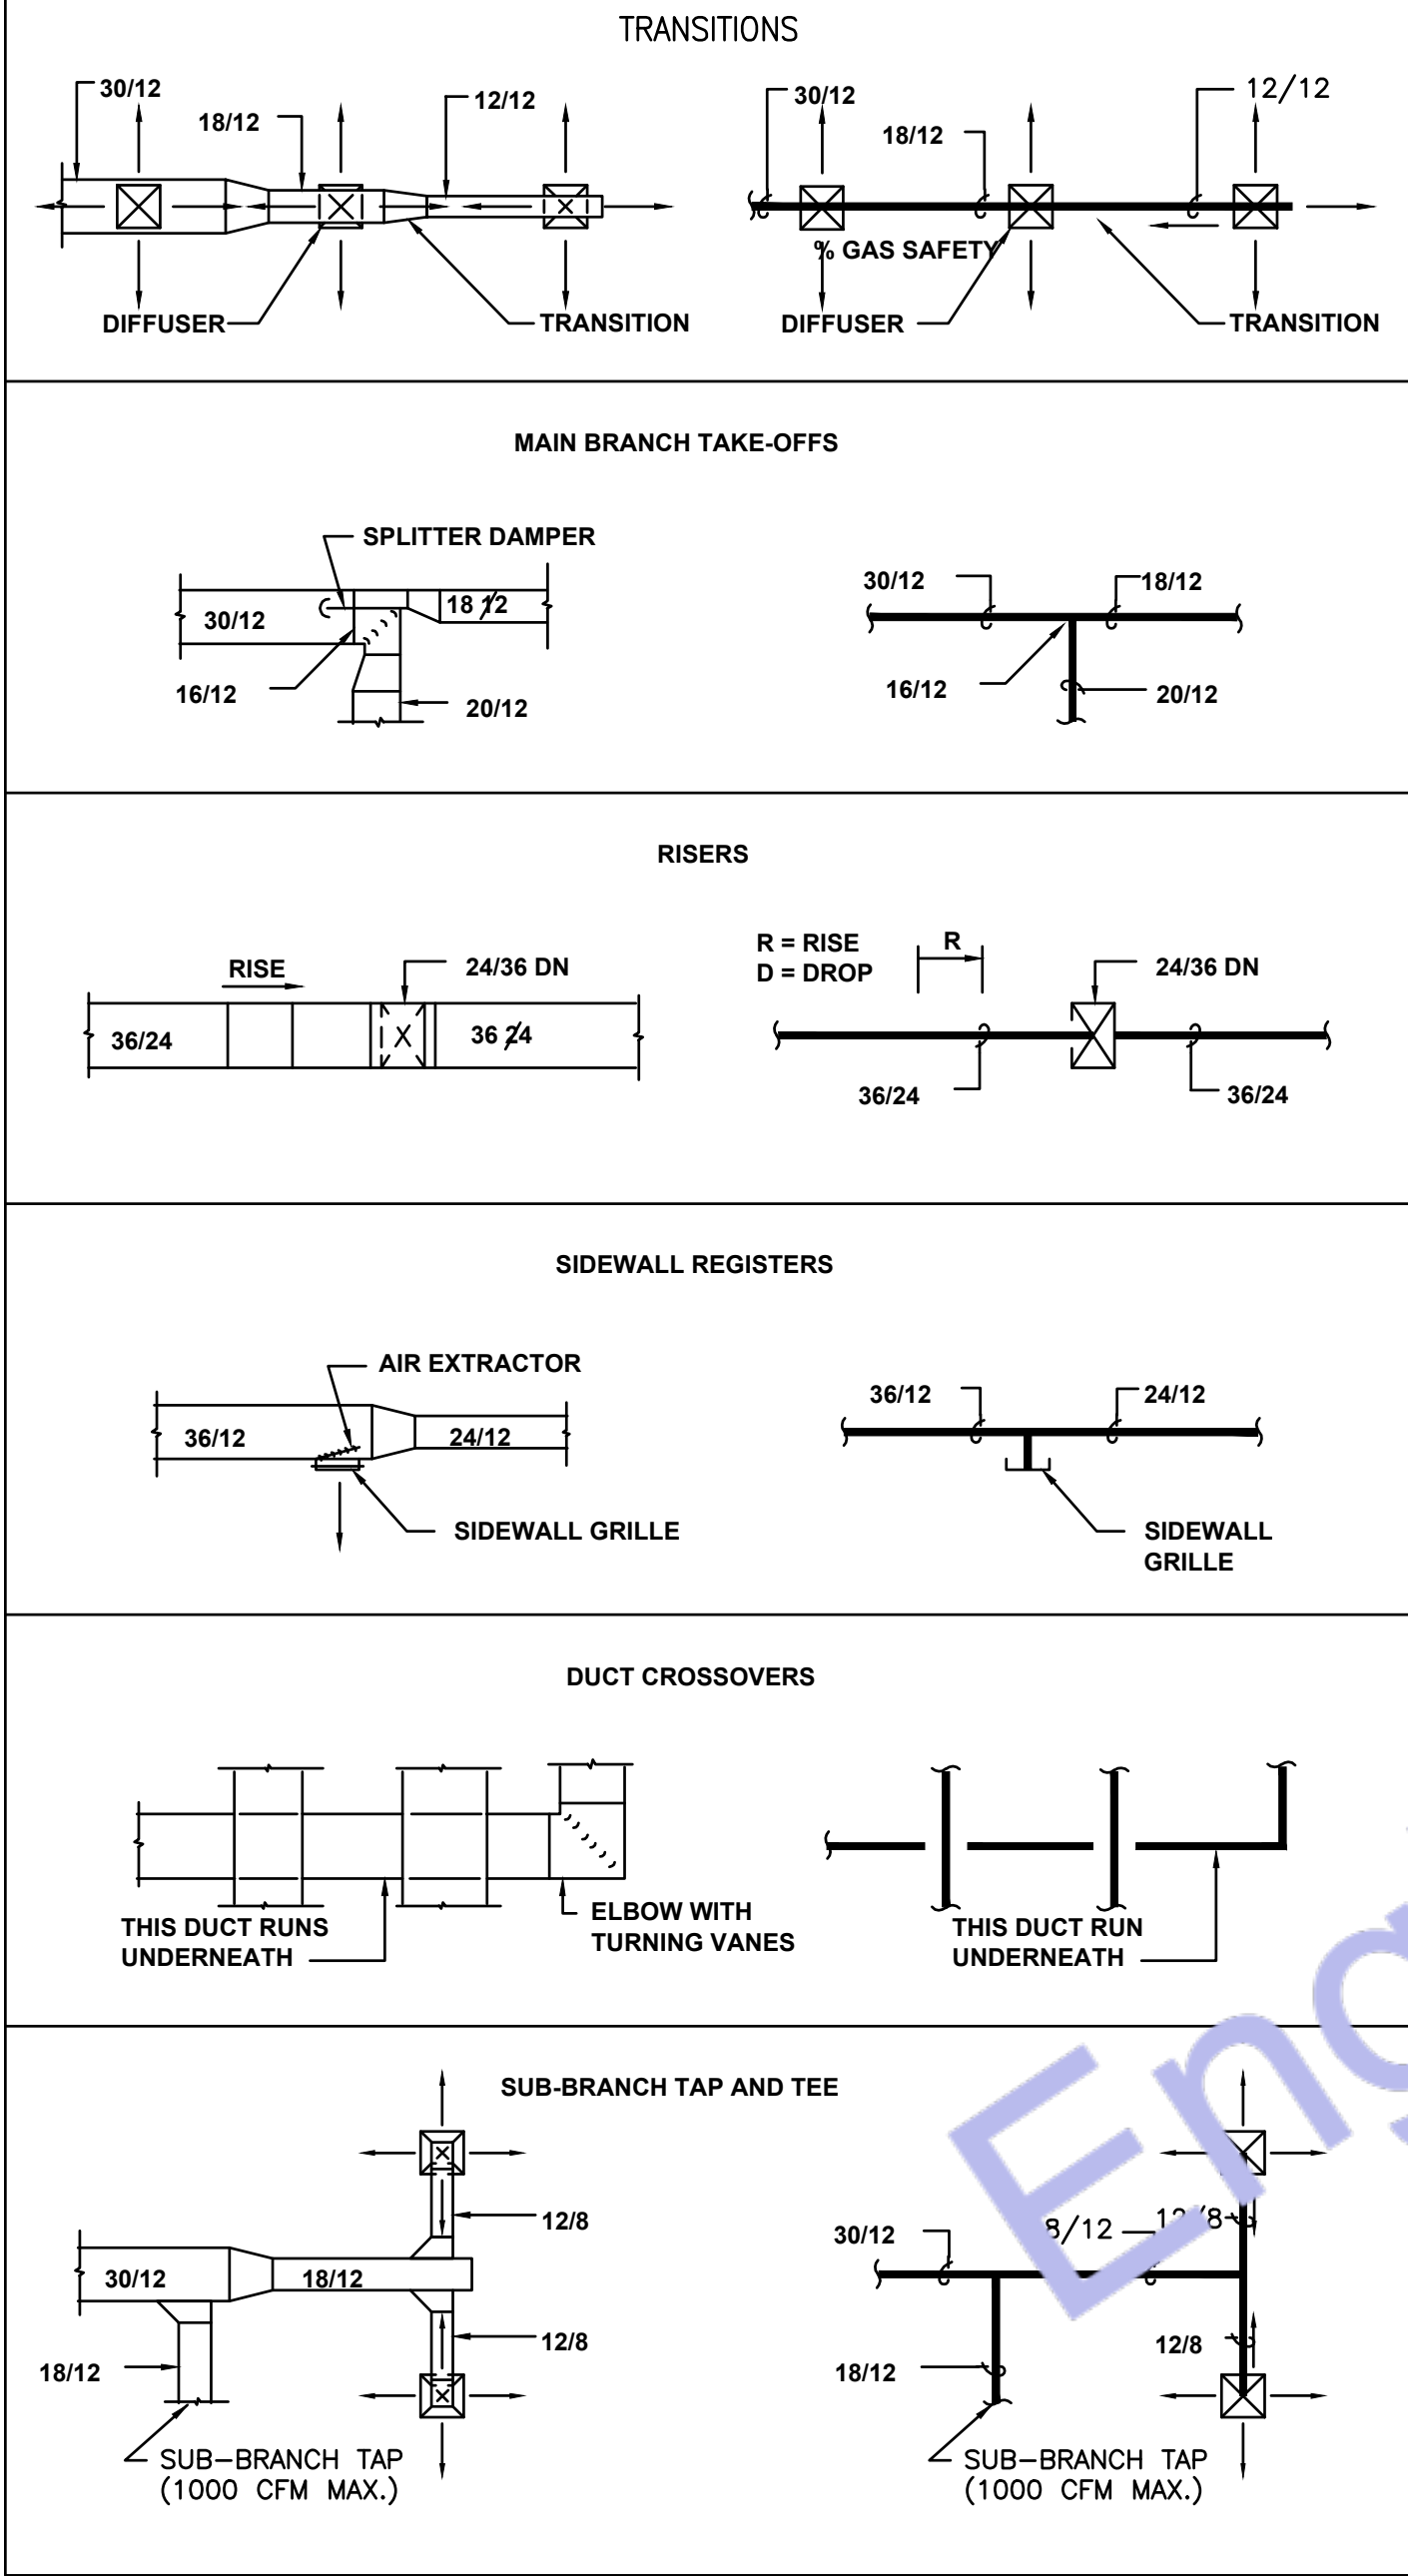


SUPPLY AIR DIFFUSER CONNECTION

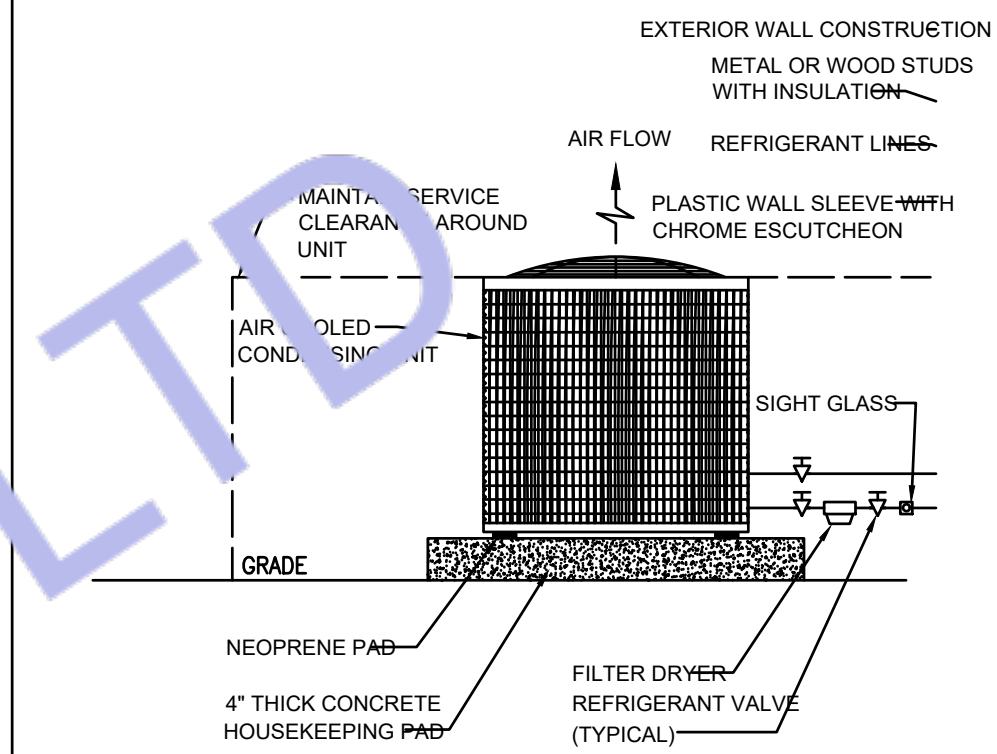

OUTSIDE AIR CONDITIONER

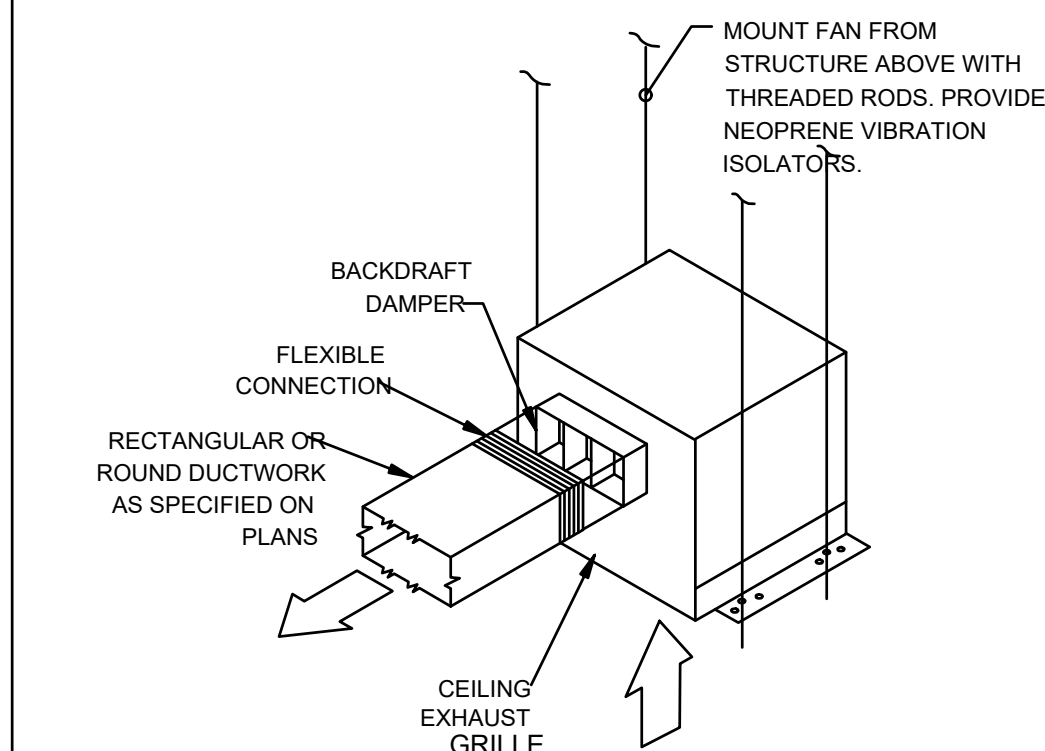

CEILING EXHAUST FAN DETAIL

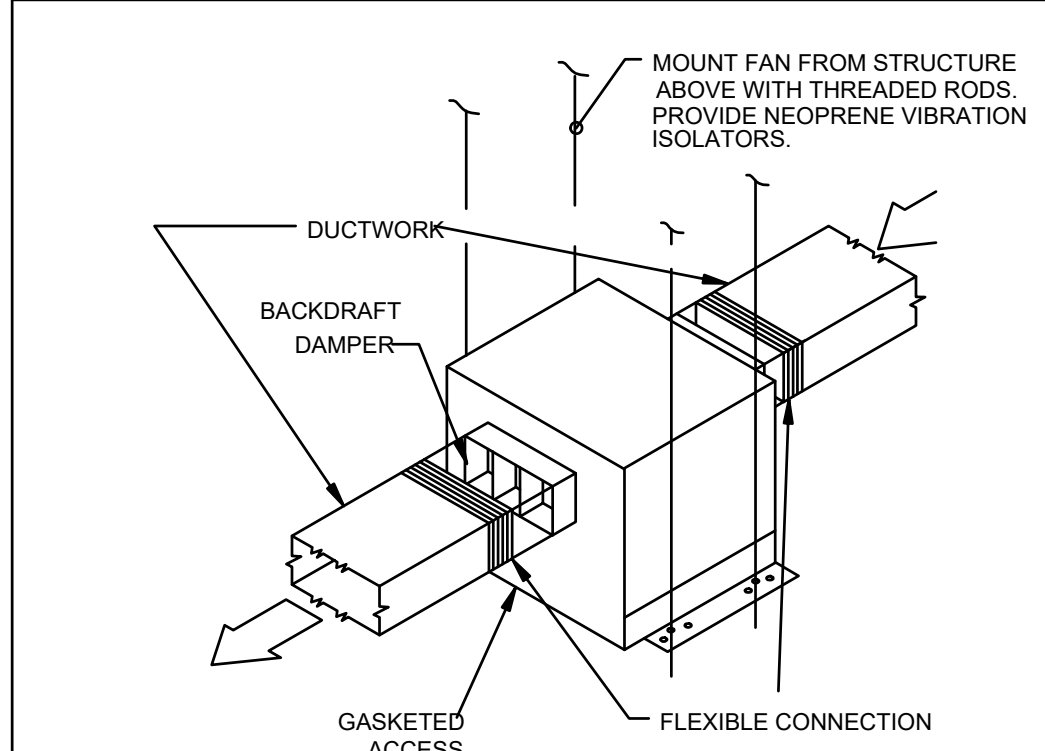

IN-LINE FAN DETAIL

- NOTES:
- ENTRANCE (A) HAS A DIFFUSER FITTING THAT RECOVERS VELOCITY PRESSURES AND PREVENTS SWIRLS (OPTIONAL).
 - STRAIGHT APPROACH (A) AND STRAIGHT EXITS (B).
 - EXITS OPENING ON SIDE (NO TOP OR BOTTOM EXITS).
 - EXIT OPENING AT LEAST TWO FEET MINIMUM.
 - MAKE BOX AS SMALL AS POSSIBLE. CALCULATING AREA L = 2 X D.

- NOTES:
- INTERNALLY LINED SUPPLY AND RETURN SHEET METAL FLEUMS THAT EXTENDS 10 FEET ON EITHER SIDE OF AHU, FULL SIZE OF UNIT OPENING.
 - 3/4\"/>



ENGINEER'S TEAM LTD
Web site: www.engrteam.com
Email: support@engrteam.com

CLIENT: MR AND MRS ANDERTON

ADDRESS: 25 WILBURY AVENUE,
HOVE, BN3 6HS

CONFIDENTIALITY STATEMENT:
ALL DRAWINGS AND WRITTEN MATERIALS
APPEARING HEREIN CONSTITUTE THE
ORIGINAL AND UNPUBLISHED WORK OF THE
DESIGNER AND THE SAME MAY NOT BE
DUPLICATED, USED OR DISCLOSED WITHOUT
CONSENT OF THE DESIGNER.

- NOTES:**
- ALL DIMENSIONS HEREIN ARE IN IMPERIAL UNITS UNLESS STATED OTHERWISE.
 - THESE DRAWINGS ARE TO BE READ IN CONJUNCTION WITH ALL RELEVANT DESIGNER, ENGINEER OR SPECIALIST DRAWINGS AND SPECIFICATIONS.
 - THE CONTRACTOR MUST CHECK ALL DIMENSION AT SITE BEFORE COMMENCING WORK.
 - THE CONTRACTOR IS RESPONSIBLE FOR PROVIDING ALL NECESSARY TEMPORARY SUPPORT TO THE BUILDING AND ANY ADJACENT STRUCTURES.

REV. NO.	DESCRIPTION	DATE	BY
01	Add Grease Trap & update the plumbing plans	03/02/26	AA
02	Create leak detection, Gas & Fire protection etc plans	06/27/26	AA
03	Fix HVAC system and add new system	07/21/26	AA
04	Change VRF system & Fix Ventilation	07/27/26	AA
05	Provide more information about the HVAC system	08/04/26	AA
05	HVAC Elevation Plan & Filtrations Specification.	08/16/26	AA

PROJECT: 25 WILBURY AVENUE

TITLE: HVAC INSTALLATION

PROJ. NO. PROJ. ENGR. SCALE @ 24X36: N/A

DATE : September 14, 2026

DRAWING NO. M - 1 6 REV. 6



Designed By Engr. Al Amin (MEP Engineer | Director - Engineer's Team LTD)

 support@engrteam.com

 <https://engrteam.com>

OUR SERVICES:

- MEP Plan Services
- HVAC Layout Plan
- Electrical Engineering Services
- Plumbing Engineering Services
- Fire protection & Security systems
- Specialized services

INFORMATION:

- Studio
- Contact Us
- Gift cards
- Privacy Policy
- Refund Policy
- Delivery Policy